




0.6mm PREPARED CHROMIUM IRB PROFILE ROOF SHEETING SCRAMED TO TOP OF PARLINGS COLOUR: MATCH EXISTING NEAREST BUILDING

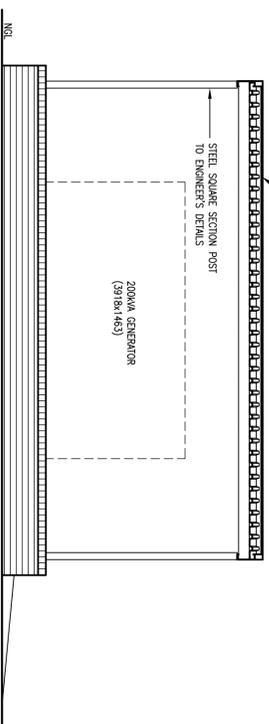


EAST ELEVATION (CARPORT A)
Scale 1:50

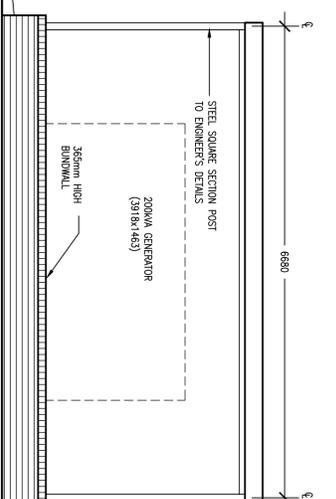


WEST ELEVATION (CARPORT A)
Scale 1:50

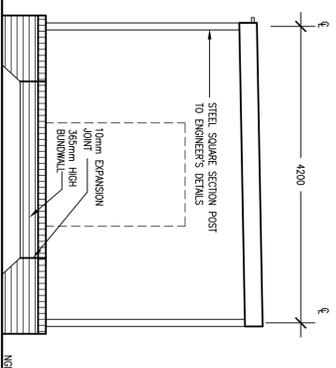


NORTH ELEVATION (CARPORT A)
Scale 1:50

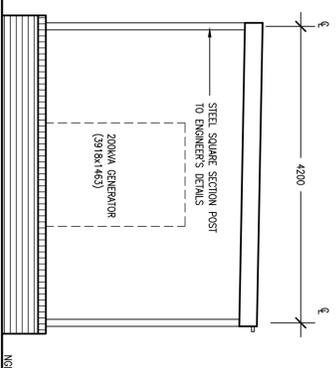


SOUTH ELEVATION (CARPORT A)
Scale 1:50

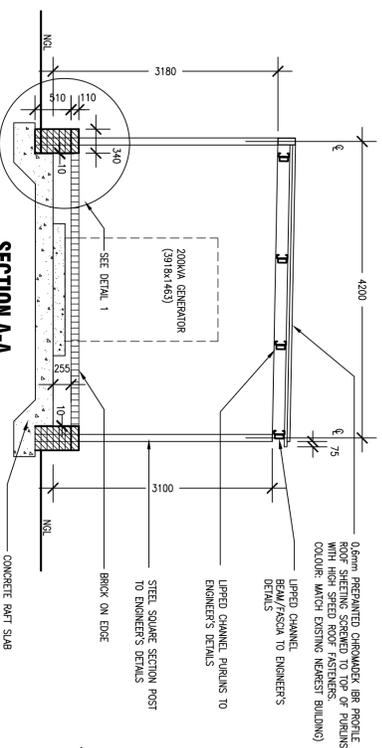


SECTION A-A
Scale 1:50

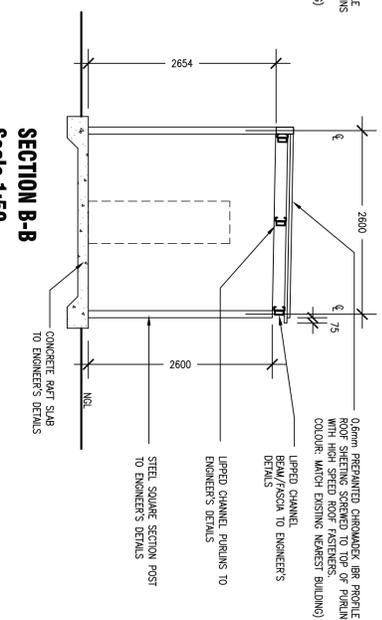


SECTION B-B
Scale 1:50

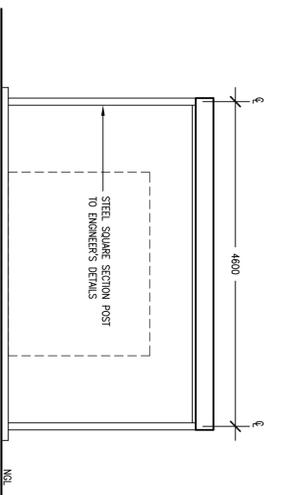


NORTH ELEVATION (CARPORT B)
Scale 1:50

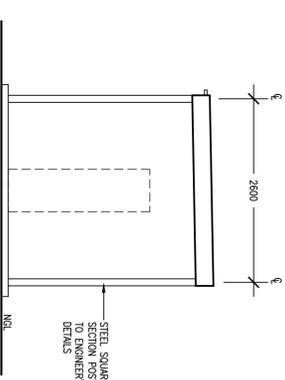


EAST ELEVATION (CARPORT B)
Scale 1:50

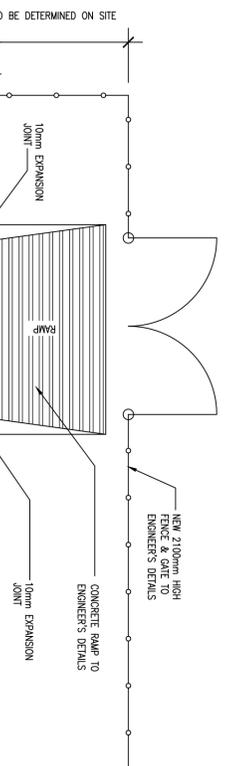


PLAN (CARPORT A)
Scale 1:50

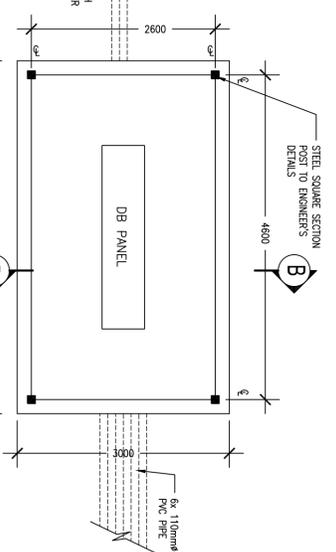


PLAN (CARPORT B)
Scale 1:50

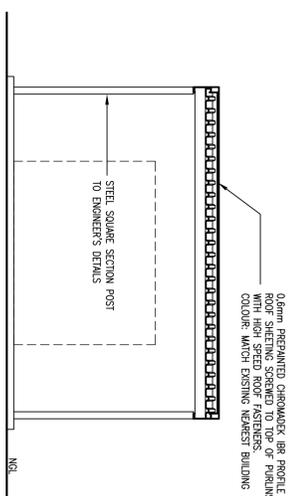

SOUTH ELEVATION (CARPORT B)
Scale 1:50

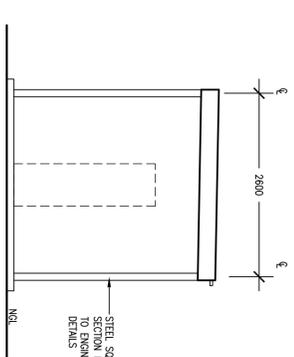

WEST ELEVATION (CARPORT B)
Scale 1:50

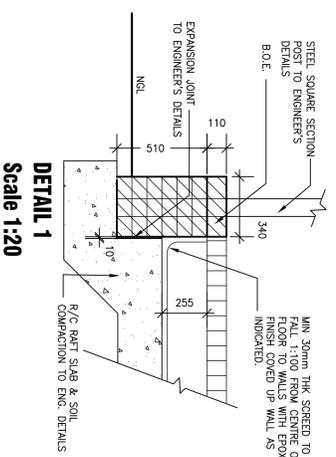

DETAIL 1
Scale 1:20

- NOTES**
1. ALL LOCAL, NATIONAL BY-LAWS & SMS CODE 10400 SHALL BE COMPLIED WITH.
 2. SITE BOUNDARY PEGS OR CO-ORDINATES TO BE IDENTIFIED BEFORE COMMENCEMENT OF ANY WORK.
 3. CONTRACTORS AND SUBCONTRACTORS TO CHECK ALL DIMENSIONS, LEVELS ETC. ON SITE PRIOR TO COMMENCEMENT OF WORK.
 4. ALL LEVELS SHOWN ARE FINISHED LEVELS UNLESS OTHERWISE SPECIFIED.
 5. ALL NEW WORK TO MATCH AND LINE UP WITH EXISTING. NO DIMENSIONS TO BE SCALED. ONLY FIGURED DIMENSIONS TO BE USED AND LARGE SCALE DETAILS SUPPERCEDE SMALL SCALE DRAWINGS.
 6. ANY QUERIES OR DISCREPANCIES IN DIMENSIONS OR DETAIL ON THE DRAWINGS OR BETWEEN DRAWINGS AND SPECIFICATION TO BE REPORTED TO THE ARCHITECT FOR CLARIFICATION BEFORE RELEVANT MATERIALS ARE ORDERED OR WORK PUT IN HAND.
 7. THE INFORMATION ON THIS DRAWING IS THE PROPERTY OF RAND WATER AND IS COPYRIGHT.
 8. ALL WORK OPENINGS IE: DOORS, WINDOWS ETC. TO HAVE FINISHES SPECIFIED.
 9. ALL ELECTRICAL WORK TO BE DONE BY A CONTRACTOR REGISTERED WITH THE ELECTRICAL CONTRACTING BOARD AND TO BE IN ACCORDANCE WITH SANS 10142-1 AND SANS 10142-2.
 10. RAND WATER ELECTRICAL SPECIFICATION RW-00320-AS-500.
 11. A CERTIFICATE OF COMPLIANCE BY AN ACCREDITED PERSON TO BE PROVIDED FOR THE INSTALLATION.
 12. THE EXISTING ELECTRICAL INSTALLATION AS REQUIRED FOR A CERTIFICATE OF COMPLIANCE AND PROVIDE DEFECTS LIST IF ANY.

No	DATE	CHECKED	APPROVED	DESCRIPTION

NUMBER	TITLE
RA28926/002	PLANS, SECTIONS, ELEVATIONS, DETAIL & FINISHING SCHEDULE
RA28926/001	LOCALITY & SITE PLANS
RA-00320-AS-500	GENERAL ELECTRICAL SPECIFICATION

RAND WATER

BOX 1127
JOHANNESBURG
2000
TEL: 682-0911

JOB No	P-01594	CHECKED	
CONTRACT No		SECTION HEAD	
SCHEME		APPROVED	
DRAWN BY	LT SINDANA	CAPACITY	
DATE	OCTOBER 2018	DATE	

ZWARTKOPJES PUMPING STATION

EMERGENCY SUPPLY @ VARIOUS SITES
PLAN, SECTION, ELEVATIONS, DETAIL & FINISHING SCHEDULE

SCALE	AS SHOWN
RA	28926 / 002