

GENERAL NOTES

THIS DRAWING IS TO BE READ IN CONJUNCTION WITH ALL RELEVANT ARCHITECT'S AND ENGINEER'S DRAWING.

ALL DIMENSIONS, LEVELS, ETC ARE TO BE CHECKED BEFORE ANY WORK IS COMMENCED AND ANY DISCREPANCIES NOTED TO BE BROUGHT TO THE ARCHITECT'S ATTENTION.

ONLY FIGURED DIMENSIONS TO BE USED, SCALING OF DRAWINGS IS NOT ADVISED.

ALL RIGHTS RESERVED, NO PART OF THIS DESIGN SHALL BE REPRODUCED, USED ELSEWHERE AND/ OR IN ANY WAY WITHOUT PRIOR PERMISSION FROM THE ARCHITECT/ ENGINEER.

1. ALL CONSTRUCTION WORK AND TEMPORARY WORKS UNDERTAKEN ON SITE WILL COMPLY WITH SANS 10400 NBR - NATIONAL BUILDING REGULATIONS, LATEST EDITION.

REVISION INFORMATION

REV. NO	DATE	DESCRIPTION

THE MVULA TRUST APPROVAL

Name:.....
Signature:.....Date:.....

LIMPOPO DEPT EDUCATION APPROVAL

Name:.....
Signature:.....Date:.....

PRINCIPAL AGENT APPROVAL

Name:.....
Signature:.....Date:.....

DISCIPLINE : ARCHITECTURE

BUILDING CLASSIFICATION

C3 : PLACE OF INSTRUCTION (SCHOOL)

CLIENT :
LIMPOPO PROVINCIAL GOVERNMENT
Physical : Cr 113 Biccard & 24 Excelsior Street Polokwane, 0700
DEPARTMENT OF EDUCATION
Postal : Private Bag X9489, Polokwane, 0700

PRINCIPAL AGENT : SIST CONSORTIUM

Physical : Farm Rd 631 Portion 45 Polokwane, 0699
TEL : 031 065 1099
EMAIL : Tel@sistengineering.co.za

NAME OF COMPETENT PERSON: **CONT NO:**
FIRM REG NO:

IMPLEMENTING AGENT :

718 James Crescent, Halfway House, Midrand, 1681, South Africa
Send Us Mail info@themvulatrust.org.za
call us +27 11 403 3425

PROJECT NAME

PROPOSED PERMANENT SANITATION FACILITIES FOR TIMAMOGOLO PRIMARY SCHOOL EMIS 926 541 266

DRAWING DESCRIPTION

BLOCK A GRADE R WATERBORNE ABLUTIONS +2UR

PROJECT STATUS

STAGE 1-3 STAGE 4 STAGE 5-6

CONCEPT TENDER CONSTRUCTION

DESCRIPTION: WATER AND SANITATION PROGRAMME

SCALE: AS SHOWN

DRAWN: CHECKED:

NAME OF COMPETENT PERSON: NAME OF COMPETENT PERSON:

MPENDULO SHANGASE **SIYABONGA MANYONI**

REG NO: PrArchST 24751103 REG NO: PrArch 49324416




SIGNATURE: SIGNATURE:

PROJECT NUMBER: ADD17-BATCH06/TMT/LDOE/LP/216 CLUSTER 01 DATE: 05 SEPTEMBER 2023



OCCUPANCY CLASSIFICATION: DWG NO: TMM-ARCH-100-00

REV NO: 05

C3

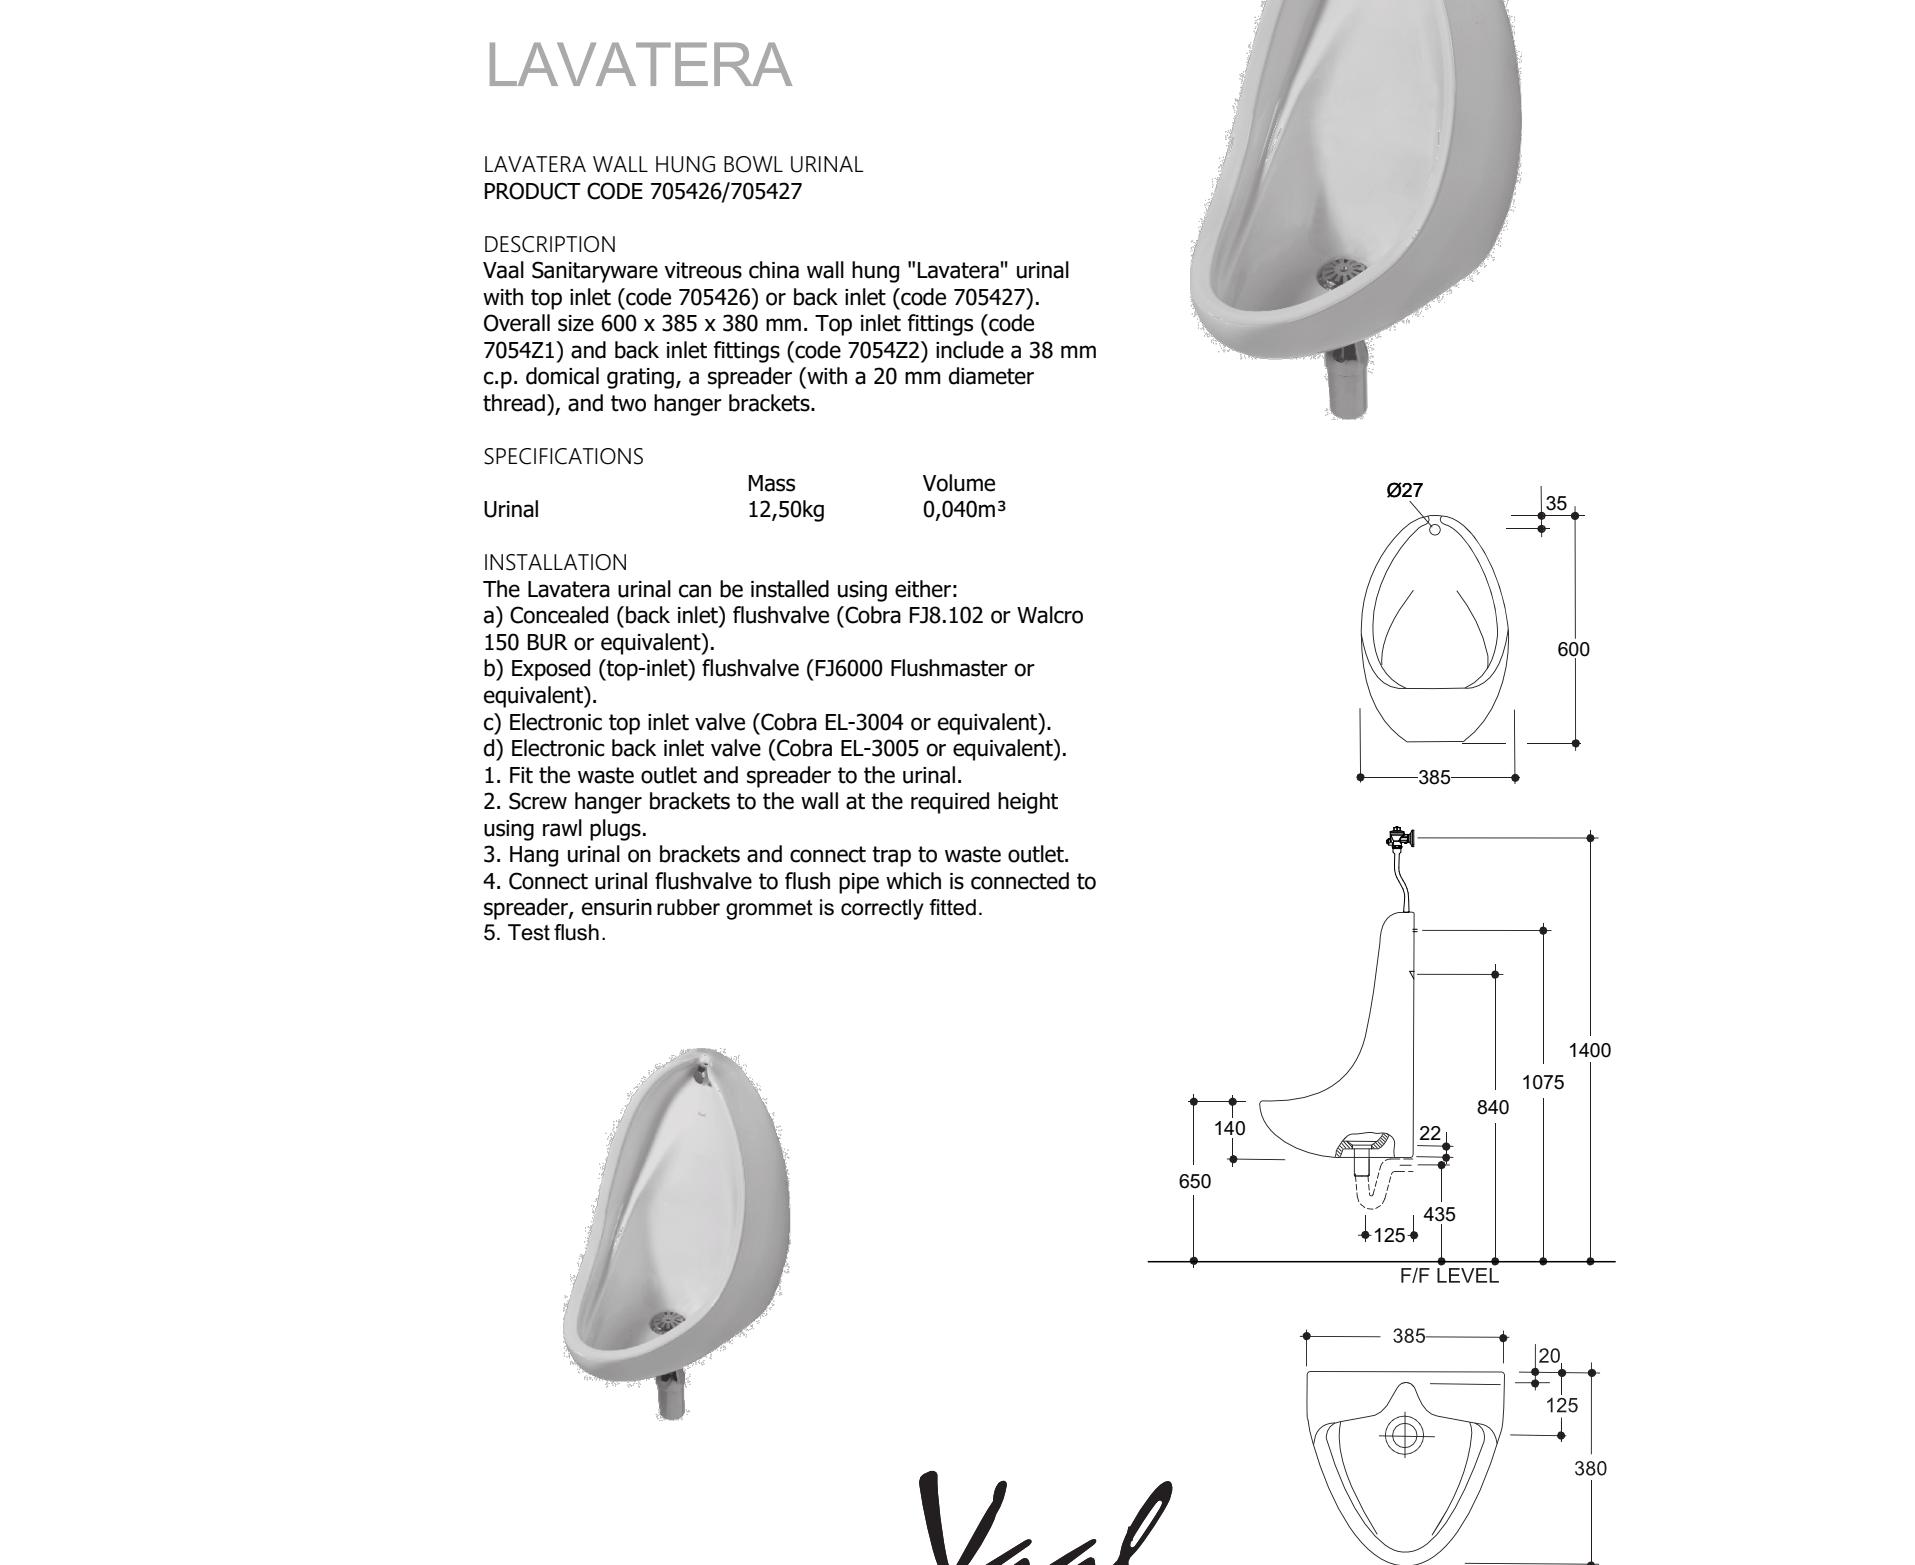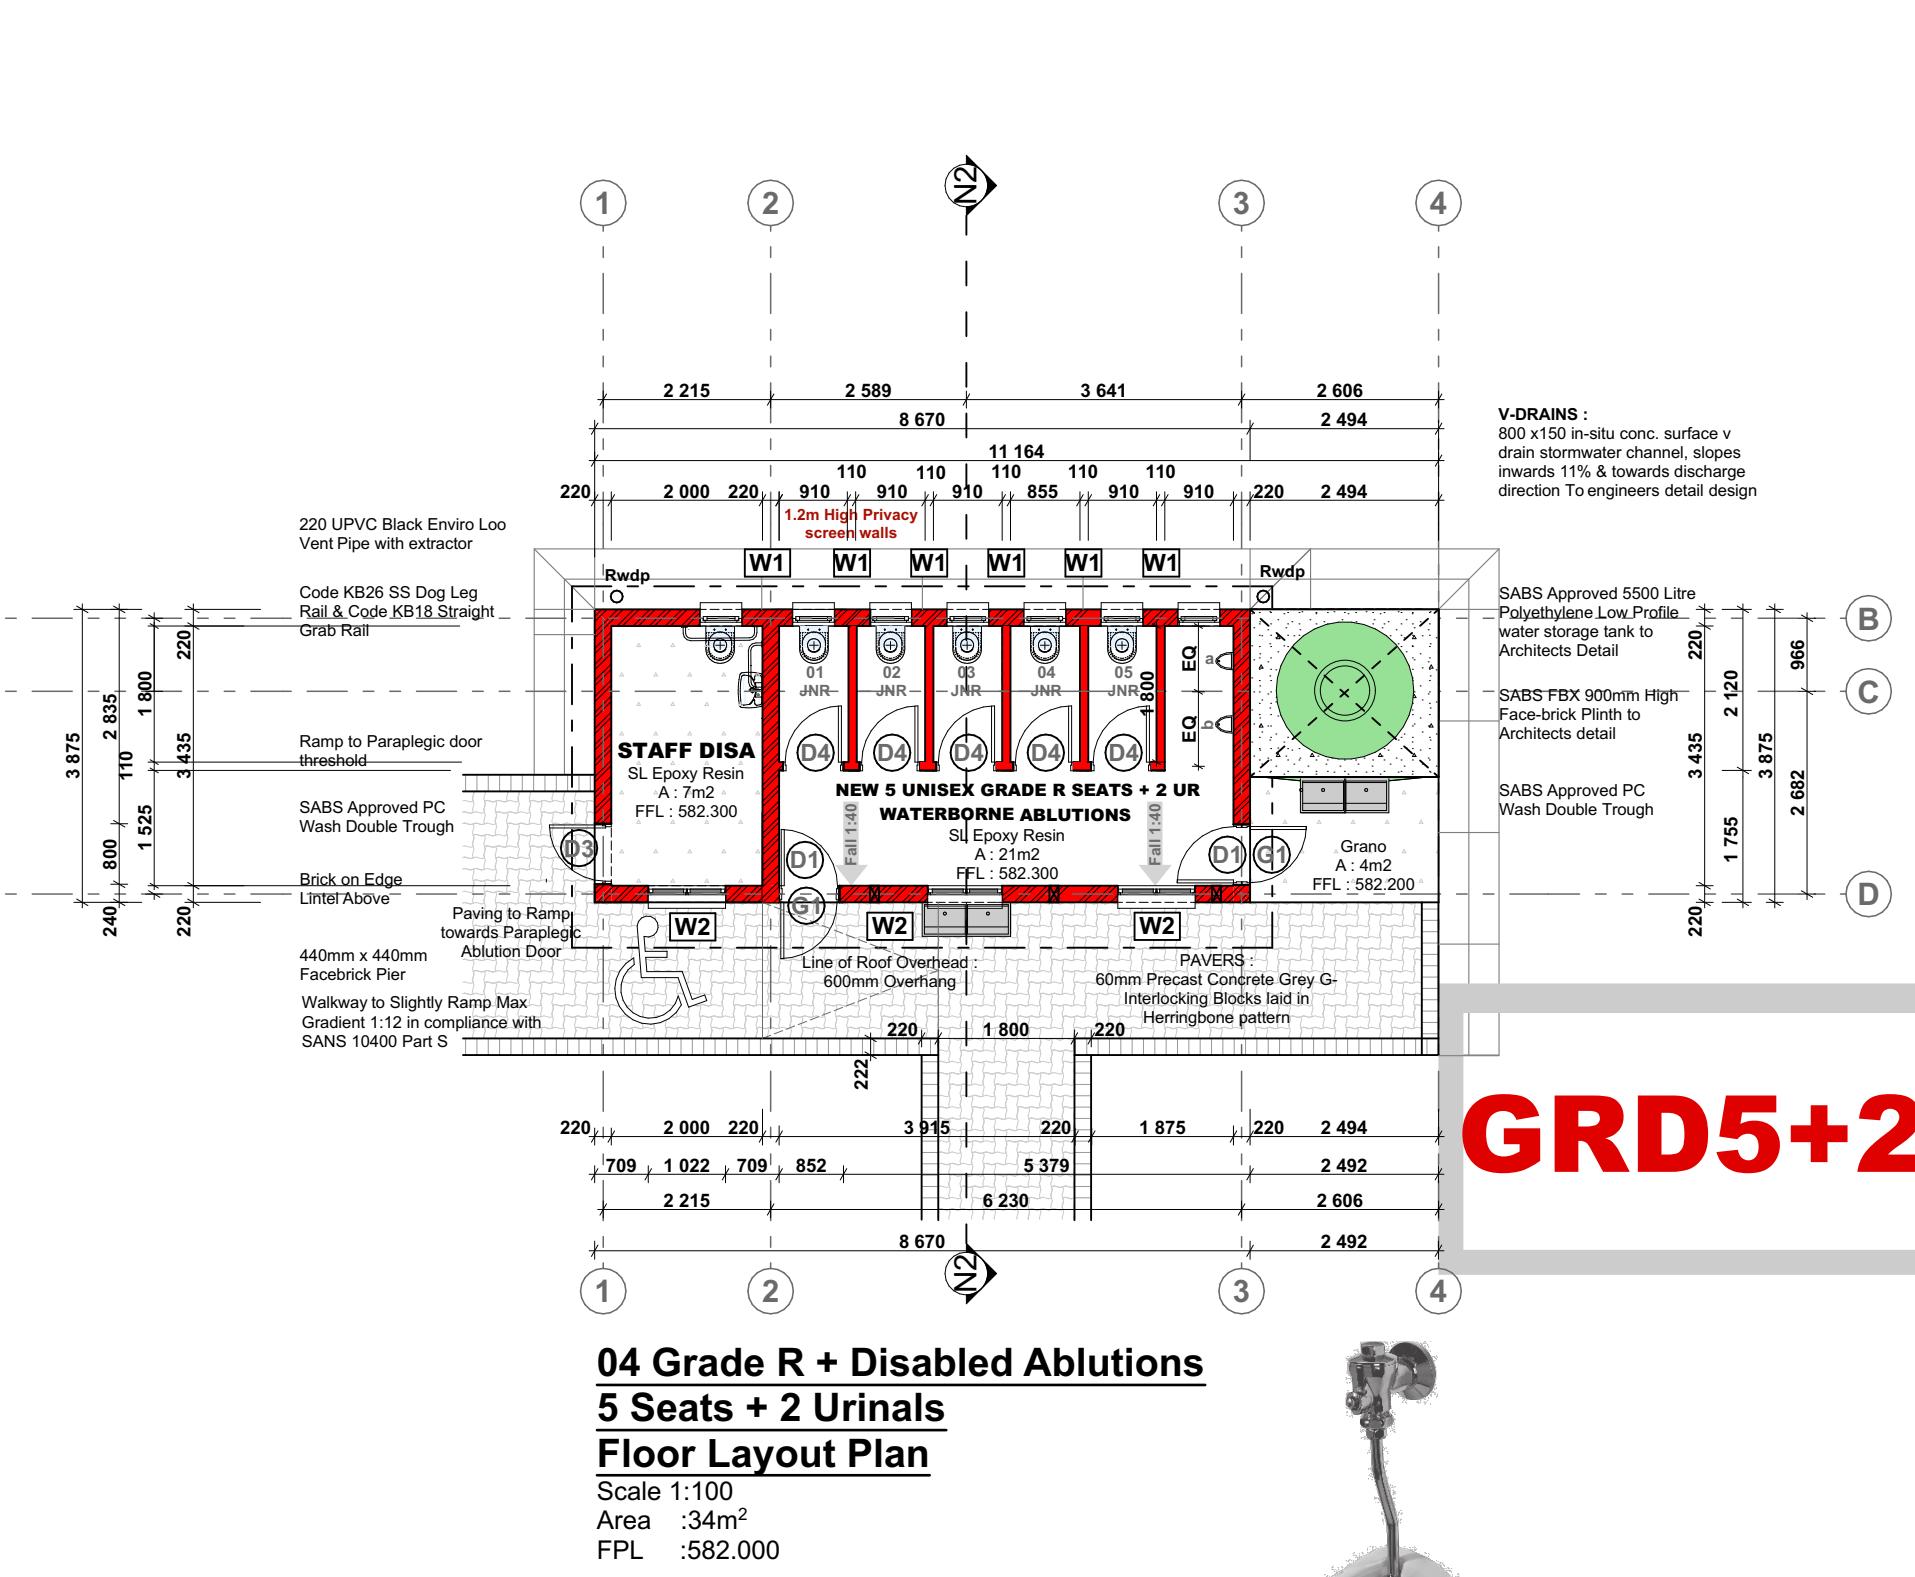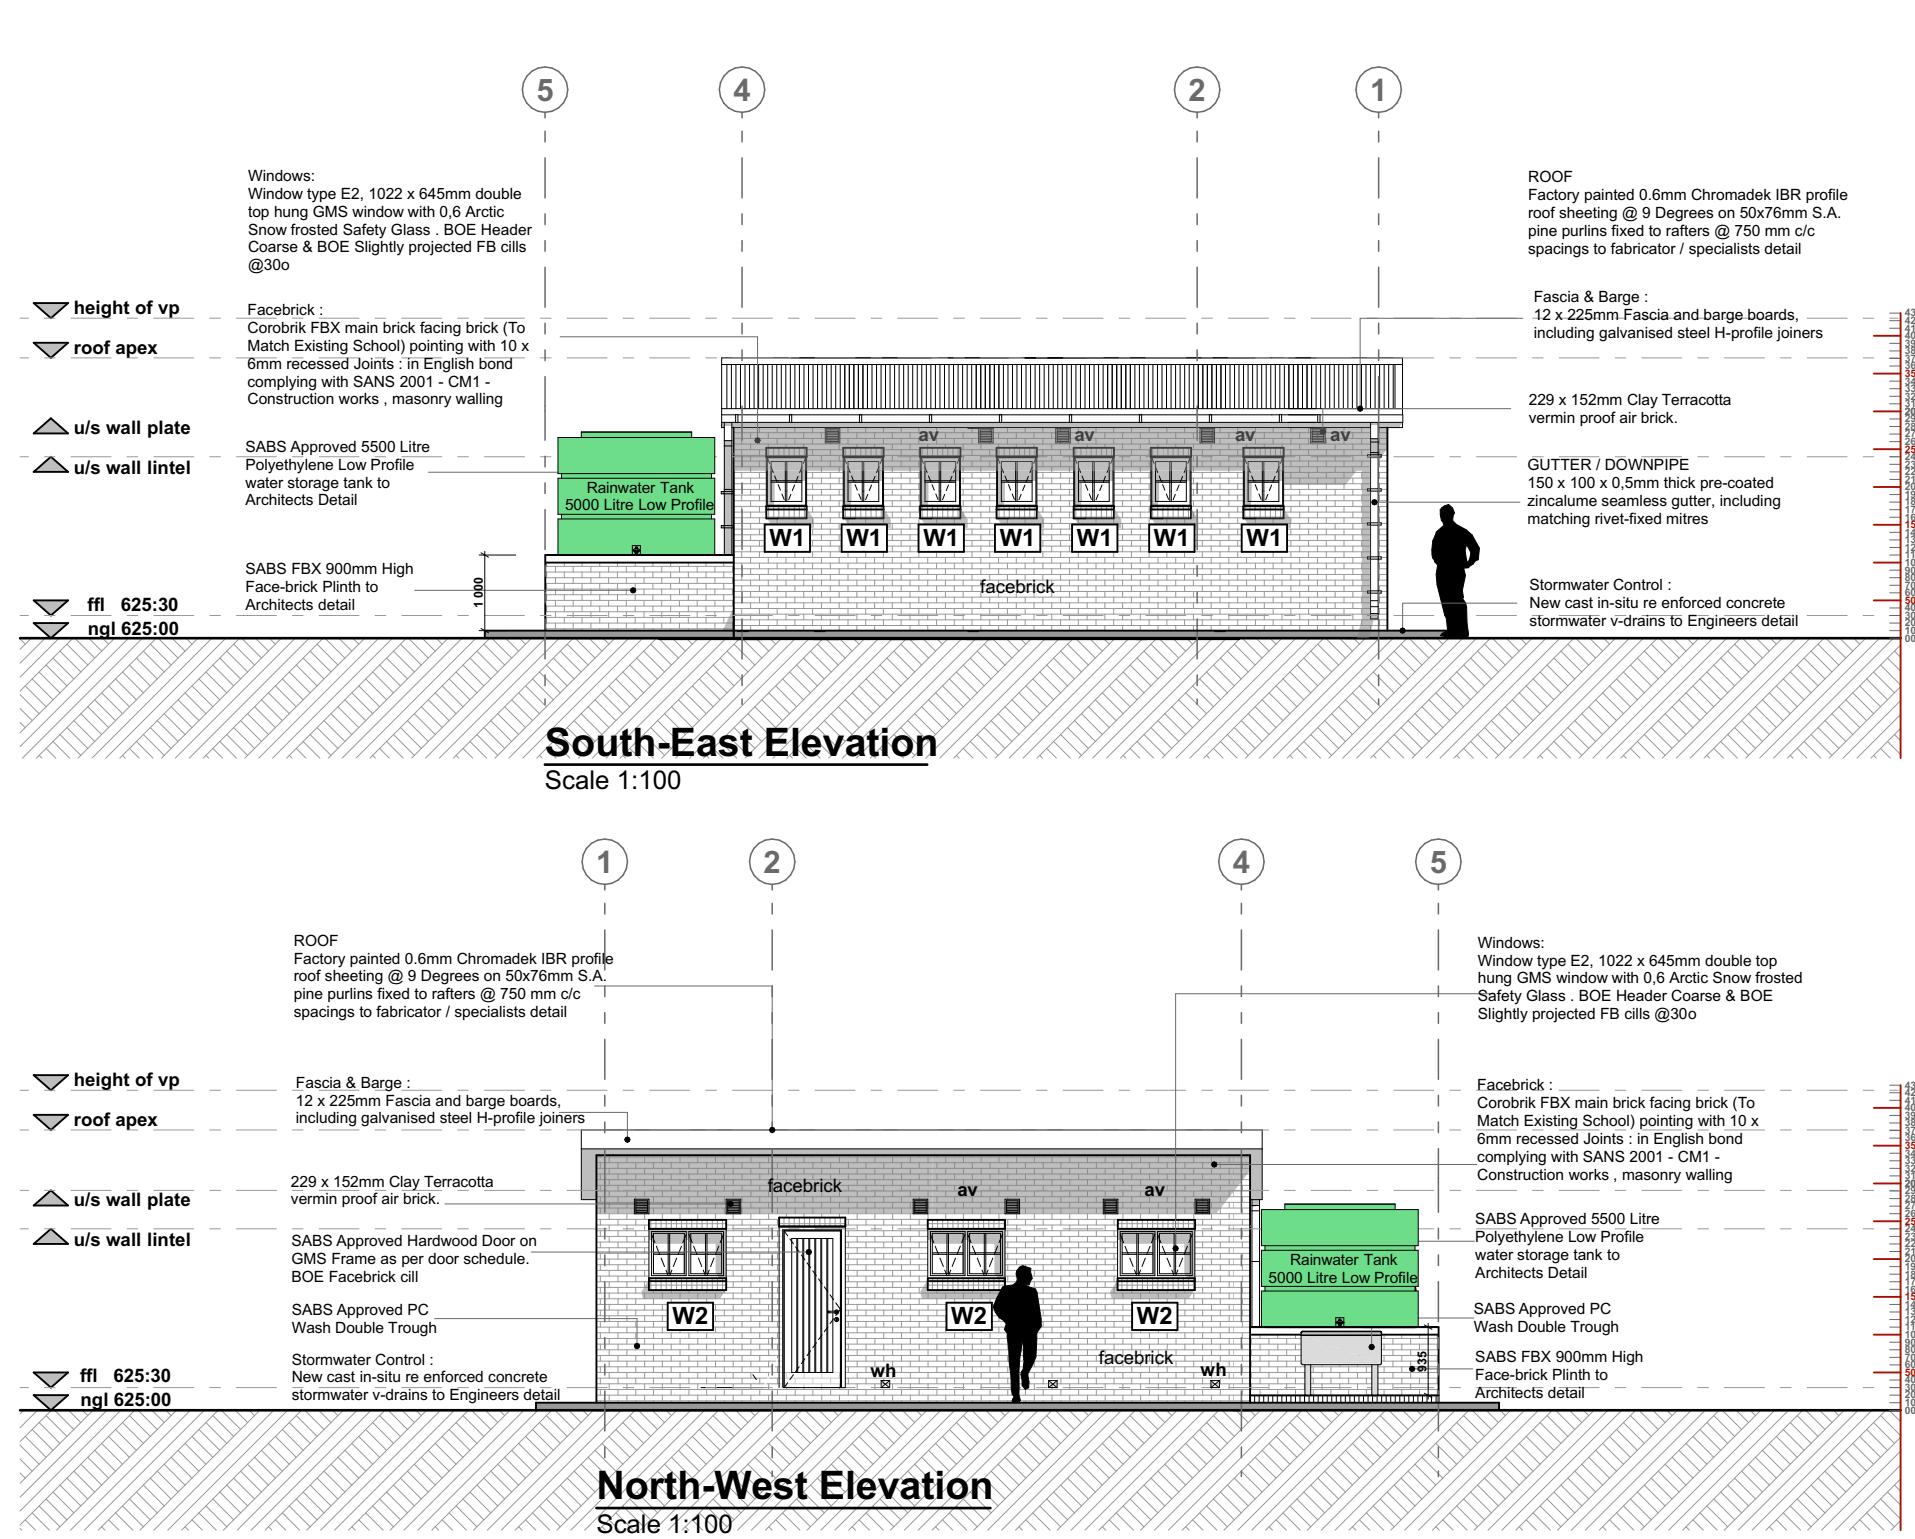

SANS 10400 & XA COMPLIANCE		OTHER APPROVALS		WATER SUPPLIER		SANITATION SEWER		SITE INFORMATION		STAGES		PROJECT TEAM	
CONDUCTANCE	Y N	Environmental Impact Assessment (EIA)	Y N	MUNICIPALITY	Yes No	MUNICIPALITY NAME		ERF NO.		SIPDM	SACAP	Mark with X	
SOLAR HEAT GAIN	Y N	South African Heritage Resource Agency (SAHRA)	Y N	BOREHOLE	Yes No	WATER USE LICENCE		COVERAGE		0			Competent Contact Person
GEOGRAPHICAL ZONE	Y N	Department of Water and Sanitation (DWS)	Y N	PRESSURE	Yes No			VILLAGE NAME		1			CONTACT No.
NBRs COMPLIANCE	Y N	South African National Roads Agency (SANRAL)	Y N	TANKS	Number	TOTAL CAPACITY		DISTRICT		2			REGISTRATION No.
SITE PLAN	Y N	Other	Y N	OTHER STORE	Yes No	SPECIFY BELOW		OTHER	Yes No	3	1		COMPANY NAME
OTHER DRAWINGS	Y N									4	2		Architect

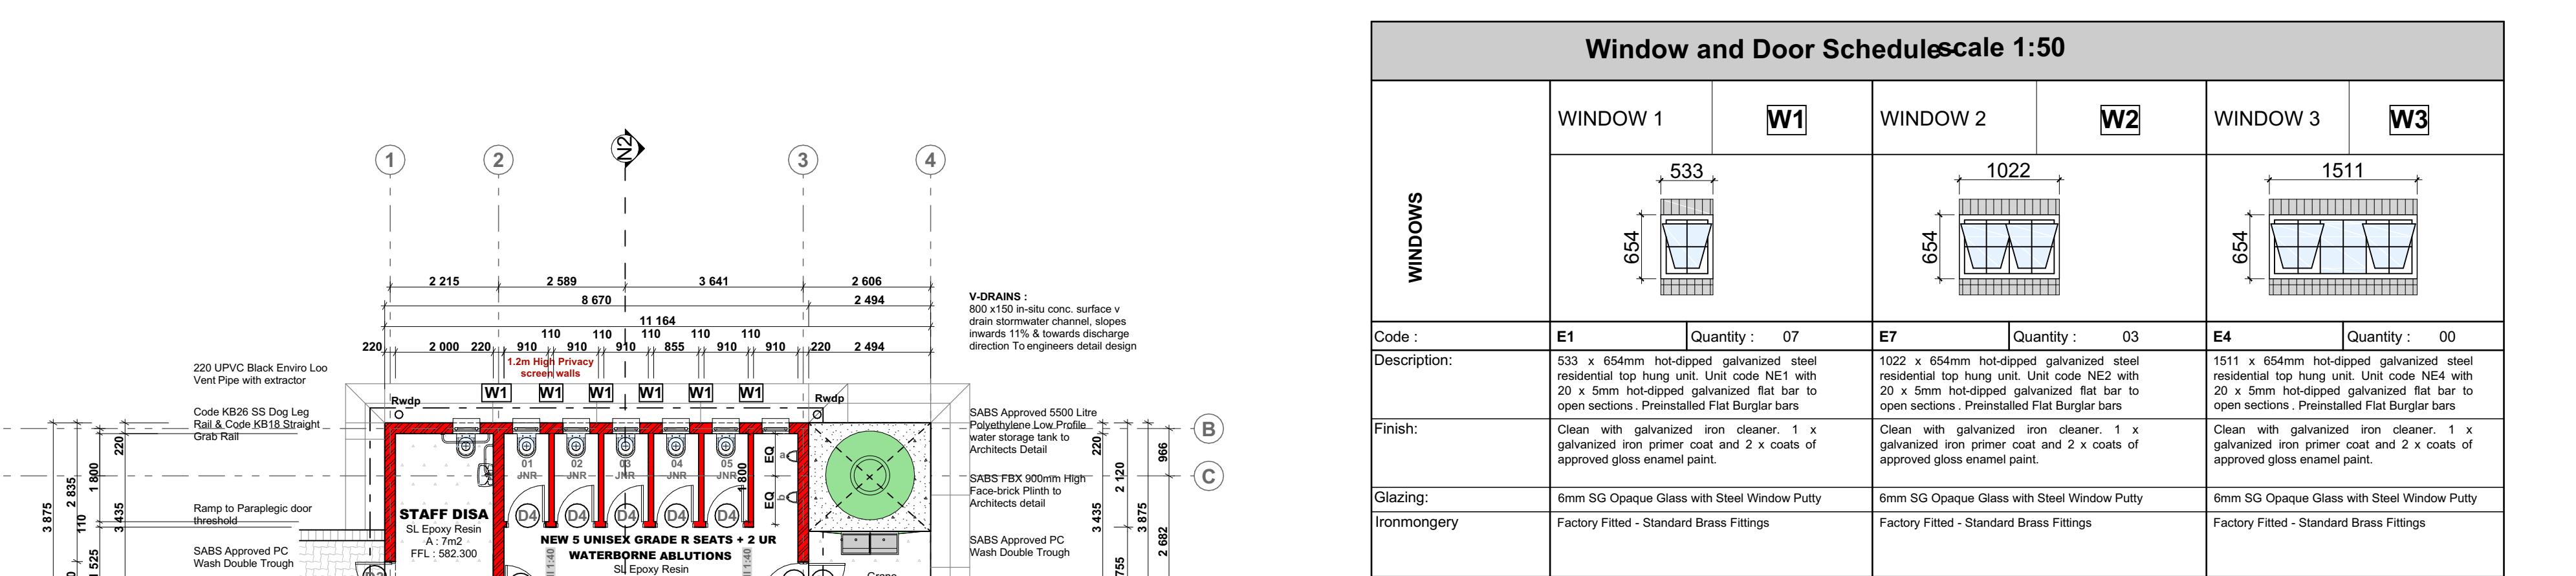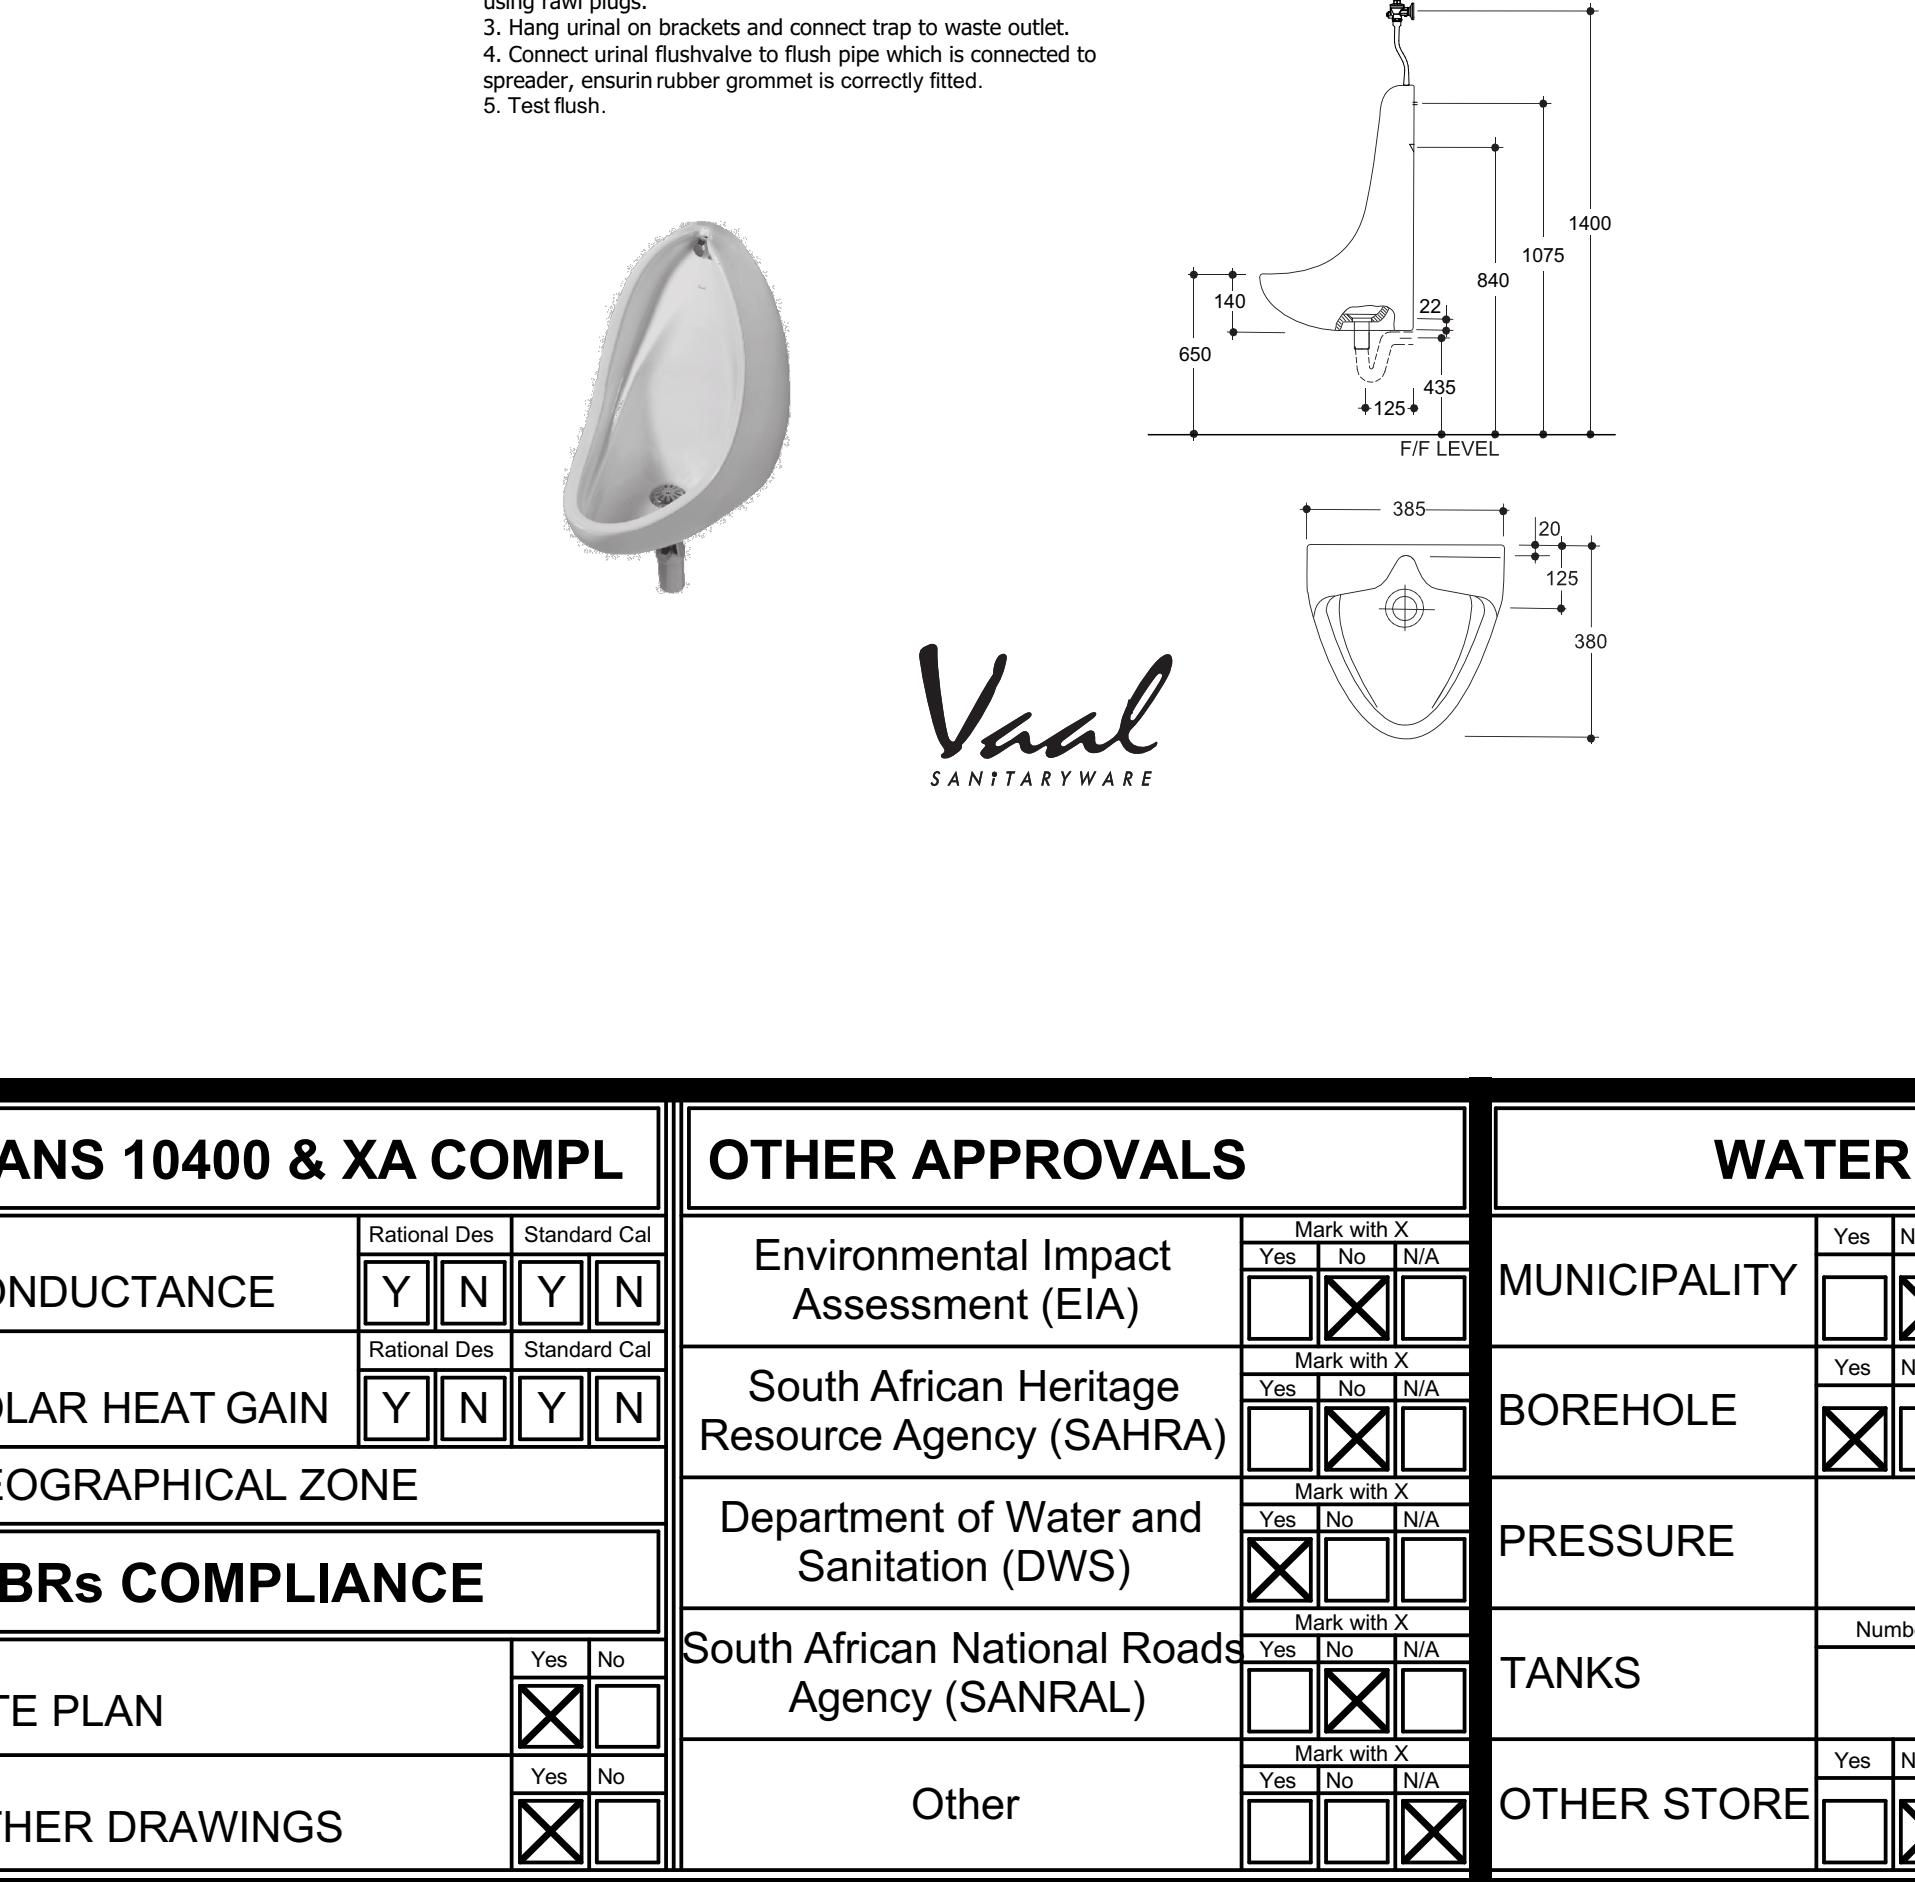

Section N2 - N2
Scale: 1:75

Section 2
Scale