

A


B

C



D

E

F

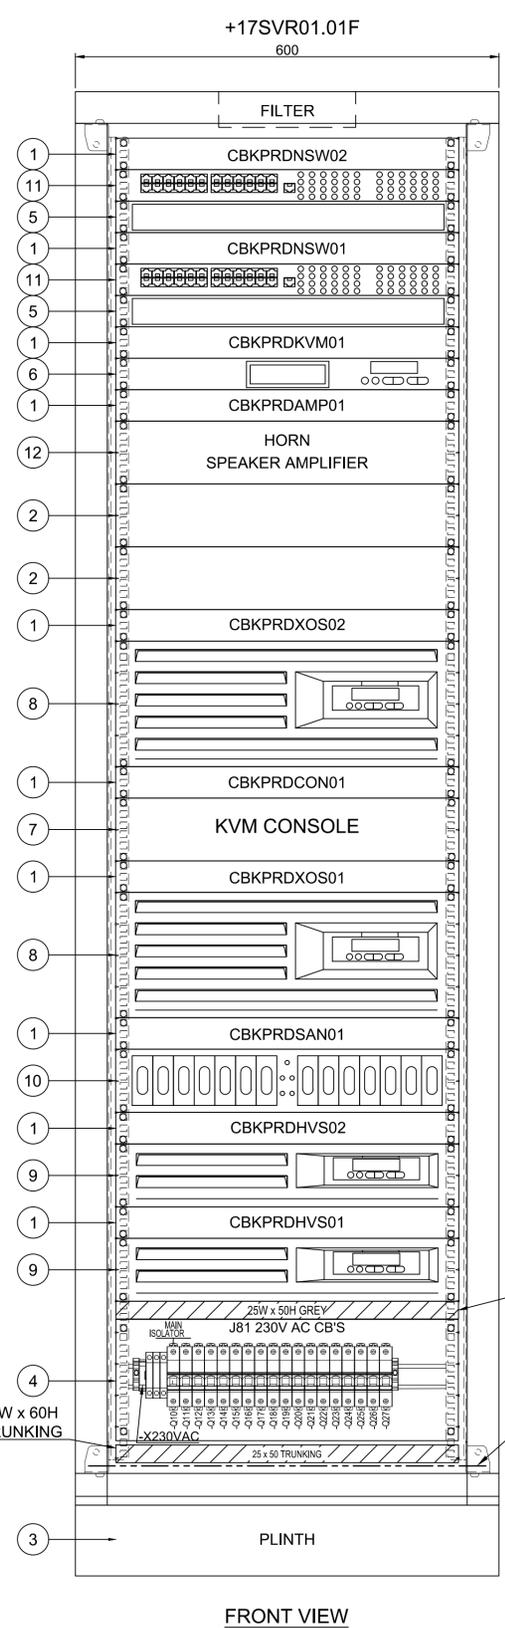

ITEM No	DESCRIPTION
1	1 U BLANKING PLATE
2	2 U BLANKING PLATE
3	PANEL PLINTH
4	DISTRIBUTION BOARD
5	BRUSH PANEL
6	KVM SWITCH
7	KVM CONSOLE
8	OPERATOR WORKSTATION
9	PRODUCTION HOST VIRTUAL SERVER
10	STORAGE ARRAY NETWORK
11	STACKED NETWORK SWITCHES
12	HORN SPEAKER AMPLIFIER
13	FAN UNITS

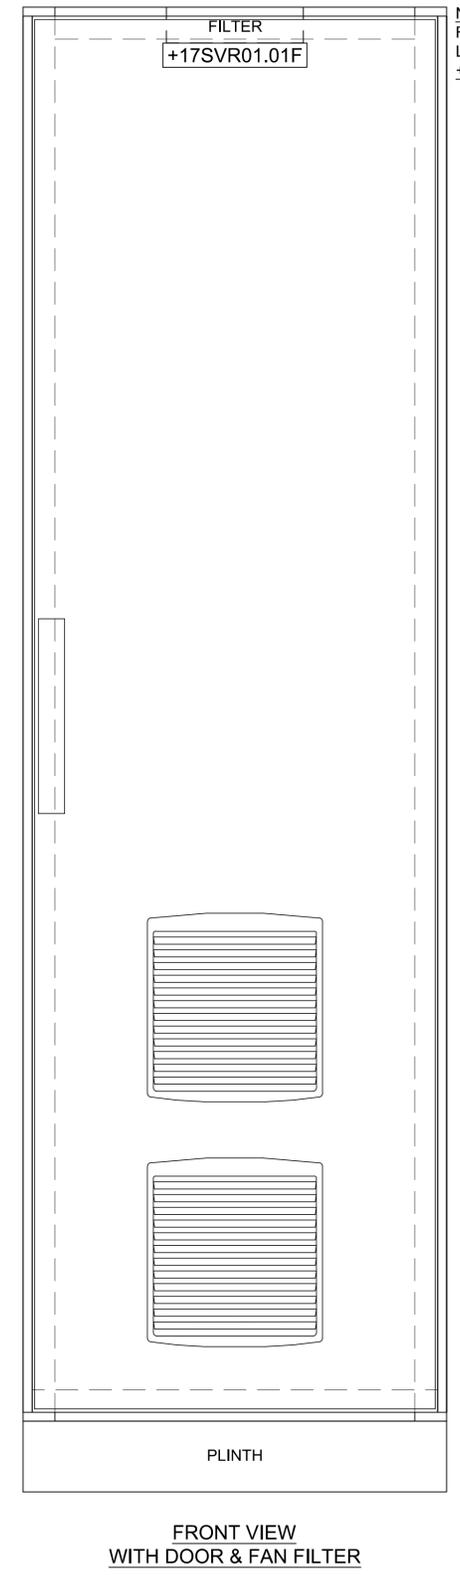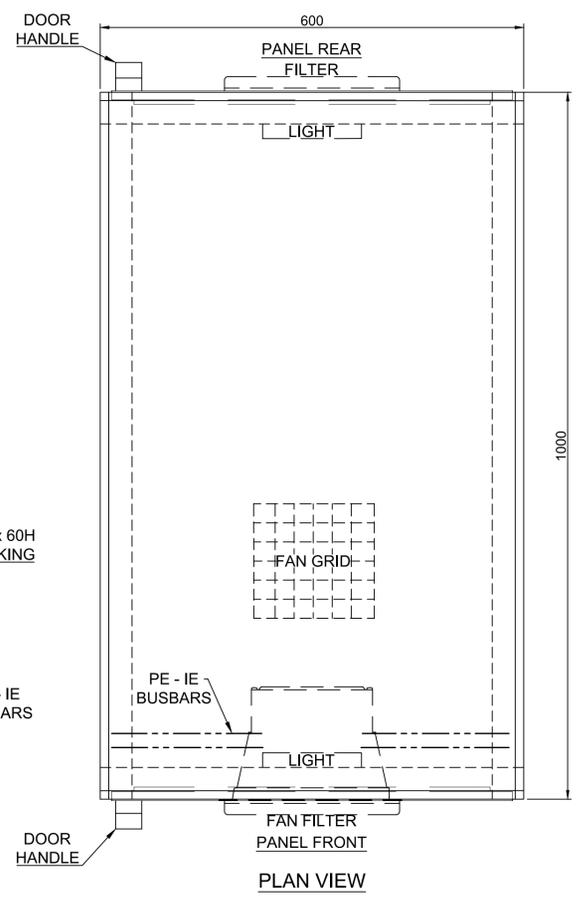

NOTE:
FOR REAR PANEL DOOR
LABEL MARKED AS
+17SVR01.01R

FRONT VIEW

PLAN VIEW

FRONT VIEW WITH DOOR & FAN FILTER

<p>THIS DRAWING WAS PREPARED FOR THE EXCLUSIVE USE OF TRANSNET PIPELINES ("CLIENT") AND IS ISSUED PURSUANT TO CONTRACT PYPW16/21/1750/01 BETWEEN CLIENT AND EOH MTHOMBO PTY LTD. ("EOH"). UNLESS OTHERWISE AGREED IN WRITING WITH CLIENT OR SPECIFIED ON THIS DRAWING, EOH DOES NOT ACCEPT AND DISCLAIMS ANY AND ALL LIABILITY OR RESPONSIBILITY ARISING FROM ANY USE OF OR RELIANCE ON THIS DRAWING BY ANY THIRD PARTY OR ANY MODIFICATION OR MISUSE OF THIS DRAWING BY CLIENT.</p>								<p>DESIGNER RAYNO POWELL RP 28-03-2019</p>									
								<p>RESP. ENG. PAULO DE SOUSA GOMES PDSG 28-03-2019</p>									
								<p>PROJ. MANAGER ALEXEI SEDLOV AS 28-03-2019</p>				<p>TITLE CBK STATION SERVER PANEL LAYOUT FRONT VIEW [=17SVR01]</p>					
								<p>CLIENT CHRIS MURRAY CM 17-07-2019</p>									
<p>E354086-00000-271-066-0003 CBK SERVER HEAT LOAD CALCULATIONS</p>		<p>E354086-00017-271-288-0008 SINGLE LINE DIAGRAM</p>		<p>04 REVISED AS BUILT</p>		<p>LD KB 28-06-2021</p>		<p>ROLE NAME SIGNATURE DATE</p>		<p>SCALE 1:5</p>		<p>TPL DWG. No. E354086-00017-271-272-00005</p>		<p>SHEET 1 OF 2</p>		<p>REV 04</p>	
<p>DRAWING No. DRAWING TITLE</p>				<p>No. DESCRIPTION</p>				<p>BY CHK'D DATE</p>				<p>DRAWING APPROVAL STATUS:</p>					
<p>REFERENCE DRAWINGS</p>				<p>REVISIONS</p>													