
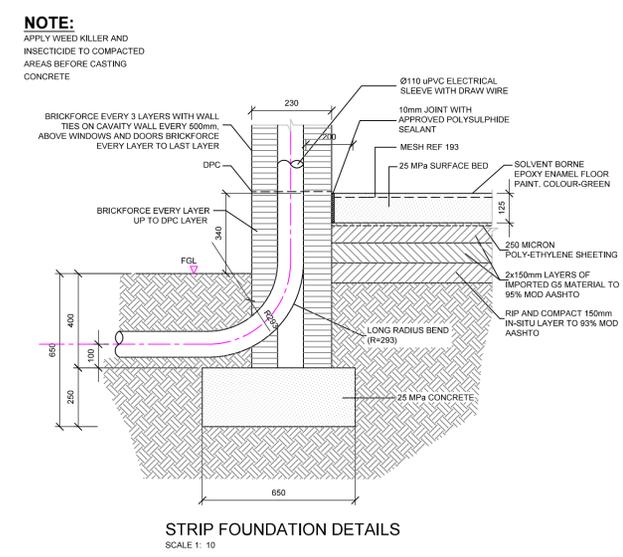
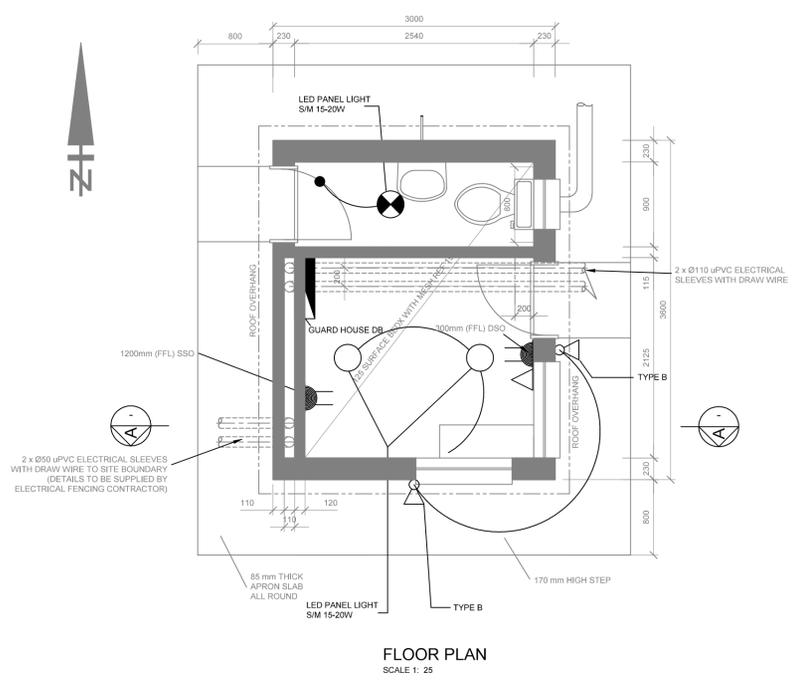
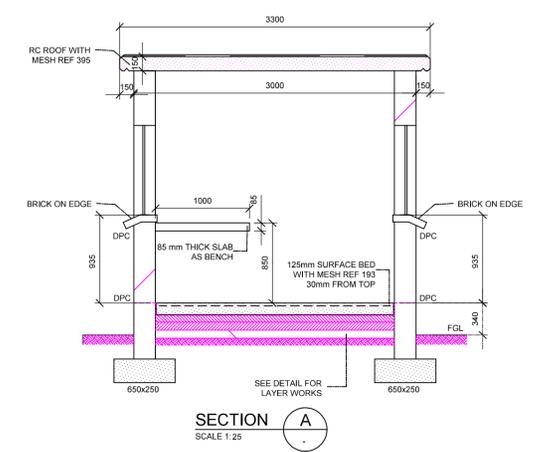
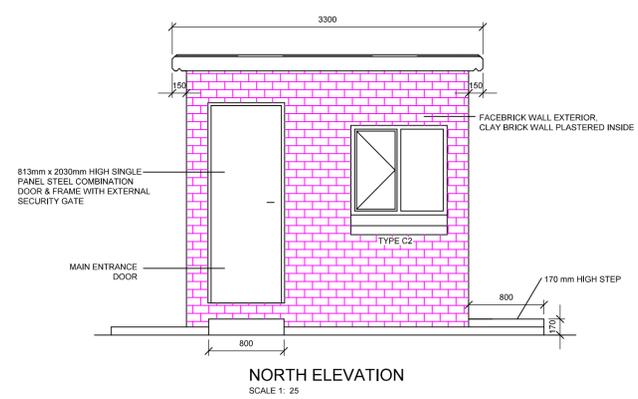


ELECTRICAL LEGEND	
	DISTRIBUTION BOARD
	TELEPHONE OUTLET (BLANK)
	DOUBLE SOCKET OUTLET (FLUSH)
	1 x 20W CEILING MOUNTED BULKHEAD
	WALL MOUNTED BULKHEAD
	MINIATURE FLOODLIGHT
	LIGHT SWITCH
	WALL MOUNTED PHOTOCELL
	2 x 20W CFL BULKHEAD

NOTE: ALL WIRING TO BE INSTALLED IN CONDUIT CHASED INTO WALLS

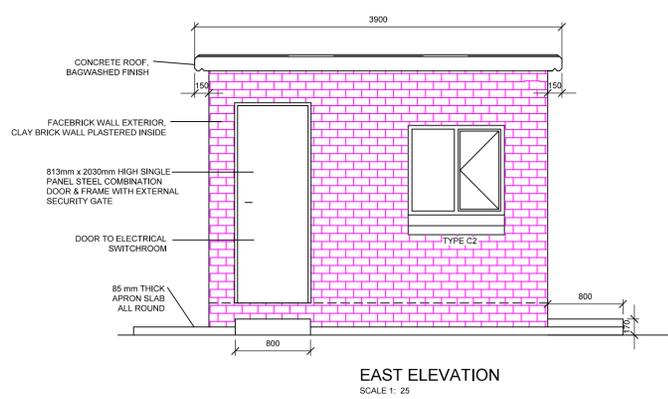

KEY PLAN
SCALE: NTS

CONSULTING ENGINEERS TRI-M CONSULTING ENGINEERS MICHELANGELO TOWER SUITE 2307, MAUDE STREET SANDTON, JOHANNESBURG	DESIGNED	P. S. Botha	
	DRAWN	J. Nel	
	CHECKED	P. S. Botha	
	APPROVED BY:		
	ECOSA REG. No.	730401	
CLIENT POSTAL ADDRESS: P O Box 61542 MATSHALLTOWN 2107	CHECKED		
		SIGNATURE	DATE

PHYSICAL ADDRESS:
**65 NTEMI PILISO STREET
 NEWTOWN
 JOHANNESBURG**

TEL: (011) 688-1400
 FAX: (011) 688-1529



**FOREST HILL WATER SUPPLY
 NEW WATER TOWER & PUMP STATION**

GUARD HOUSE

SURVEY INFORMATION		APPROVAL BY JW DEPOT		SCALE	AMENDMENTS	
PROJECT SURVEYOR:		CHECKED		1: 50, 1: 25	REV:	DESCRIPTION
DATE:		APPROVED BY:				DATE:
		SIGNATURE	DATE			
CCTV INFORMATION		APPROVAL BY JW PLANNING				
CCTV COMPANY:		CHECKED				
DATE:		APPROVED BY:				
		SIGNATURE	DATE			

PROJECT No. **JW14402** DRAWING No. **P03** REV. **0**

SHEET **3** OF **3**

ORIGINAL PAGE SIZE
FILE No.