
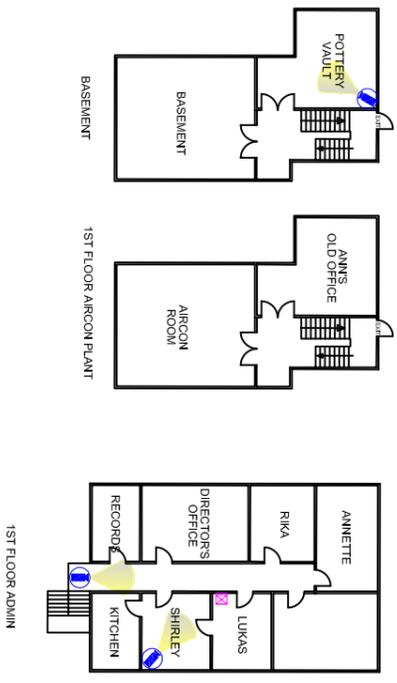


DRAWING NUMBER: REVISION:

DATA LEGEND		
SYMBOL	QTY	DESCRIPTION
	24	4MP DOME 2.8MM LENS + IR
	10	8MP DOME 2.8MM LENS + IR
	11	4MP BULLET 4MM LENS 30MAR
	4	4MP BULLET 2.8-12 VERIFOCAL LENS 50M-HR
	2	DATA PATCH RACK

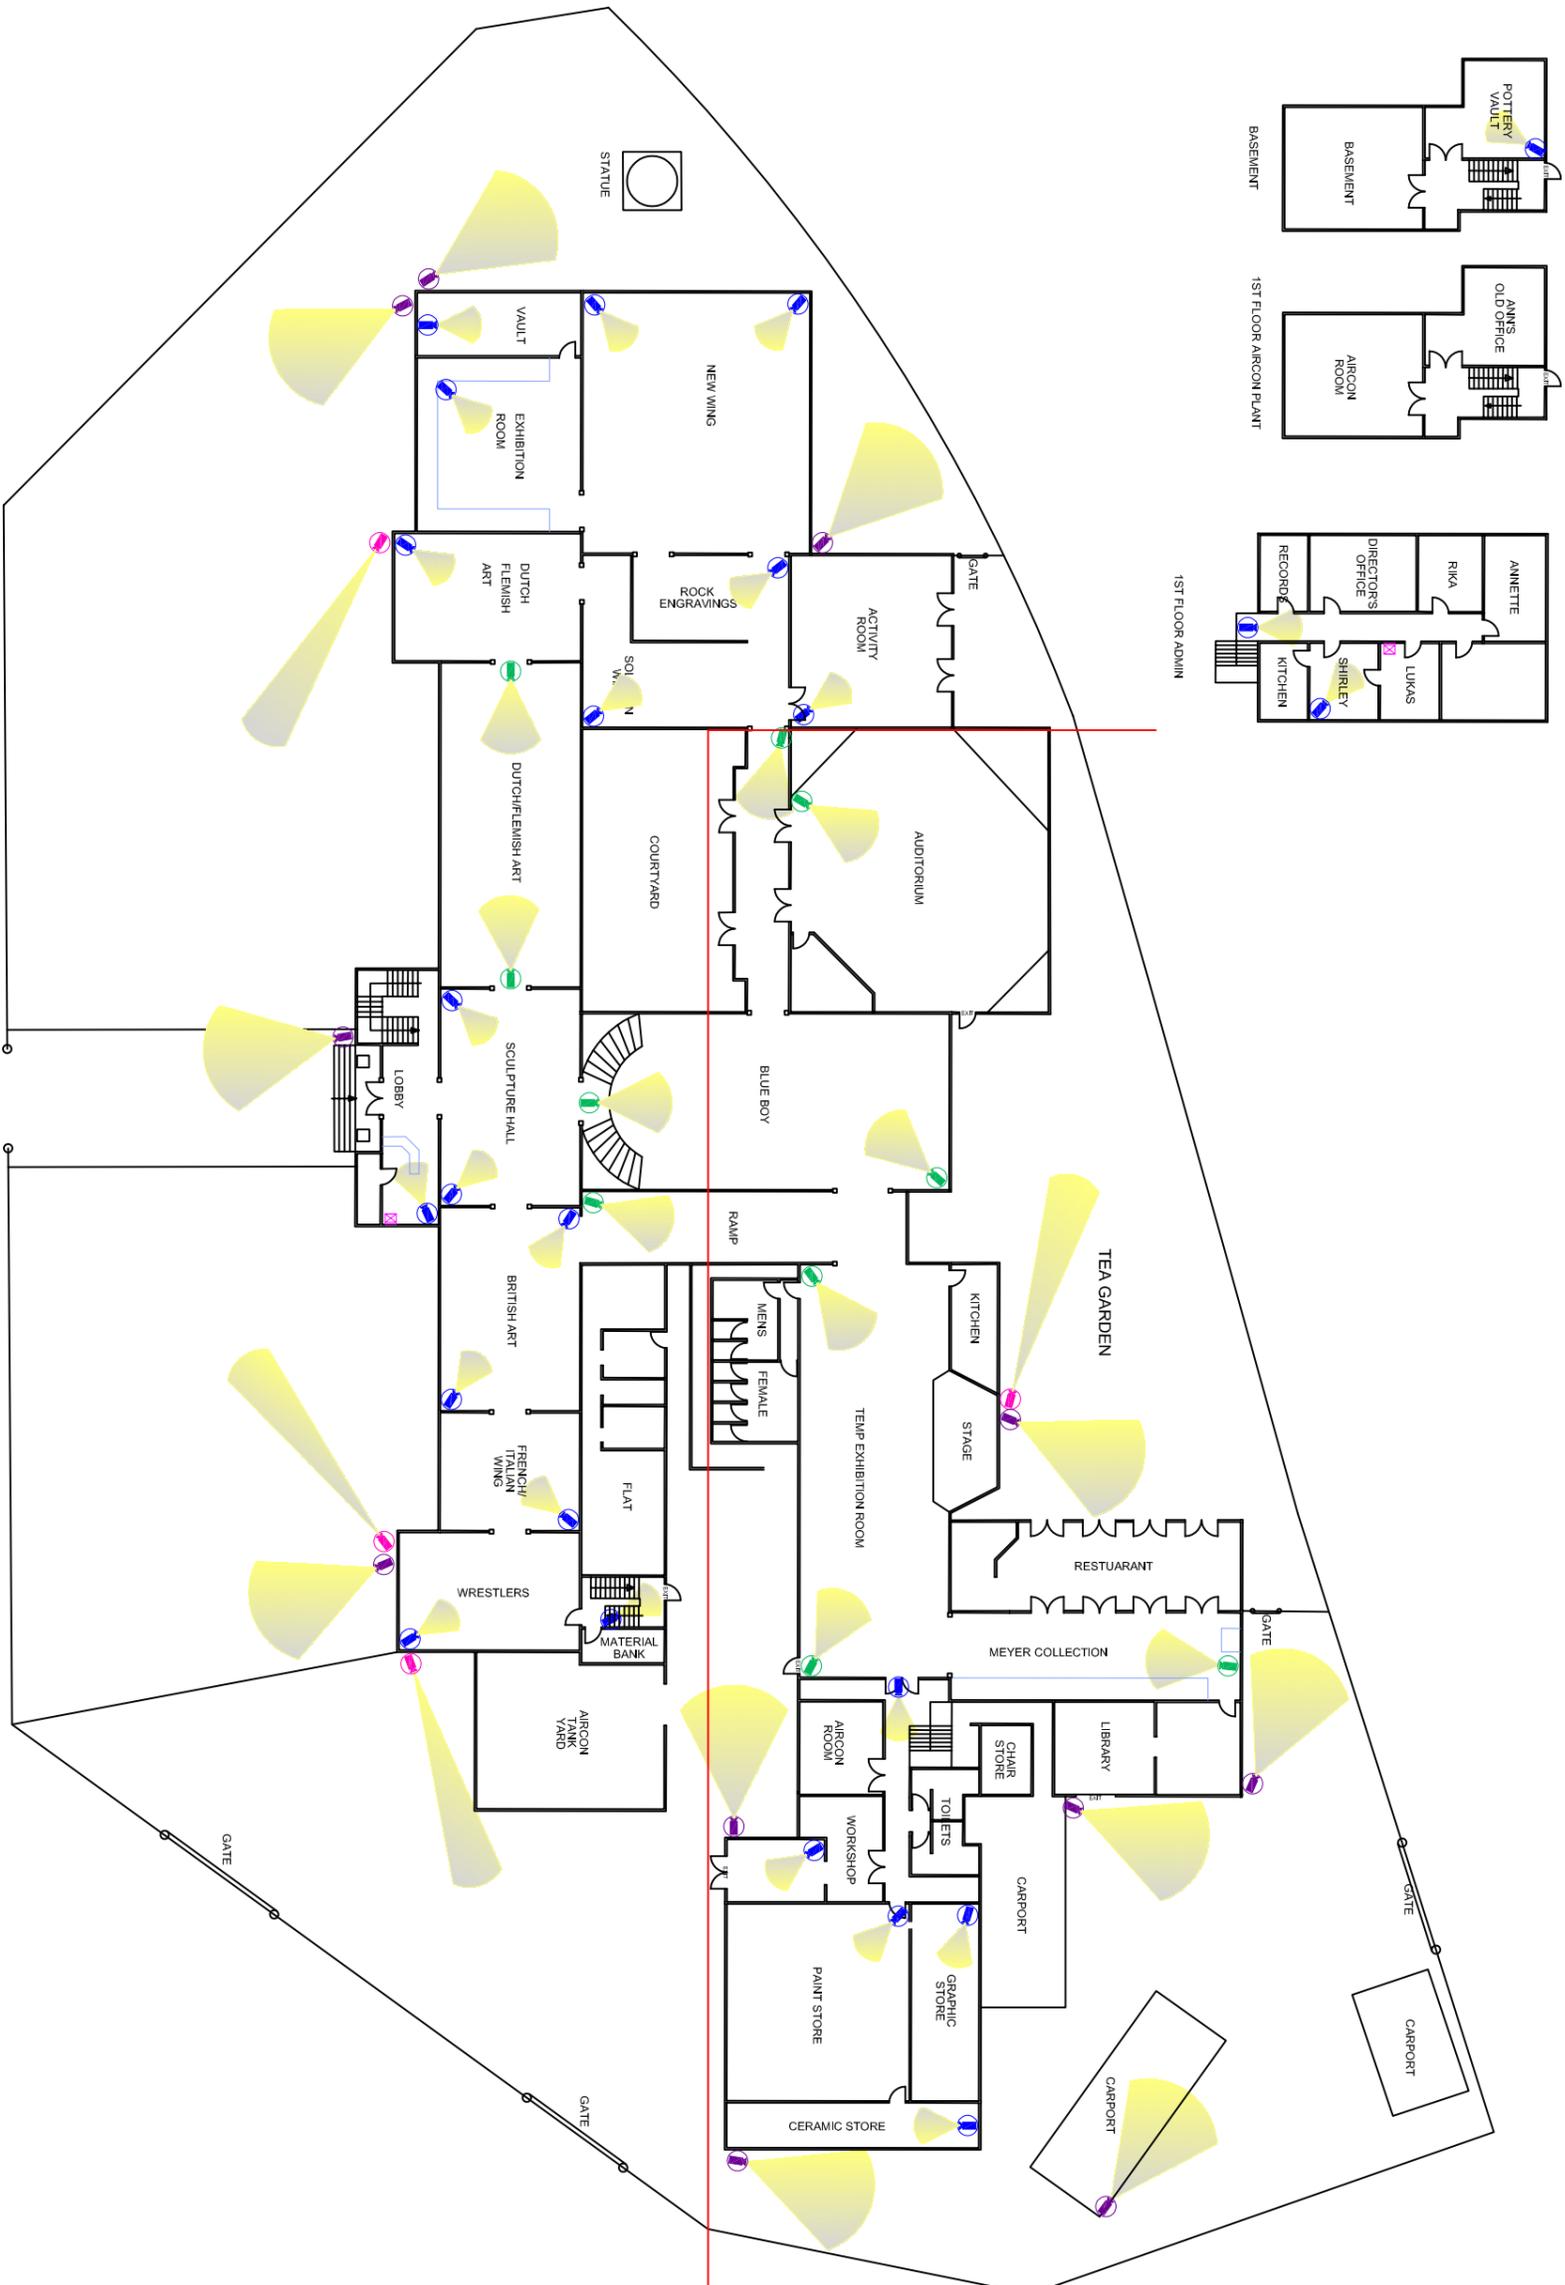

REV	DATE	DESCRIPTION	BY
00	03-03-2020	NEW DRAWING	G SMIT

INTERCONNECT SYSTEMS
Connectivity Solutions



1039 CLIFTON AVENUE
LYTTELTON MANOR, 0188
TEL: (012) 664 1500

POSTNET SUIT #282
PRIVATE BAG 1028
LYTTELTON, 0140

PROJECT: WILLIAM HUMPHREYS ART GALLERY
CCTV PROJECT

DETAILS:
WILLIAM HUMPHREYS ART GALLERY
1 CULLINUN CRES, CIVIC CENTRE
KIMBERLEY
PROPOSED CCTV LAYOUT

DRAWN: G SMIT
CHECKED: G SMIT
DATE: 03-03-2020
SCALE: A3
NTS

DRAWING NUMBER: 2020-GS-201-CC01
REV: 00

PROPOSED CCTV LAYOUT