


- Notes**
- 1) All dimensions in meters (m) unless specified
 - 2) Red Line indicates 95mm² cable
 - 3) Pink Line indicates 16mm² cable

SENIOR ENGINEER (ELECTRICAL)	SIGNATURE	DATE
SENIOR ENGINEER (CIVIL)	SIGNATURE	DATE
PORT ENGINEER	SIGNATURE	DATE
PORT ENGINEER ROOM 705 NPA HOUSE PORT OF CAPE TOWN P.O. BOX 4245 TEL: 021 449 6173 FAX: 021 449 6171		
delivering on our commitment to you national parts authorities		


PORT OF CAPE TOWN

Culenborg
Perimeter Lighting
Electrical Kiosks -
Single Line Diagrams


DRAWN	G Dawood	CHECKED	M Raven
SCALE	NTS	PAGE SIZE	A3
No. TBH.106. R9-1			
DATE	03/11/2023	SHEET	02
CAD. REF.		AMENDMENT	
FILE REF.			

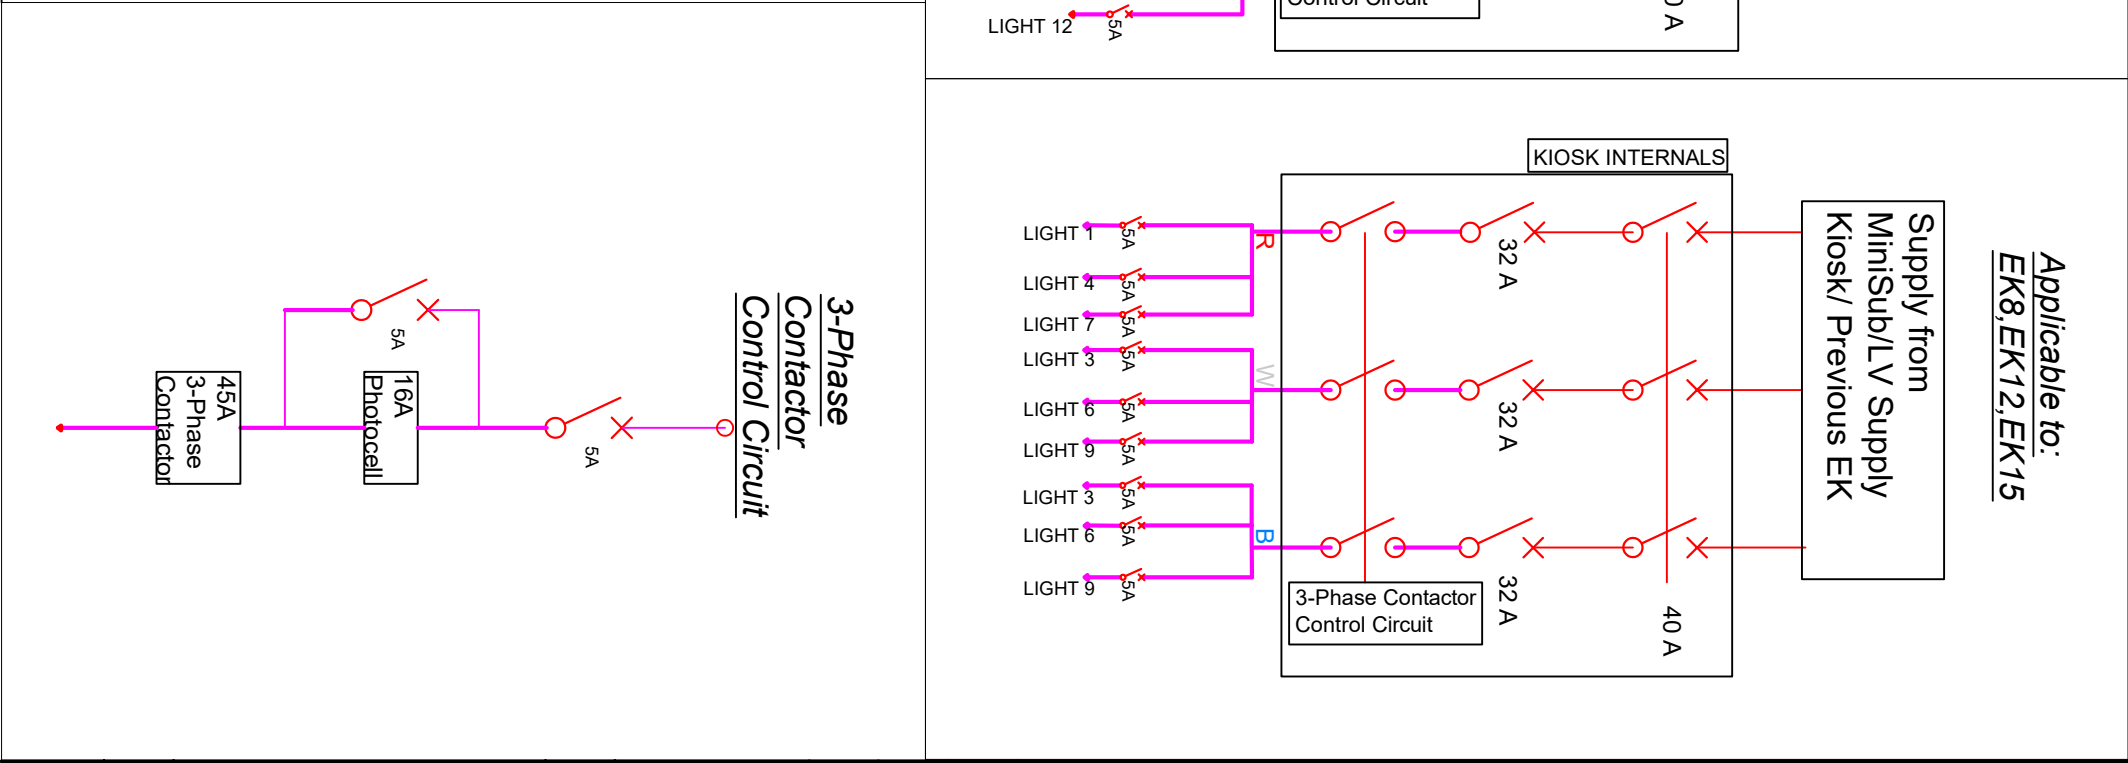

Applicable to:
EK3,EK5

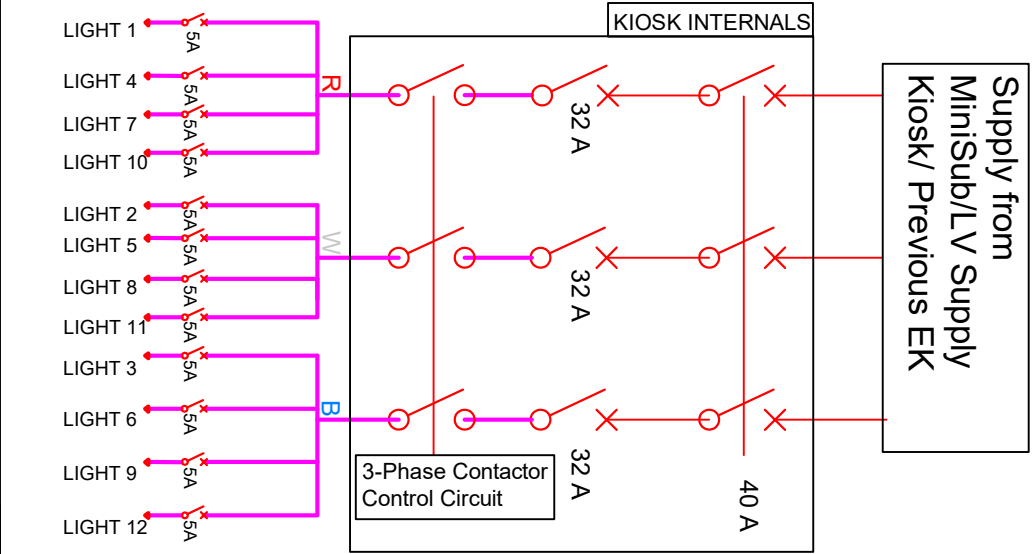

Applicable to:
EK14

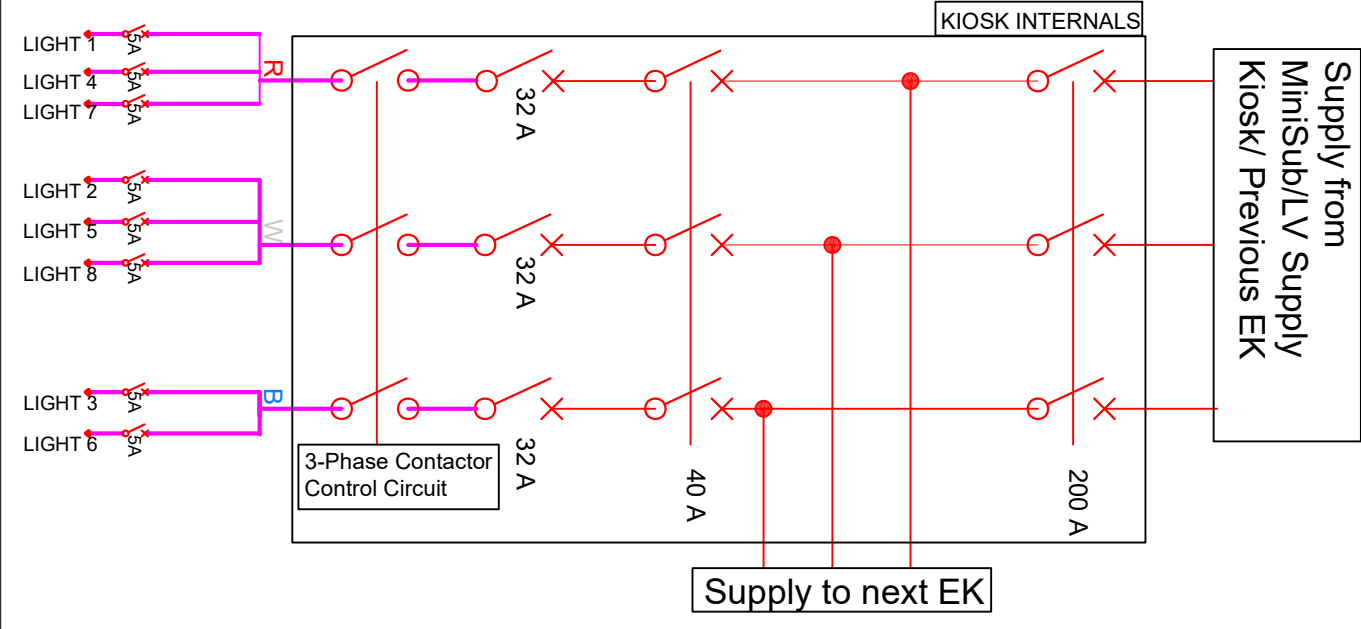

Applicable to:
EK1,EK2,EK4,EK6,
EK7,EK9,EK10,EK11,
EK13

