


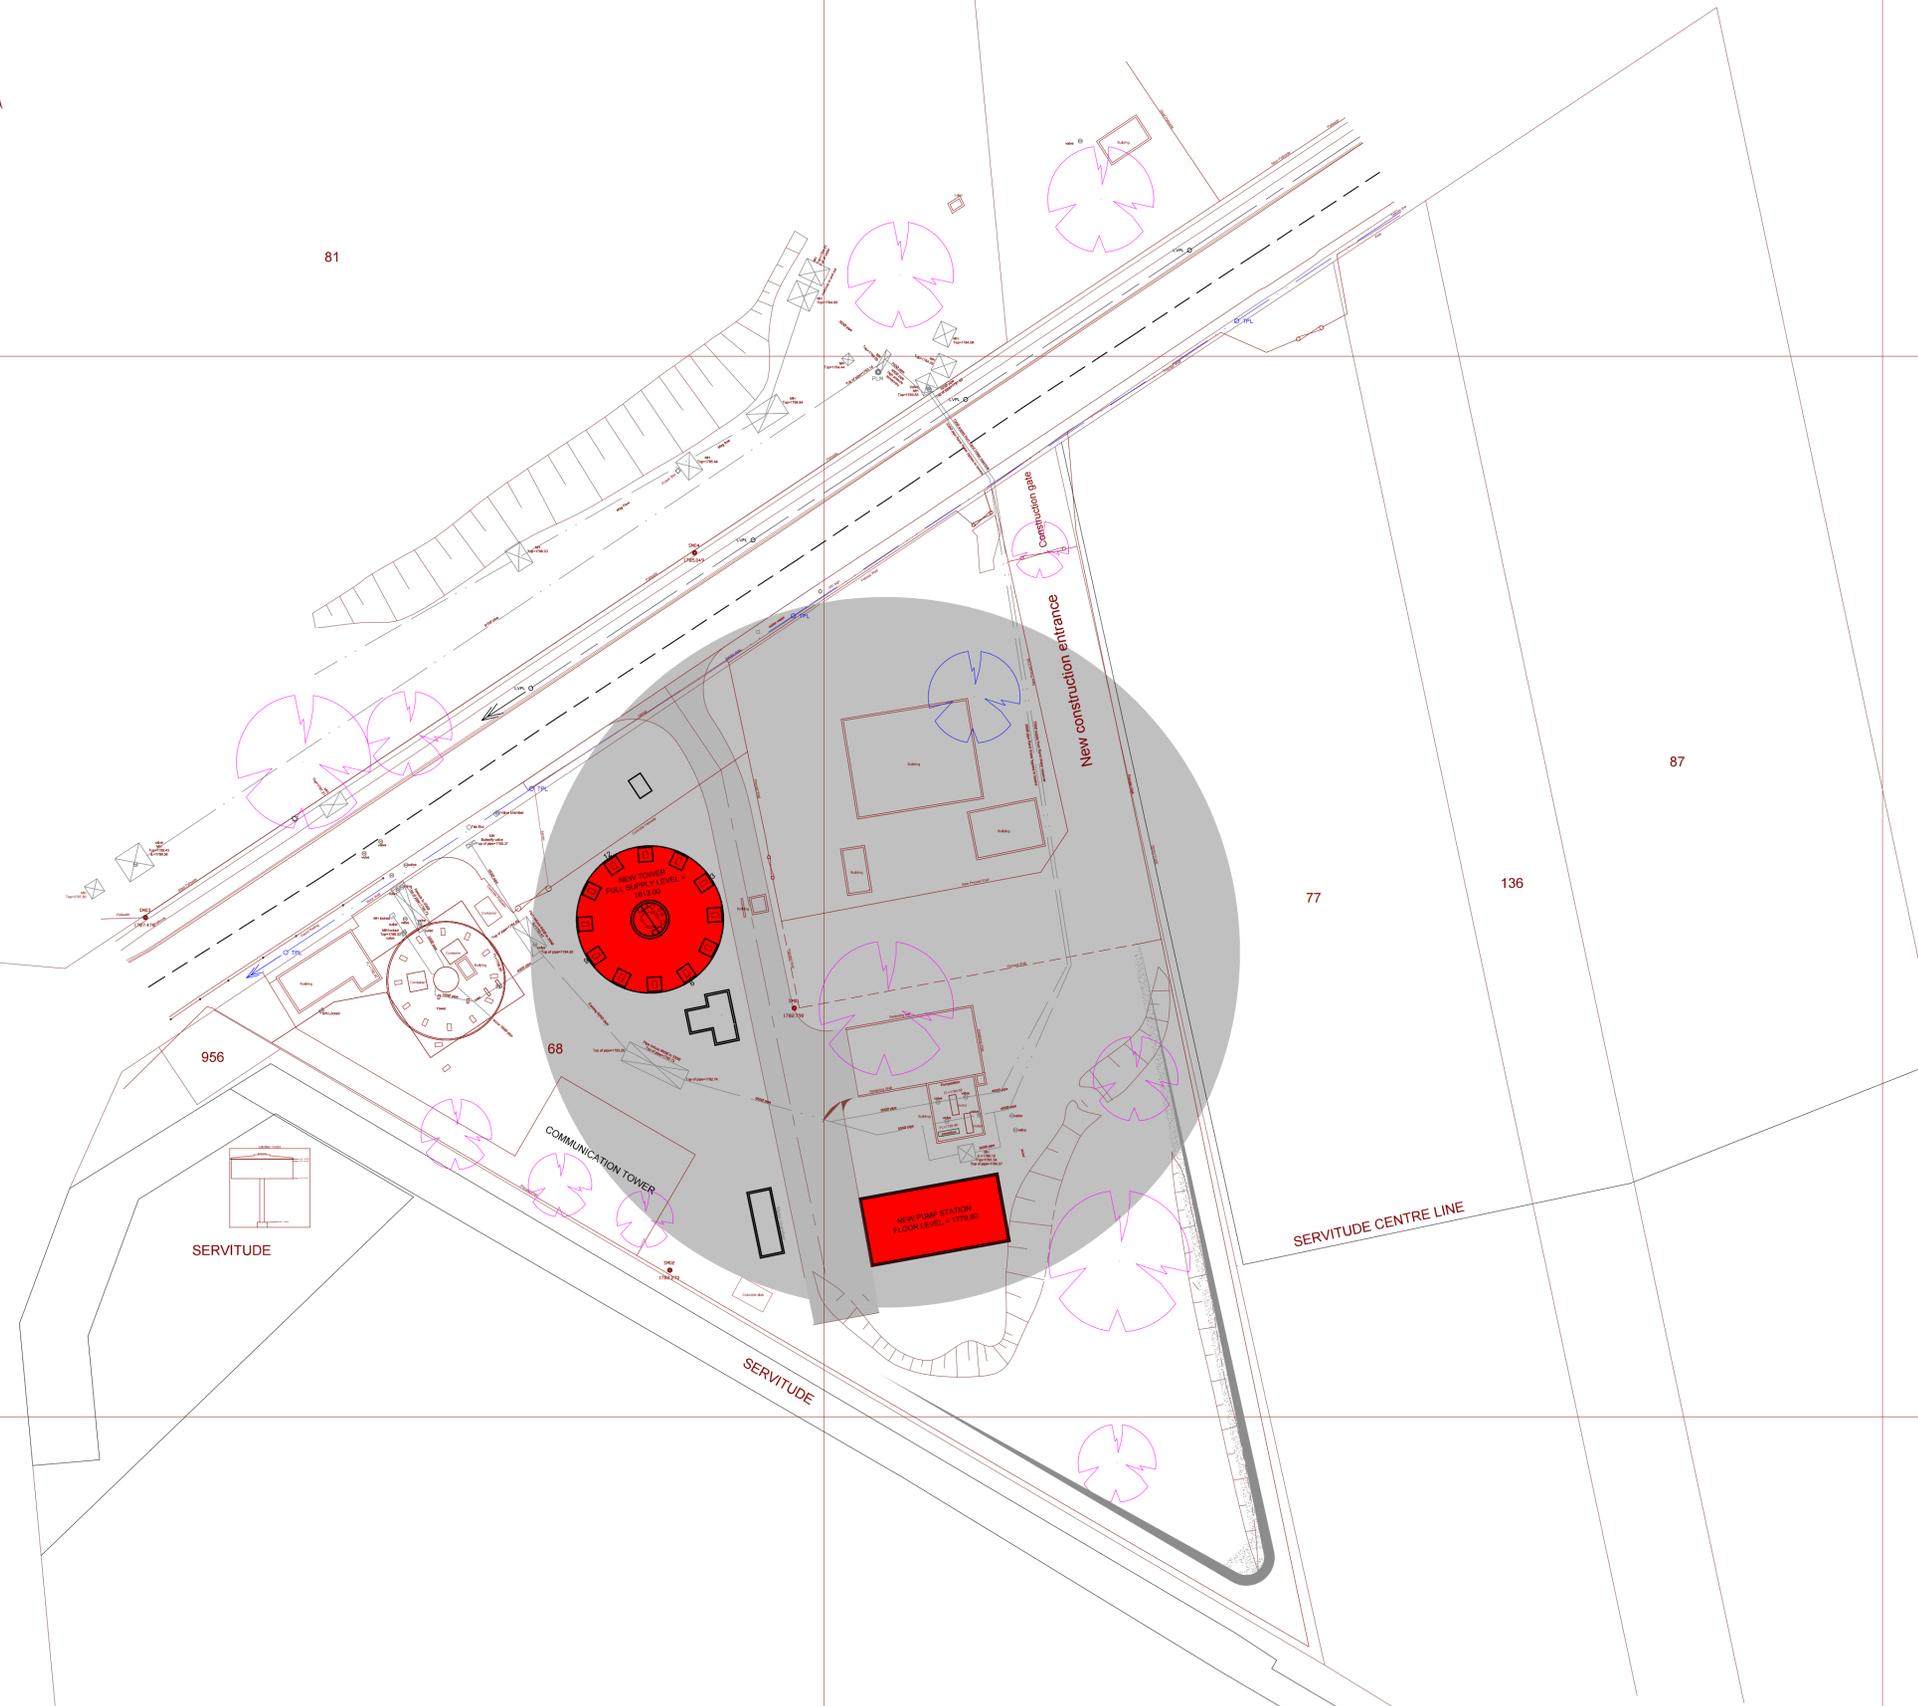

81

+ 2905800 X

Platform Co-ordinates			
ID	Y	X	Z
P1	95542.112	2905943.925	1780,000
P2	95532.324	2905938.907	1779,945
P3	95526.876	2905919.505	1780,000
P4	95509.309	2905893.325	1779,945
P5	95505.242	2905883.104	1780,000
P6	95495.563	2905930.626	1779,755
P7	95487.686	2905969.305	1780,000
P8	95491.440	2905972.033	1780,000



+ 2905950 X

KEY PLAN

SCALE - 1 : 500

CONSULTING ENGINEERS  
 TRIM CONSULTING ENGINEERS  
 WIEWORK,  
 155 WEST STREET,  
 SANDTON,  
 JOHANNESBURG.  
 CLIENT POSTAL ADDRESS:  
 P O Box 61542  
 MATSHALLTOWN  
 2107

DESIGNED	P. S. Botha		
DRAWN	J. Nel		
CHECKED	P. S. Botha		
APPROVED BY:		SIGNATURE	DATE
	P. S. Botha		
ECSA REG. No.	730401		
CHECKED			
		SIGNATURE	DATE



PHYSICAL ADDRESS:  
 65 NTEMI PILISO STREET  
 NEWTOWN  
 JOHANNESBURG

TEL: (011) 688-1400  
 FAX: (011) 688-1529

FOREST HILL WATER SUPPLY  
 NEW WATER TOWER & PUMP STATION

GENERAL SITE PLAN

SURVEY INFORMATION		APPROVAL BY JW DEPOT		SCALE	AMENDMENTS	
PROJECT SURVEYOR:		CHECKED		1: 500	REV:	DESCRIPTION
DATE:		APPROVED BY:				DATE:
		SIGNATURE	DATE			
CCTV INFORMATION		APPROVAL BY JW PLANNING				
CCTV COMPANY:		CHECKED				
DATE:		APPROVED BY:				
		SIGNATURE	DATE			

JW14402	S01	-	0
CONTRACT No.	DRAWING No.		REV.
A1	SHEET	1	OF 7
ORIGINAL PAGE SIZE			
FILE No.			