


LEGEND	
RUNWAY 08/26	
TAXIWAY A1	
TAXIWAY A2	
TAXIWAY A3	
TAXIWAY A4	
TAXIWAY ALPHA	
TAXIWAY BRAVO	
TAXIWAY CHARLIE	
TAXIWAY ECHO	
FENCE	
TRAPEZOIDAL DRAIN	

DRAWING NUMBER	DESCRIPTION
GENERAL DETAILS	
ROMH-188-07-RD-001	General Layout
GEOMETRICS	
ROMH-188-07-R1-001	Geometric Layout and Longitudinal Section: Runway km0 - km1
ROMH-188-07-R1-002	Geometric Layout and Longitudinal Section: Runway km1 - km2
ROMH-188-07-R1-003	Geometric Layout and Longitudinal Section: Runway km2 - km2.22
ROMH-188-07-R1-004	Geometric Layout and Longitudinal Section: Taxiway A1 and A2
ROMH-188-07-R1-005	Geometric Layout and Longitudinal Section: Taxiway A3, Bravo and Charlie
ROMH-188-07-R1-006	Geometric Layout and Longitudinal Section: Taxiway A4 and Echo
ROMH-188-07-R1-007	Geometric Layout and Longitudinal Section: Taxiway Alpha km0 - km1
ROMH-188-07-R1-008	Geometric Layout and Longitudinal Section: Taxiway Alpha km1 - km2
PAVEMENTS	
ROMH-188-07-R6-001	Pavement Layout
ROMH-188-07-R6-002	Pavement Details
MARKINGS & SIGNAGE	
ROMH-188-07-R4-001	Paint Marking Layout
DRAINAGE	
ROMH-188-07-R5-001	Existing Catchment Layout Plan
ROMH-188-07-R5-002	Proposed Catchment Layout Plan
ROMH-188-07-R5-003	Stormwater General Layout Plan
ROMH-188-07-R5-101	Stormwater Details: Sheet 01 of 09
ROMH-188-07-R5-102	Stormwater Details: Sheet 02 of 09
ROMH-188-07-R5-103	Stormwater Details: Sheet 03 of 09
ROMH-188-07-R5-104	Stormwater Details: Sheet 04 of 09
ROMH-188-07-R5-105	Stormwater Details: Sheet 05 of 09
ROMH-188-07-R5-106	Stormwater Details: Sheet 06 of 09
ROMH-188-07-R5-107	Stormwater Details: Sheet 07 of 09
ROMH-188-07-R5-108	Stormwater Details: Sheet 08 of 09
ROMH-188-07-R5-109	Stormwater Details: Sheet 09 of 09
TYPICAL DETAILS	
ROMH-188-07-R2-001	Typical Crosssection
ROMH-188-07-R9-001	Typical Stormwater Details Sheet 1
ROMH-188-07-R9-002	Typical Stormwater Details Sheet 2
ROMH-188-07-R9-003	Typical Stormwater Details Sheet 3
ROMH-188-07-R9-004	Typical Stormwater Details Sheet 4
ROMH-188-07-R9-005	Typical Stormwater Details Sheet 5
ROMH-188-07-R9-006	Typical Stormwater Details Sheet 6
ROMH-188-07-R9-007	Typical Stormwater Details Sheet 7
ROMH-188-07-R9-008	Typical Stormwater Details Sheet 8
ROMH-188-07-R9-009	Typical Stormwater Details Sheet 9
ROMH-188-07-R9-010	Typical Stormwater Details Sheet 10
ROMH-188-07-R9-011	Typical Stormwater Details Sheet 11
ELECTRICAL	
ROMH-188-07-R6-001	Existing Electrical Layout Sheet 1
ROMH-188-07-R6-002	Existing Electrical Layout Sheet 2
ROMH-188-07-R6-003	Existing Electrical Layout Sheet 3
ROMH-188-07-R6-004	Existing Electrical Layout Sheet 4
ROMH-188-07-R6-005	Existing Electrical Layout Sheet 5

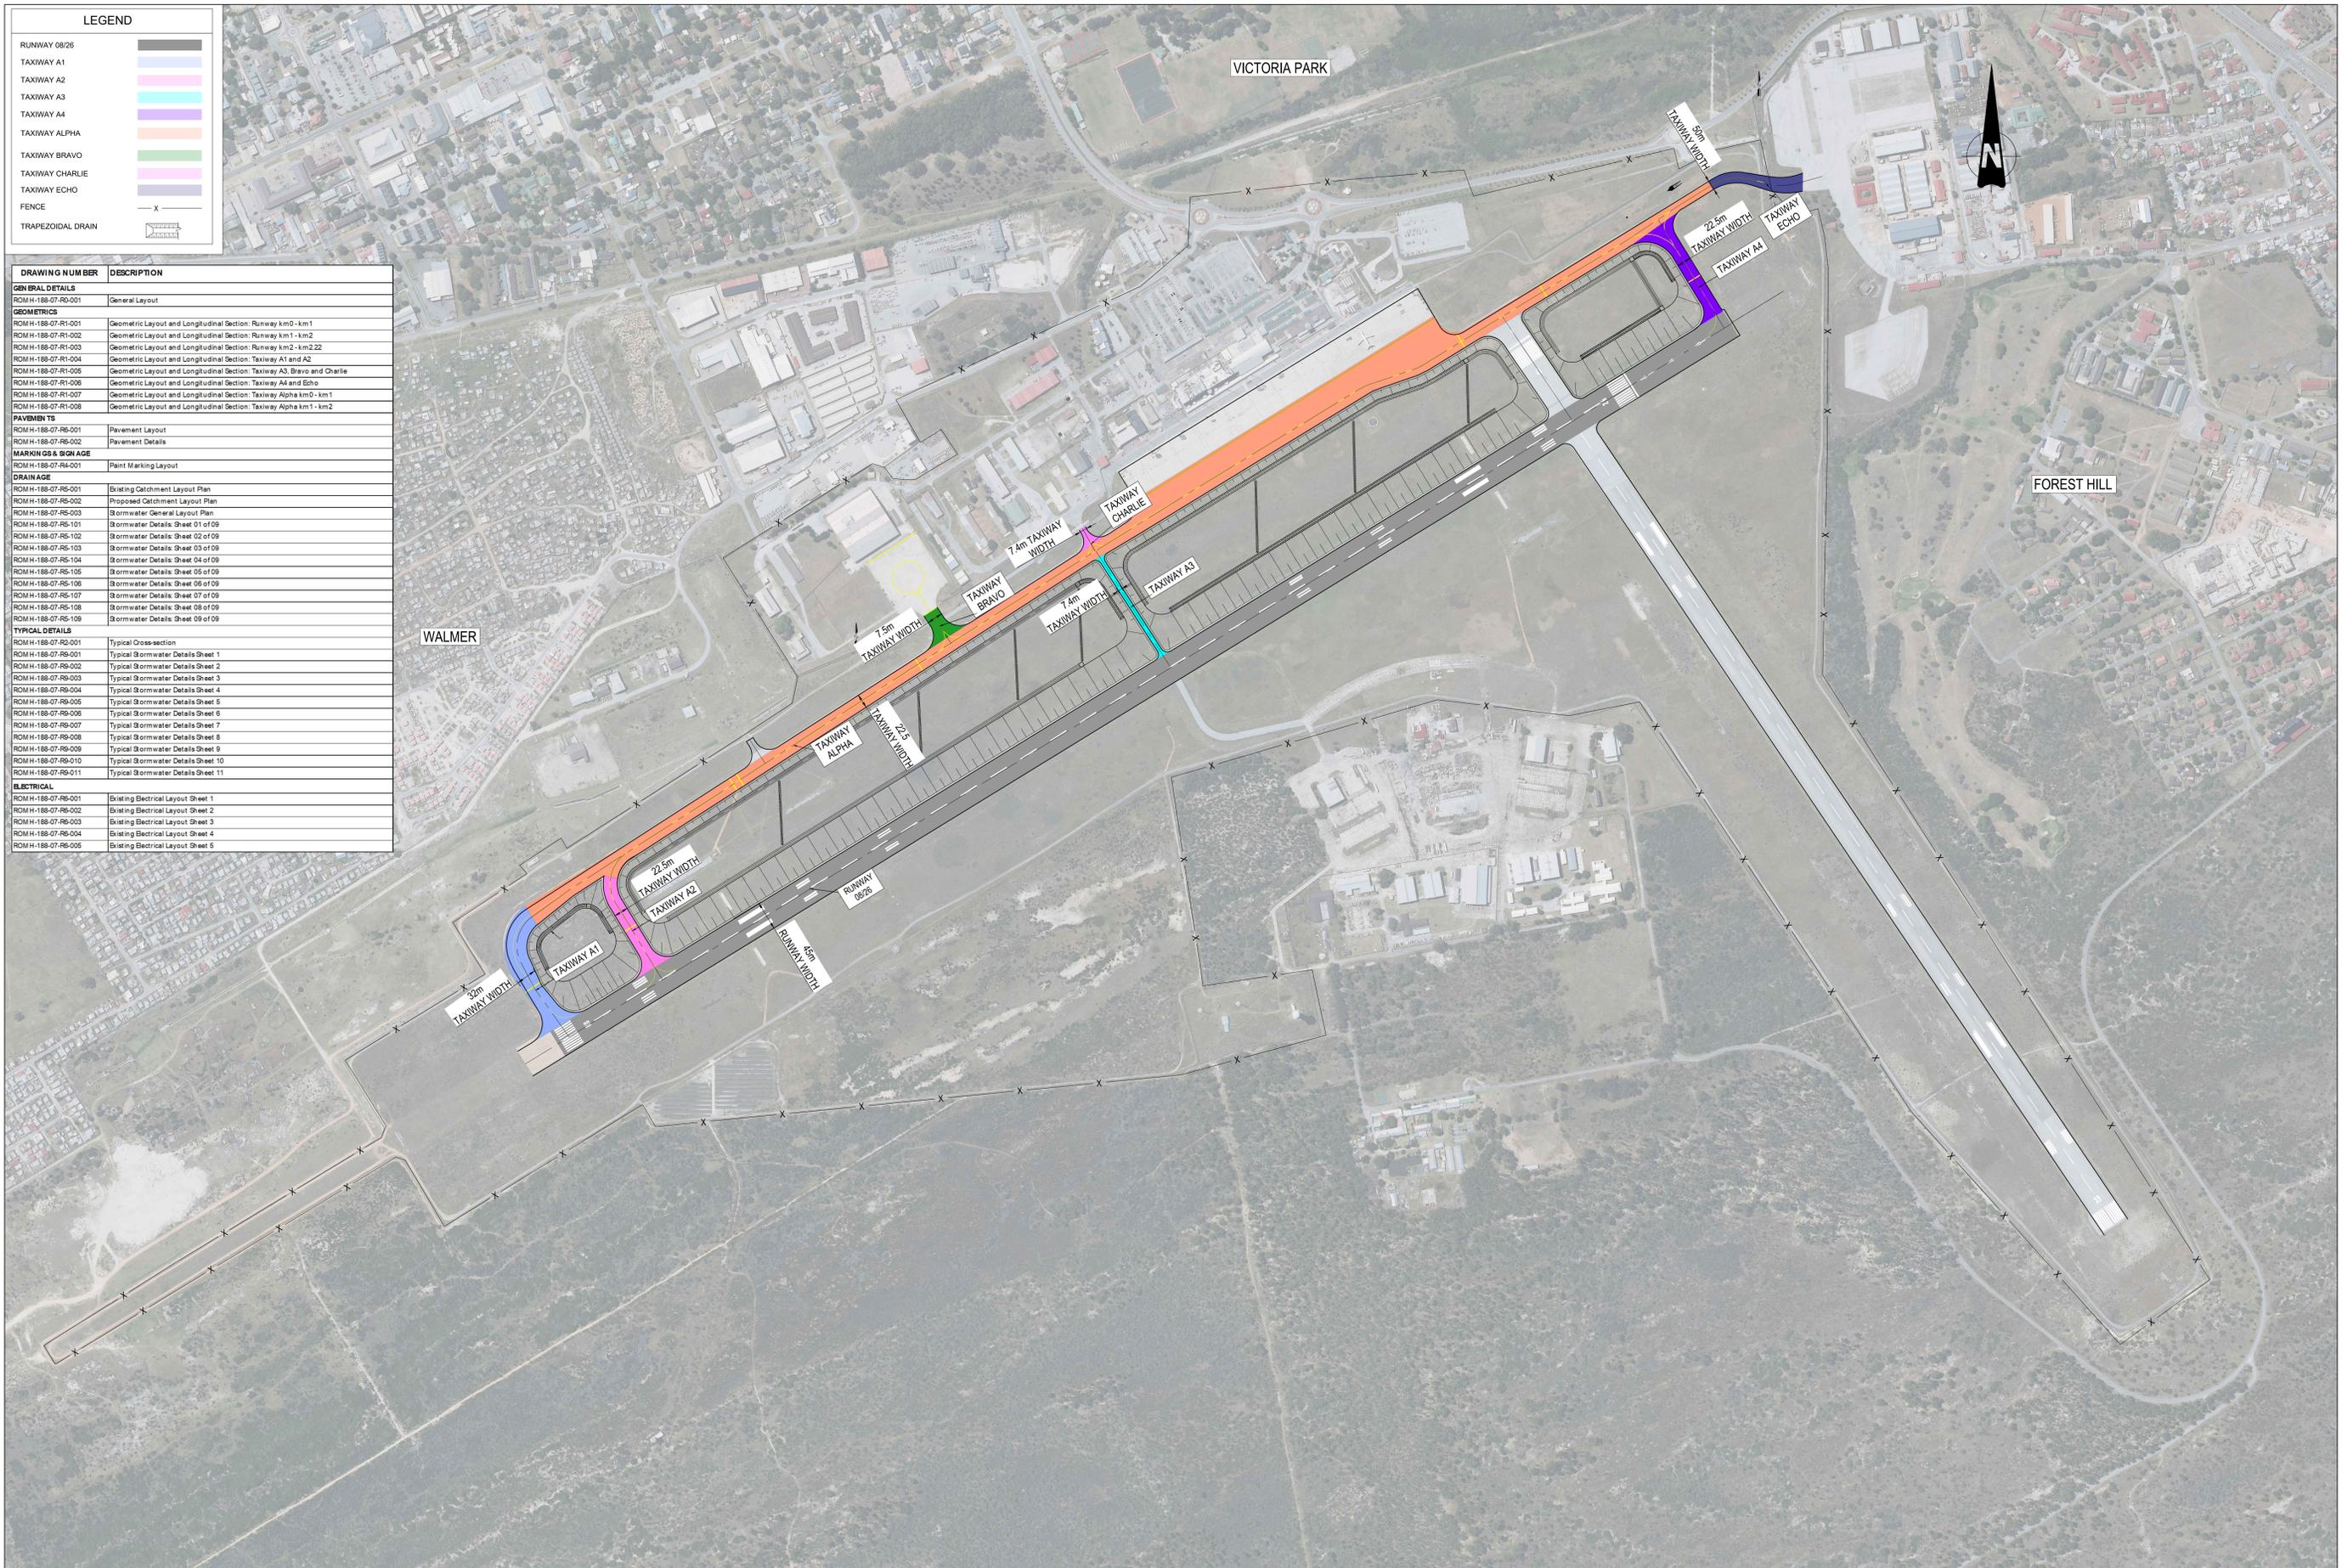

No.	DATE	REVISION	CONSULT. ENG.

CONSTRUCTION RECORD	
WORKS CONTRACT ENGINEER	
Name :	
Prof. Reg. No. :	
Date :	
PROJECT MANAGER	
Name :	
Date :	

CONSULTANTS:
HEAD OFFICE
 Building 12
 Highgrove Office Park
 50 Teget Avenue
 Highveld
 Centurion
 0157
 Tel: (010) 035 1460



DESIGNED BY	
NAME	J. MABUZA
Prof. Reg. No.	
CHECKED BY	
NAME	B. MATLALA
Prof. Reg. No.	2019300403
DRAWN BY	
NAME	E. COETZEE

CONSULTANT APPROVAL	
Name :	
Prof. Reg. No. :	
Date :	



PROJECT DESCRIPTION:	
RUNWAY AND TAXIWAY REHABILITATION AT CHIEF DAVID STURMAN INTERNATIONAL AIRPORT (CDSIA)	
DAVID STURMAN AIRPORT REHABILITATION:	
GENERAL LAYOUT	
SCALE : 1:3000	

PROJECT NUMBER		4429_CDSIA	
DRAWING LOCATION DATA	ROUTE	START	END
SECTION			
DRAWING km DISTANCE			
DRAWING TYPE		GENERAL LAYOUT	
CONSULTANT DRAWING No.	ROMH188-07-R0-001	REV	0