


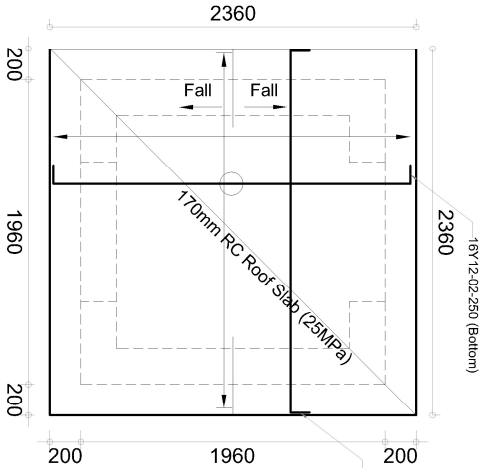
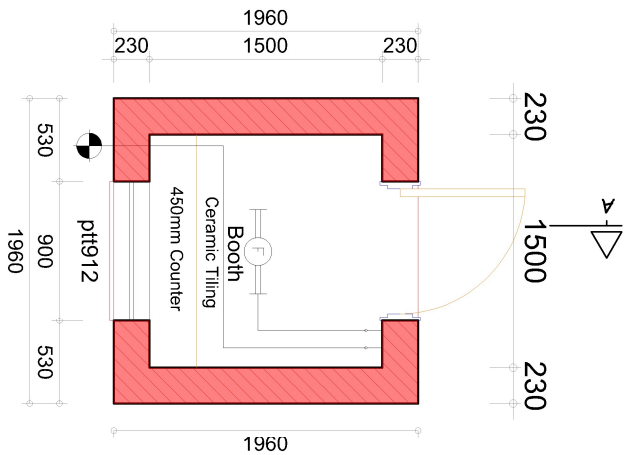
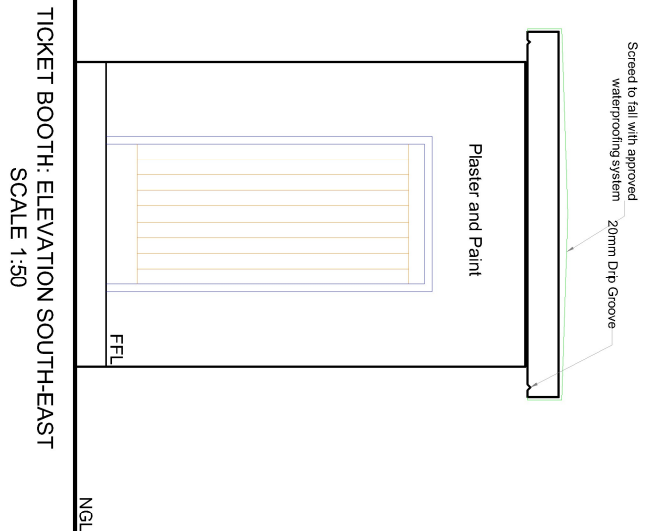


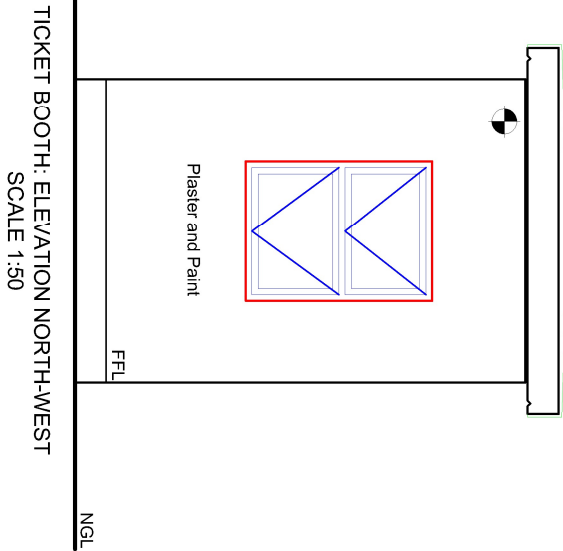




TICKET BOOTH: FLOORPLAN & ELECTR. LAYOUT
SCALE 1:50

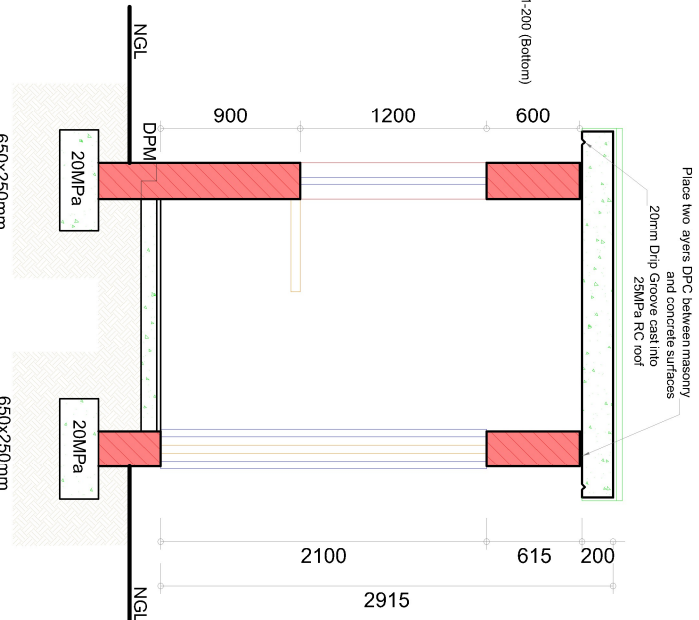

SYMBOL	DESCRIPTION
	Distribution Board
	Ceiling Mounted Lamp
	2-Way Light Switch
	1-Way Fluorescent Lamp
	2-Way Wall Socket
	1-Way Light Switch
	Watertight Outside Lamp
	Down Lighter

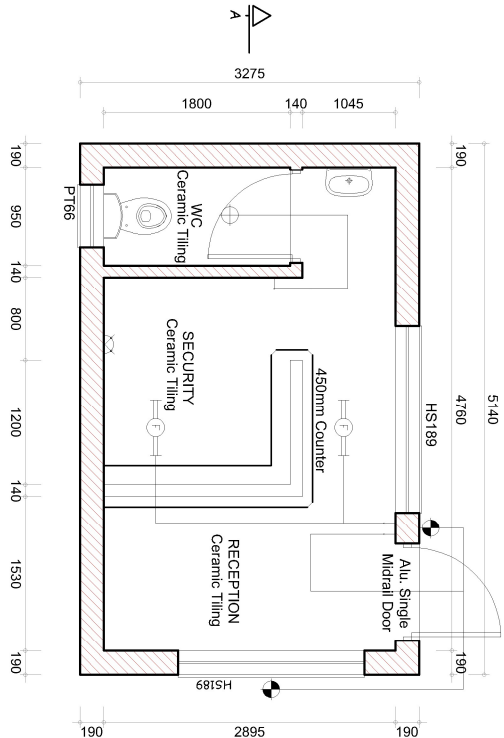

GUARDHOUSE: FLOORPLAN & ELECTR. LAYOUT
SCALE 1:75

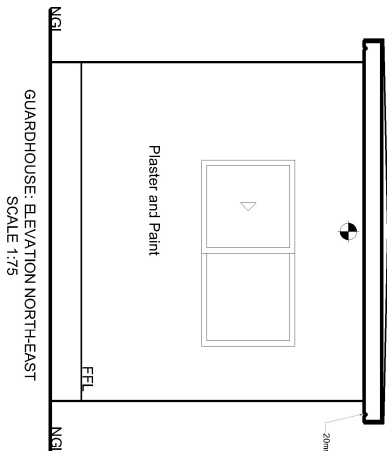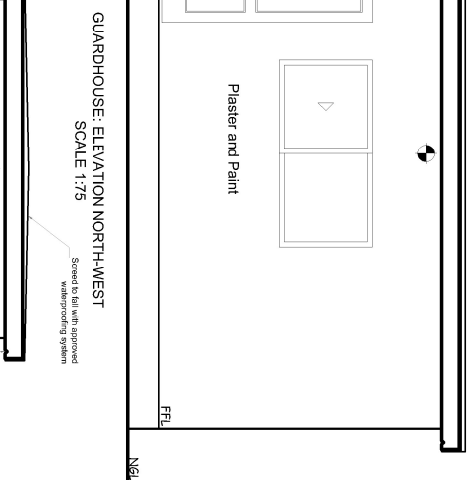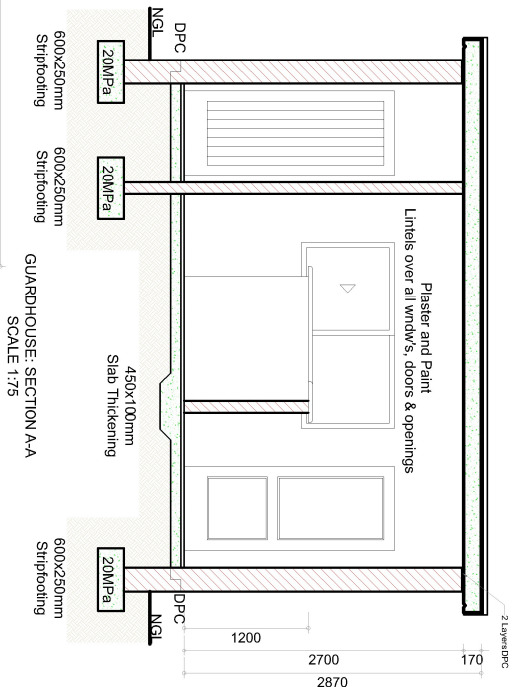

Note 1:	Reinforced concrete roof slab 170mm deep.
Note 2:	32mm Screed on 100mm surfaced (25MPa) on 250mm gunpas sheeting on compacted layers of approved fill material. All backfill to be compacted to 95% Mod Aashio. Foundation walls exceeding 900mm height, to be designed by Professional Engineer.
Note 3:	Security gates and burglar bars to be installed at all external doors and windows. Specification of burglar bars and security gates to detail.

GUARDHOUSE: ROOF PLAN
SCALE 1:75

FLOOR PLAN, ELECTRICAL LAYOUT, SECTIONS & ELEVATIONS

CLIENT DETAILS

7 KOPERBERG STREET
SPRINGBOK
8240
SOUTH AFRICA
TEL: +27 27 7182233
FAX: +27 27 7182234
EMAIL: info@ribicon.com

NAMA KHOI MUNICIPALITY
PRIVATE BAG X22
SPRINGBOK
8240



PROJECT DETAILS

UPGRADING OF MATJIESKLOOF SPORT FACILITY

DESIGN	C RHODES, Patchd
DRAWN	C RHODES, Patchd
CHECKED	D RICHARDS, Director
AS BUILT	
FOR CONSTRUCTION	
FOR TENDER PURPOSES	

DRAWING TITLE

CLOAKROOM AND ABLUTION FACILITIES
GUARDHOUSE AND TICKET OFFICE

SCALE	DATE	DRAWING NO.
1:100	JULY 2026	RIB-4840-100-1005 RevA

