


PLAN VIEW
1:25

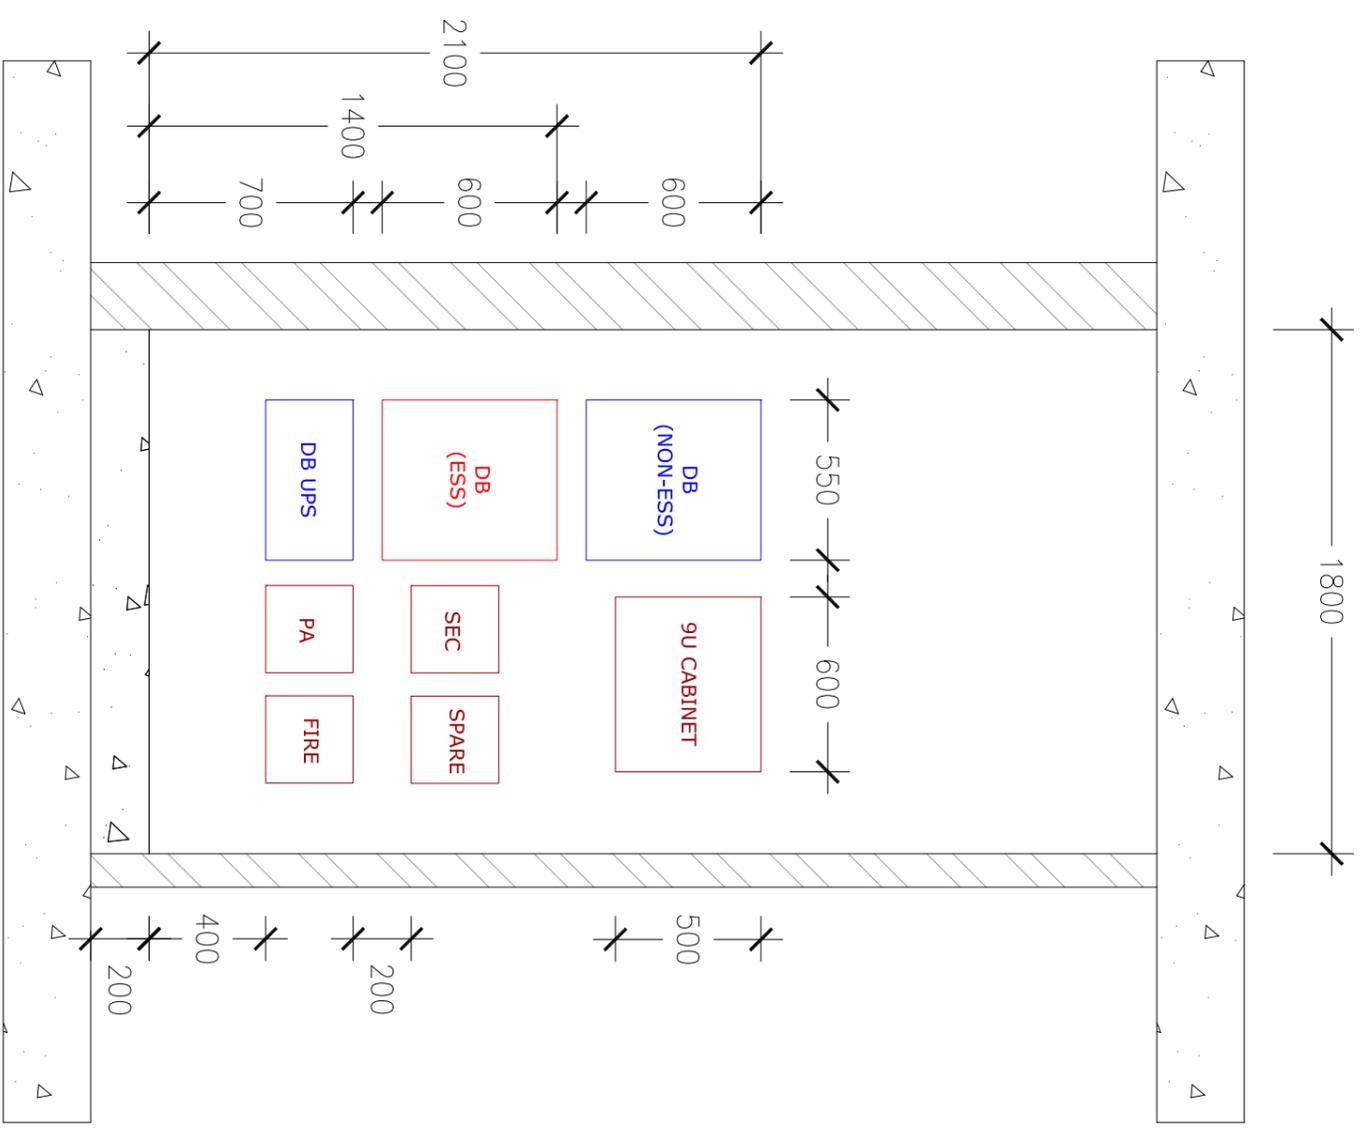

FRONT ELEVATION
1:25

NOT WITHSTANDING ANYTHING TO THE CONTRARY, ALL RIGHTS RESERVED. NO PART OF THIS DRAWING MAY BE REPRODUCED IN ANY MATERIAL FORM (INCLUDING PHOTOCOPYING OR STORING IN ANY MEDIUM OR BY ELECTRONIC MEANS WHETHER OR NOT TRANSPARENTLY OR INCIDENTALLY TO SOME OTHER USE OF THIS DRAWING) AND ALSO, THIS DRAWING MAY NOT BE USED FOR ANY PURPOSE OR REASON OTHER THAN FOR WHICH IT WAS ORIGINALLY ISSUED, WITHOUT THE WRITTEN PERMISSION OF IBUYA PROJECTS

ENGINEER: S.Nzama
DRAWN: RM
DATE: Sept'20
SCALE: 1:25
PAPER SIZE: A3
CHKD: SN

PROJECT: Ngwelezane Hospital
DRAWING TITLE: Equipment Section - Electrical and Electronics Cupboard Layout and Details

REV	DESCRIPTION	BY	DATE	CHKD.	File Name : 20013_507	Lyr:
0	Original Issue	RM	09/09/20	SN	20013	507
					PROJECT No.	DRAWING No.
					20013	507
					SHEET:	REV.
					A3	0

IBUYA PROJECTS
"EMPOWERING DEVELOPMENT"

BLOCK D
ESSEX PARK
4 ESSEX TERRACE
WESTVILLE
P.O. BOX 1692
WANDSBECK 3631

TEL: +27 (031) 2667332
FAX: +27 (031) 2667340
E-mail: ibuya@ibuya.co.za