



NEW FIRE STATION

SCALE 1/8 INCH = 1 FOOT

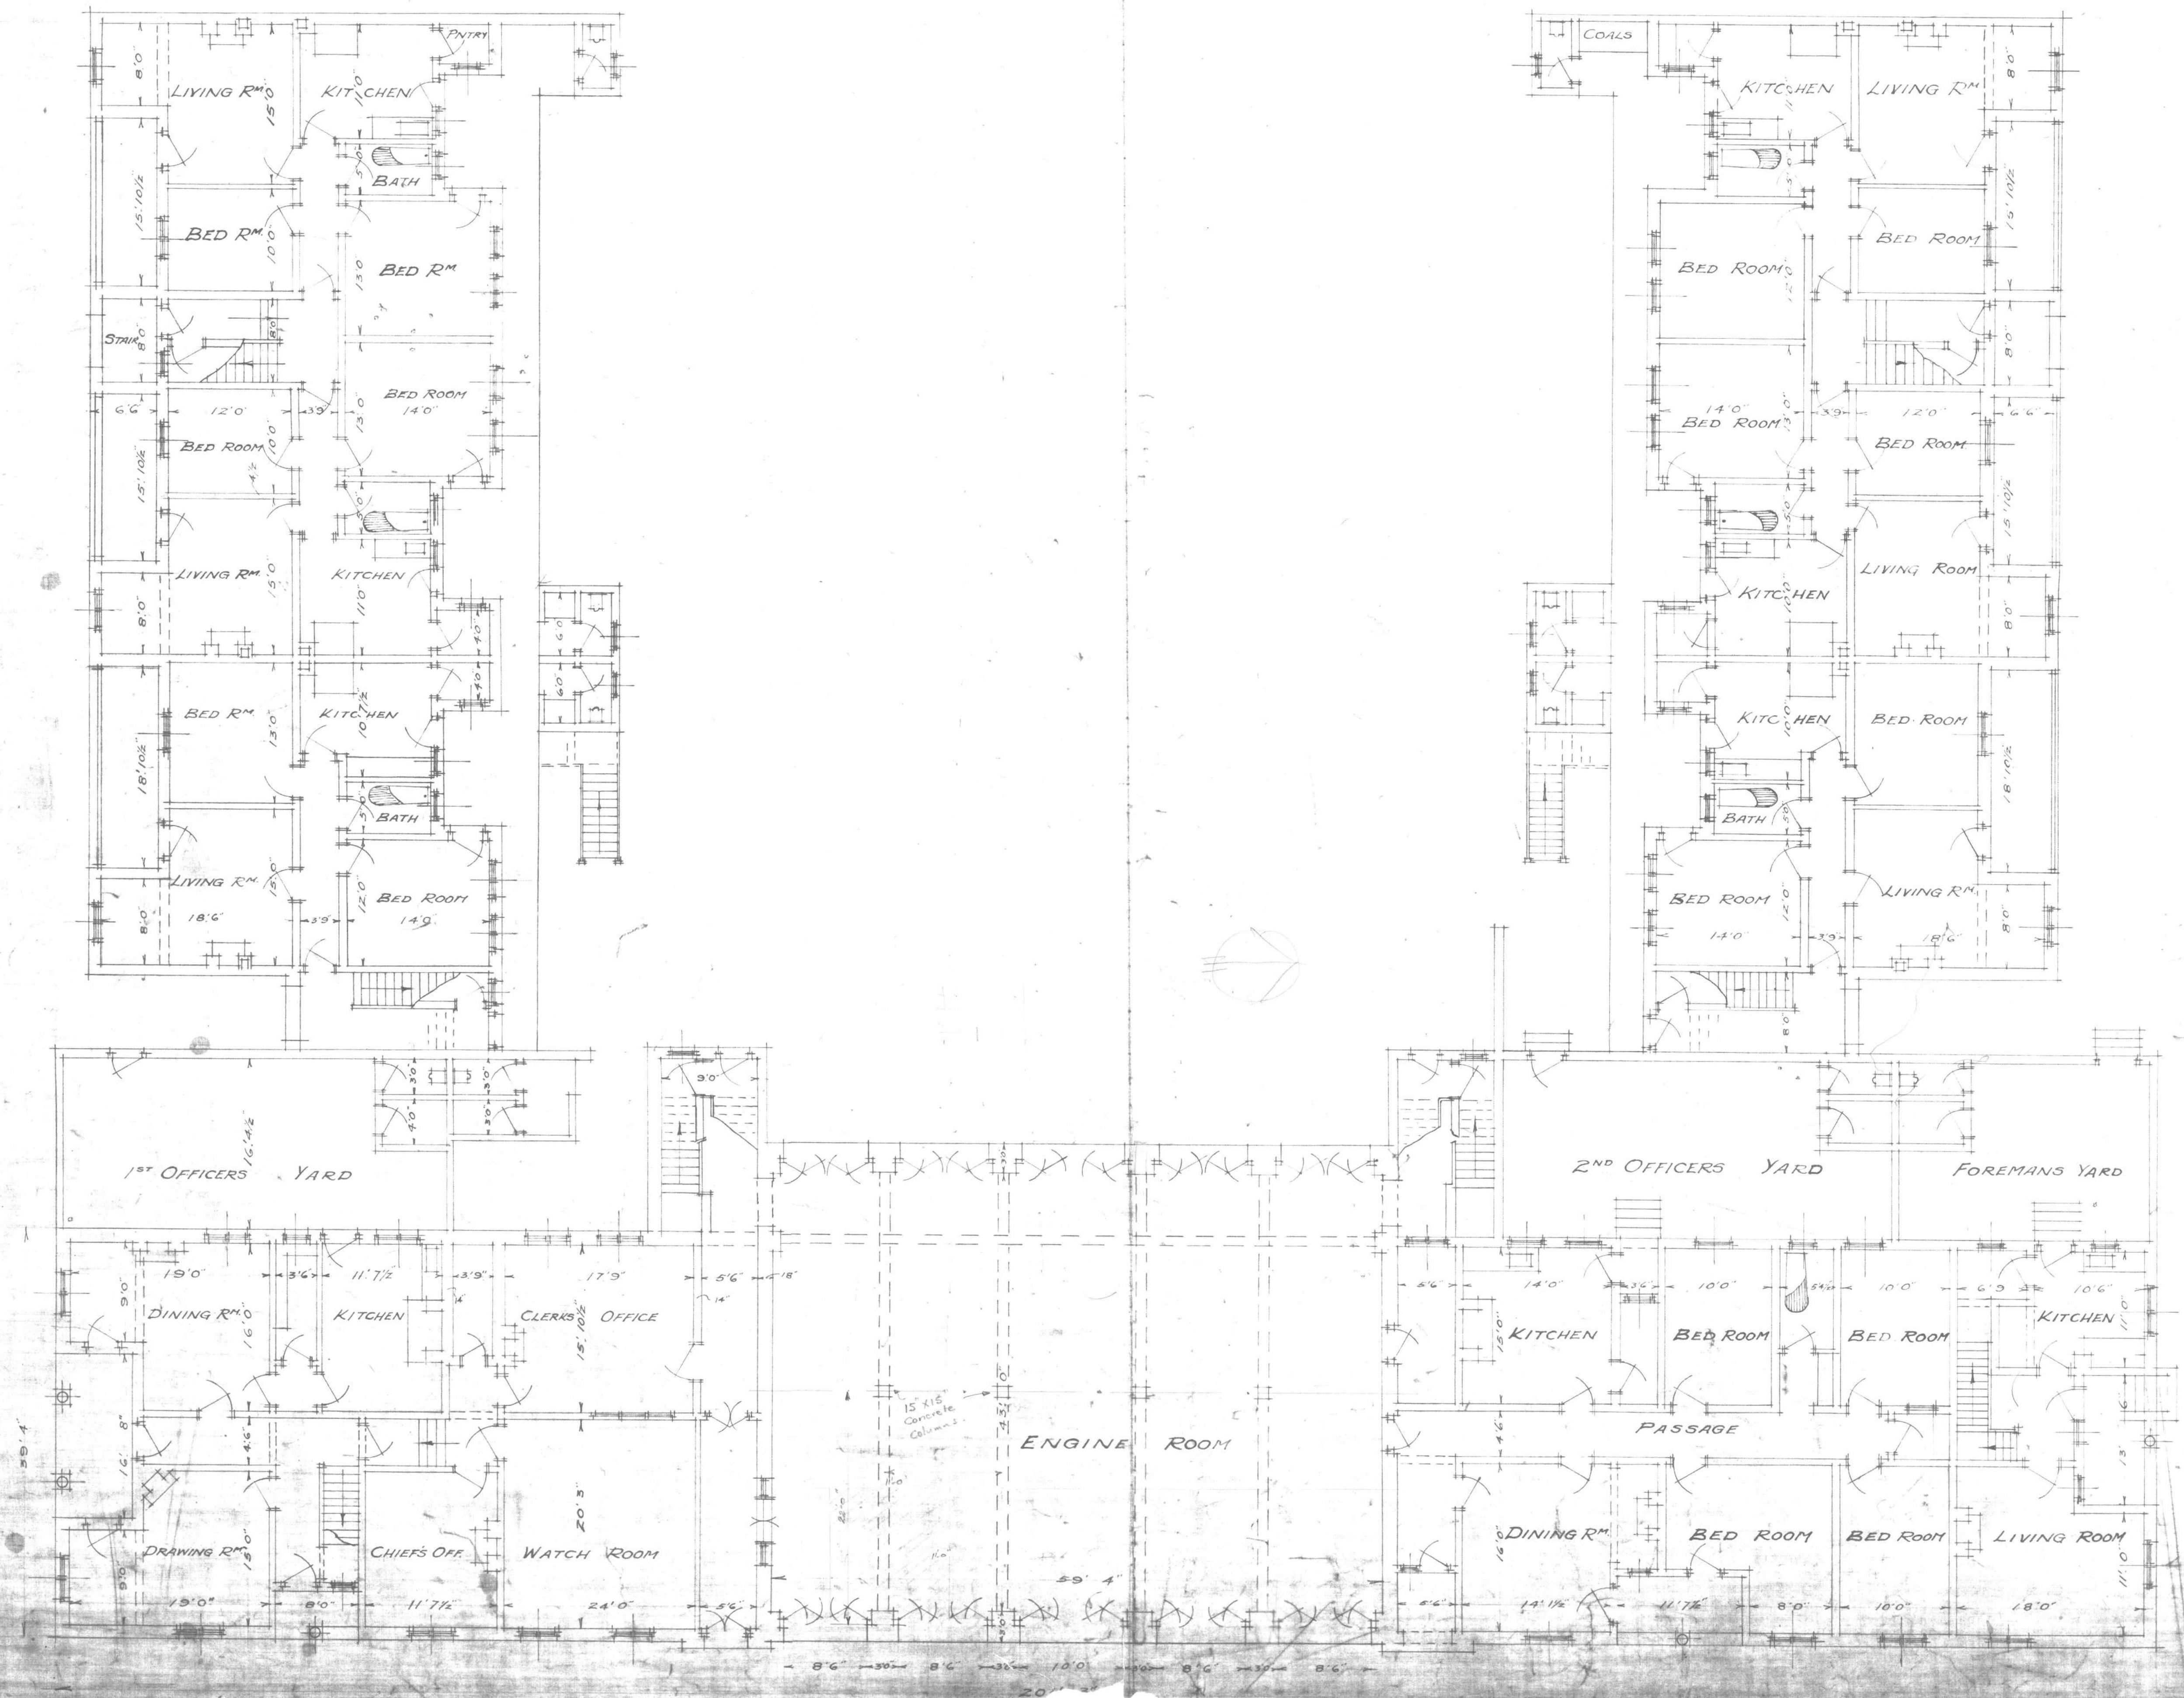


Grand Ave 101/8/50		City Engineer's Office	
10-10-50	10-10-50	10-10-50	10-10-50
10-10-50	10-10-50	10-10-50	10-10-50
Grand Ave 101/8/50		City Engineer's Office	

Scale 1" = 10'-0"

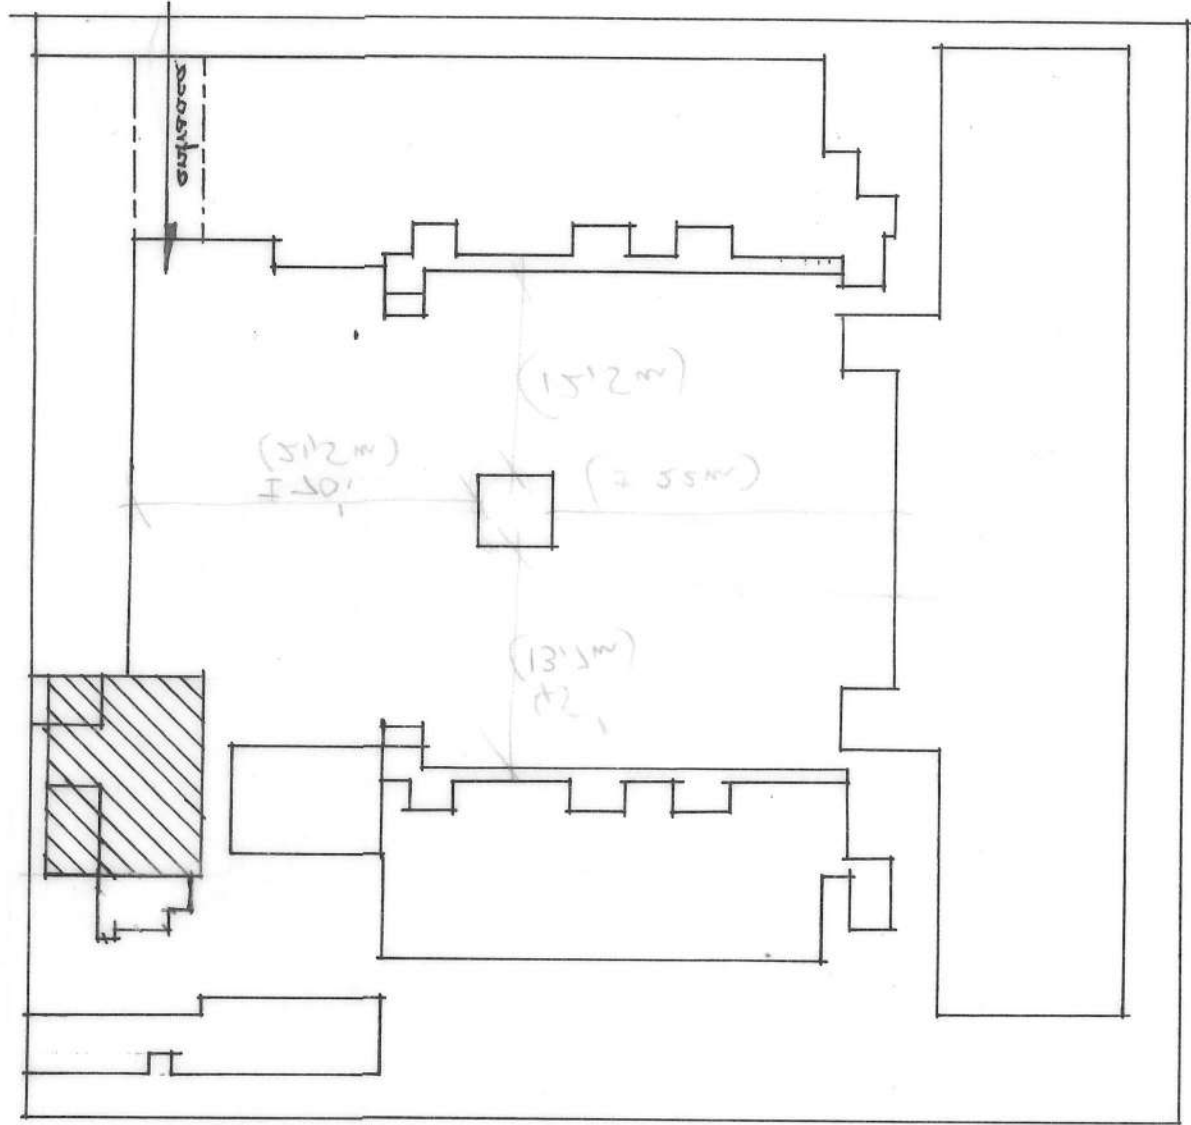

North Arrow

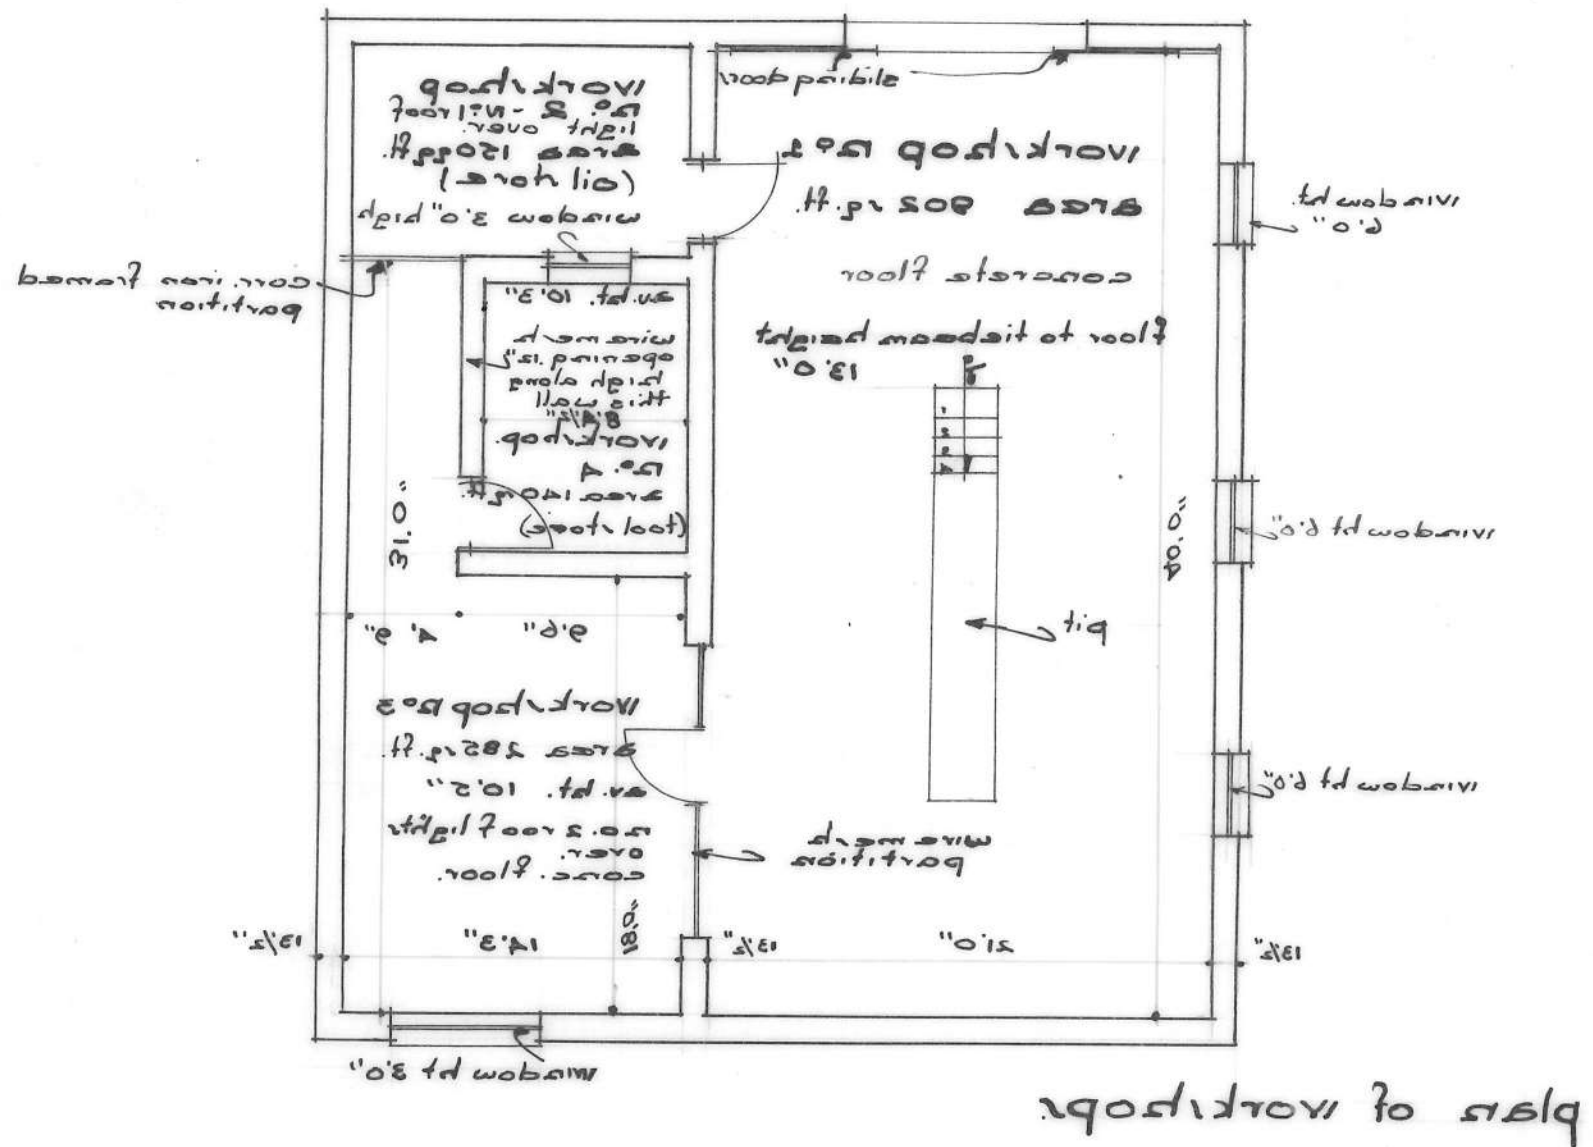


North Arrow



14" SLEEPER PIERS
 SECTION EF

leaves sandbag.
 better up end. west lot.
 gear

Heavy duty Gun

DETAILS OF JOINERY E
 TO FOLLOW.

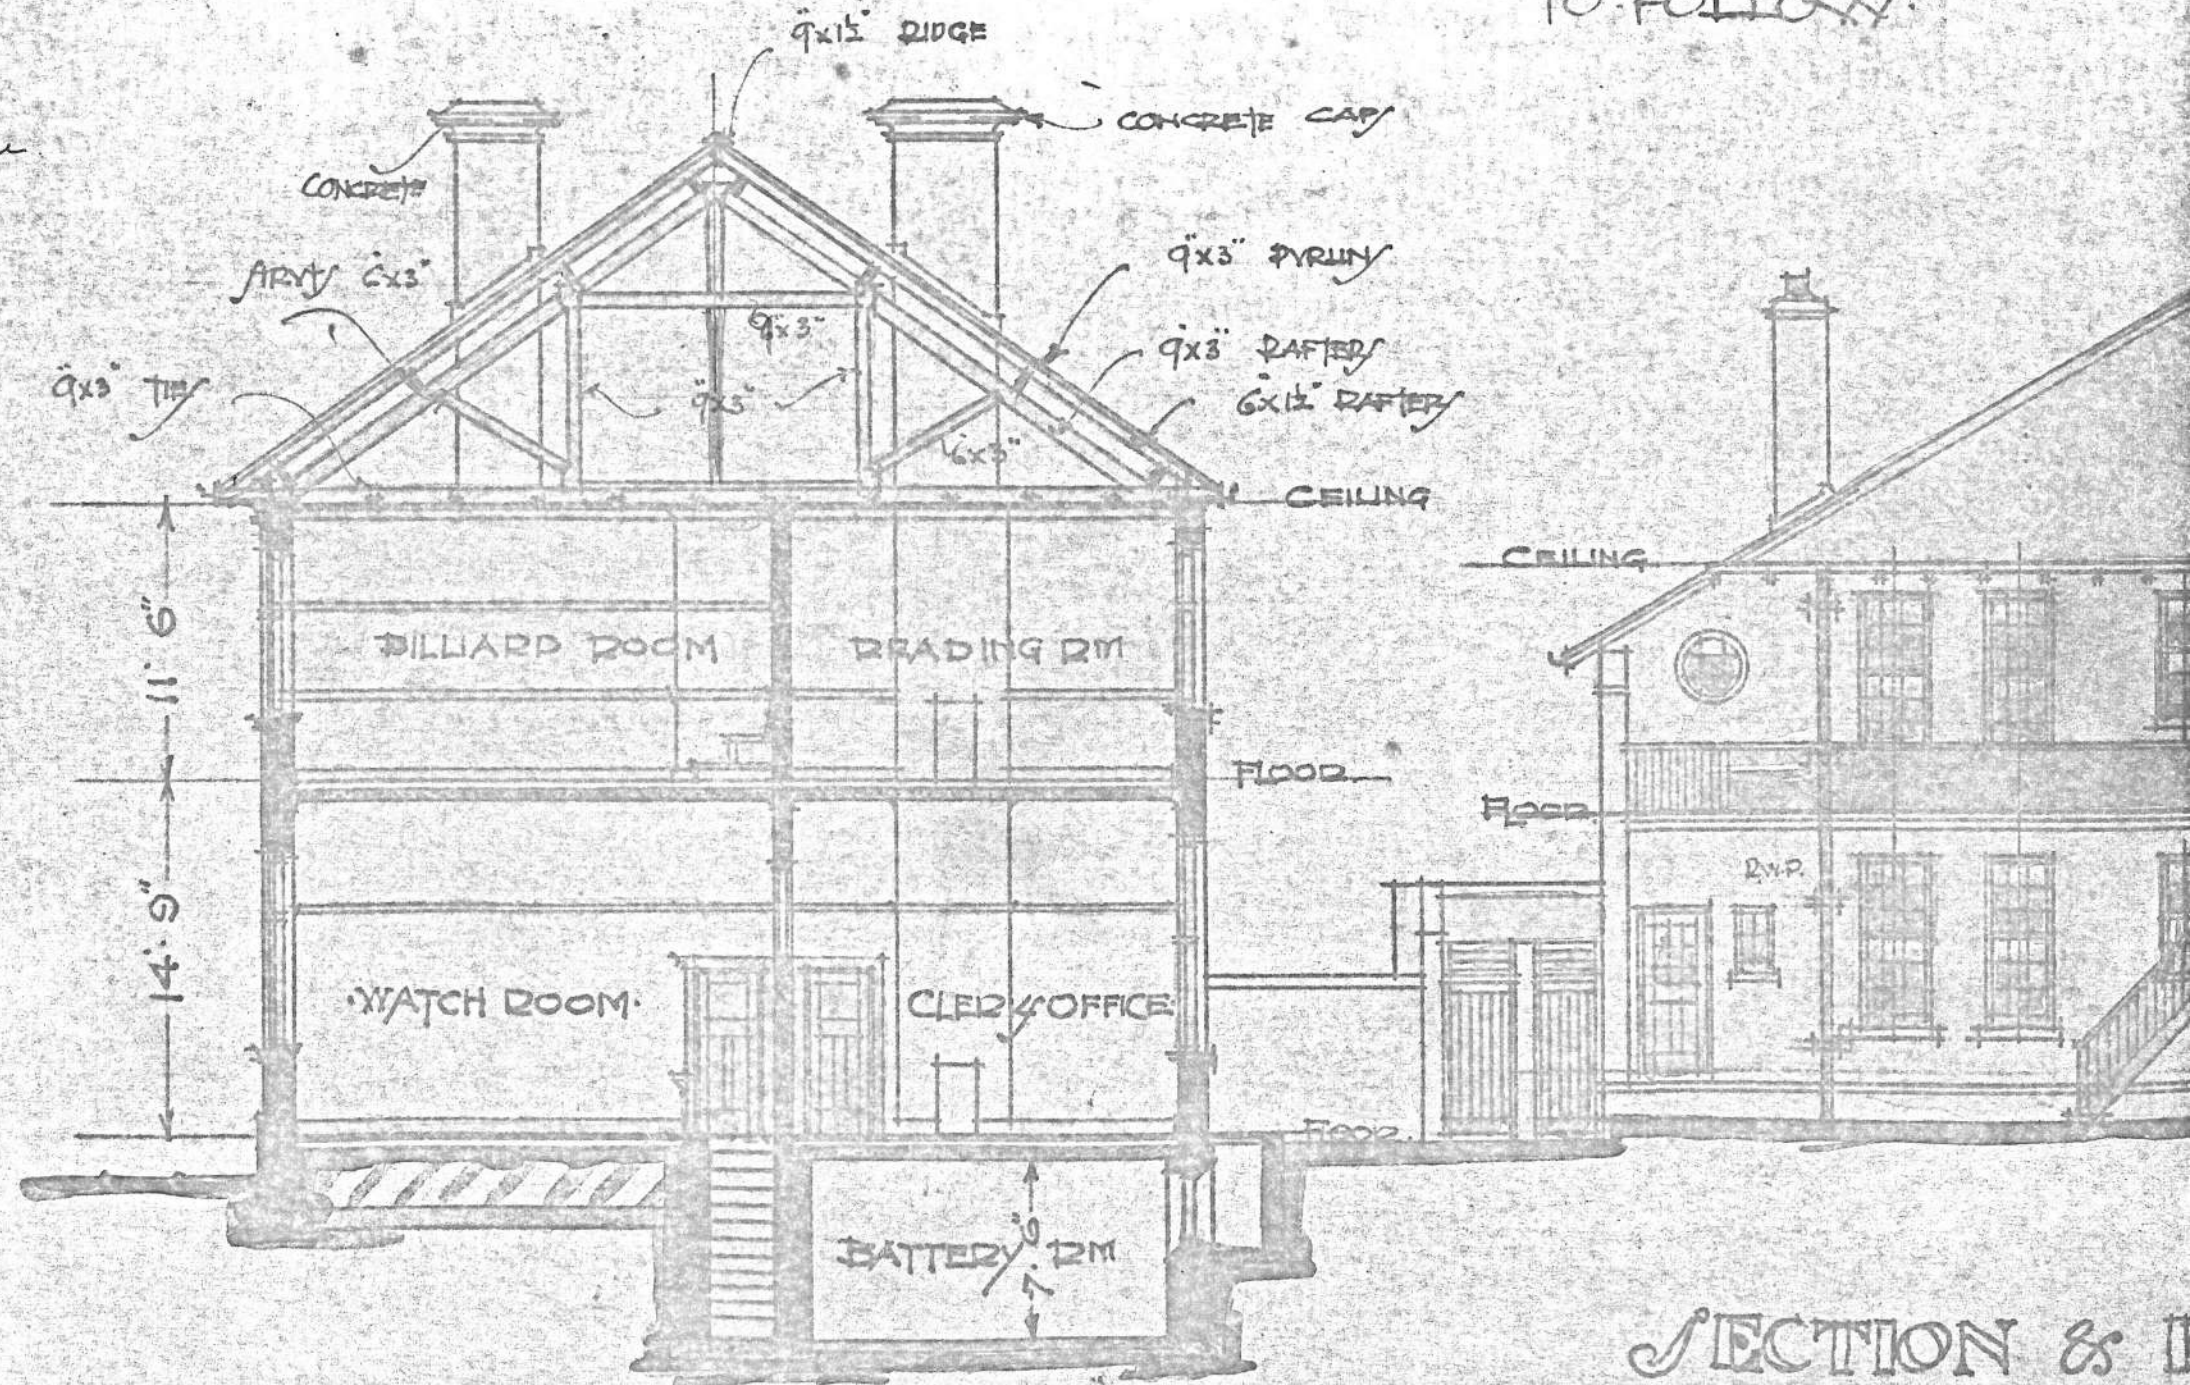


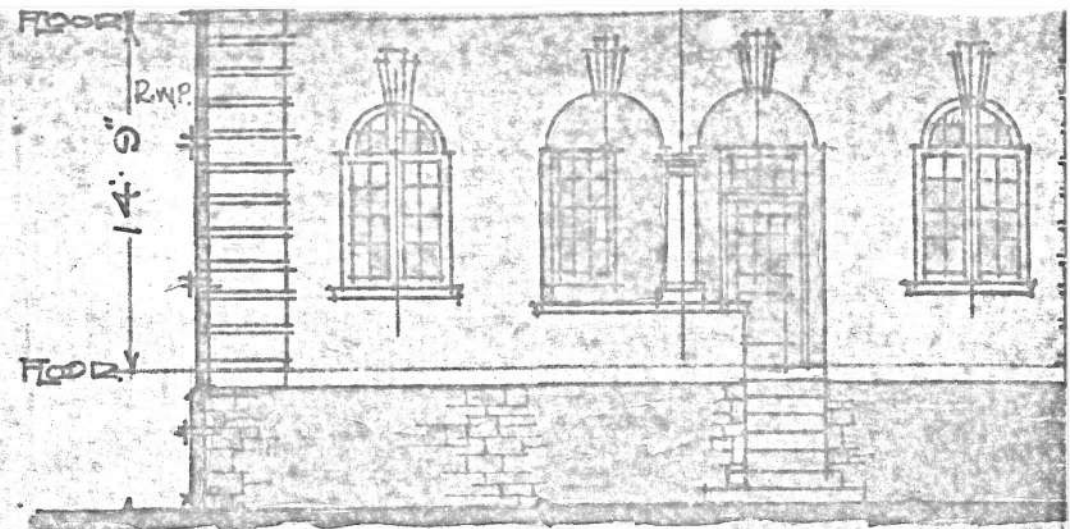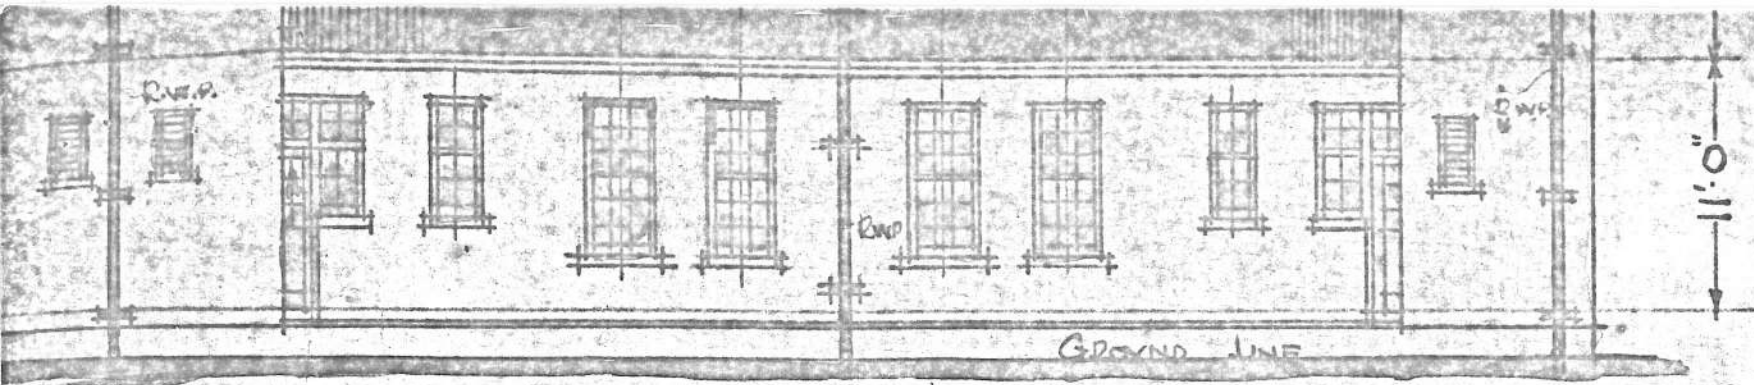

SECTION ON LINE C-D.

ELEVATION OF FOREMAN'S HOUSE.


AND SPECIAL DRAWING

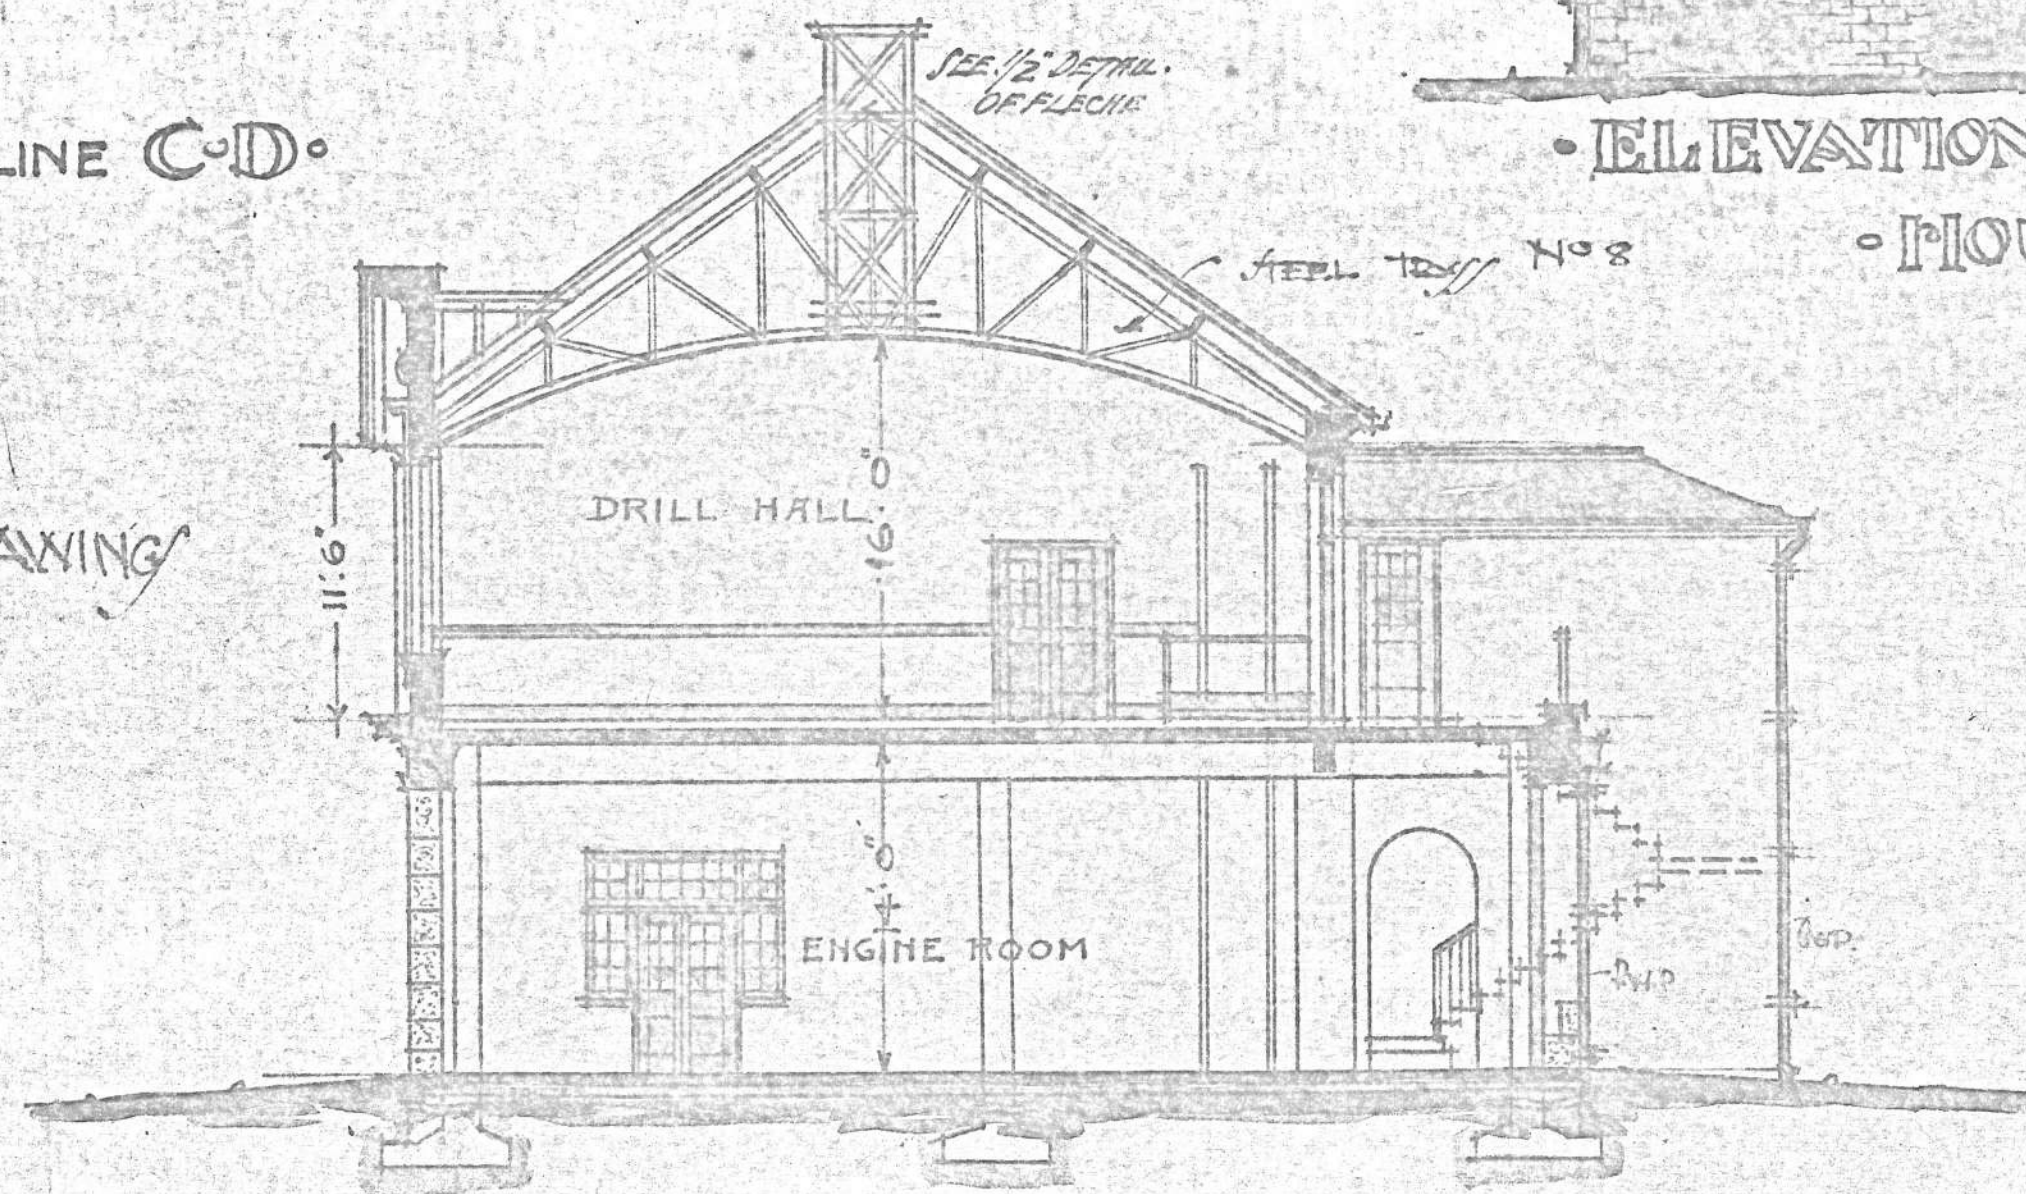

50 100 FEET.

SECTION ON LINE G-H.

No. 13. TRUSS / R.W.P.

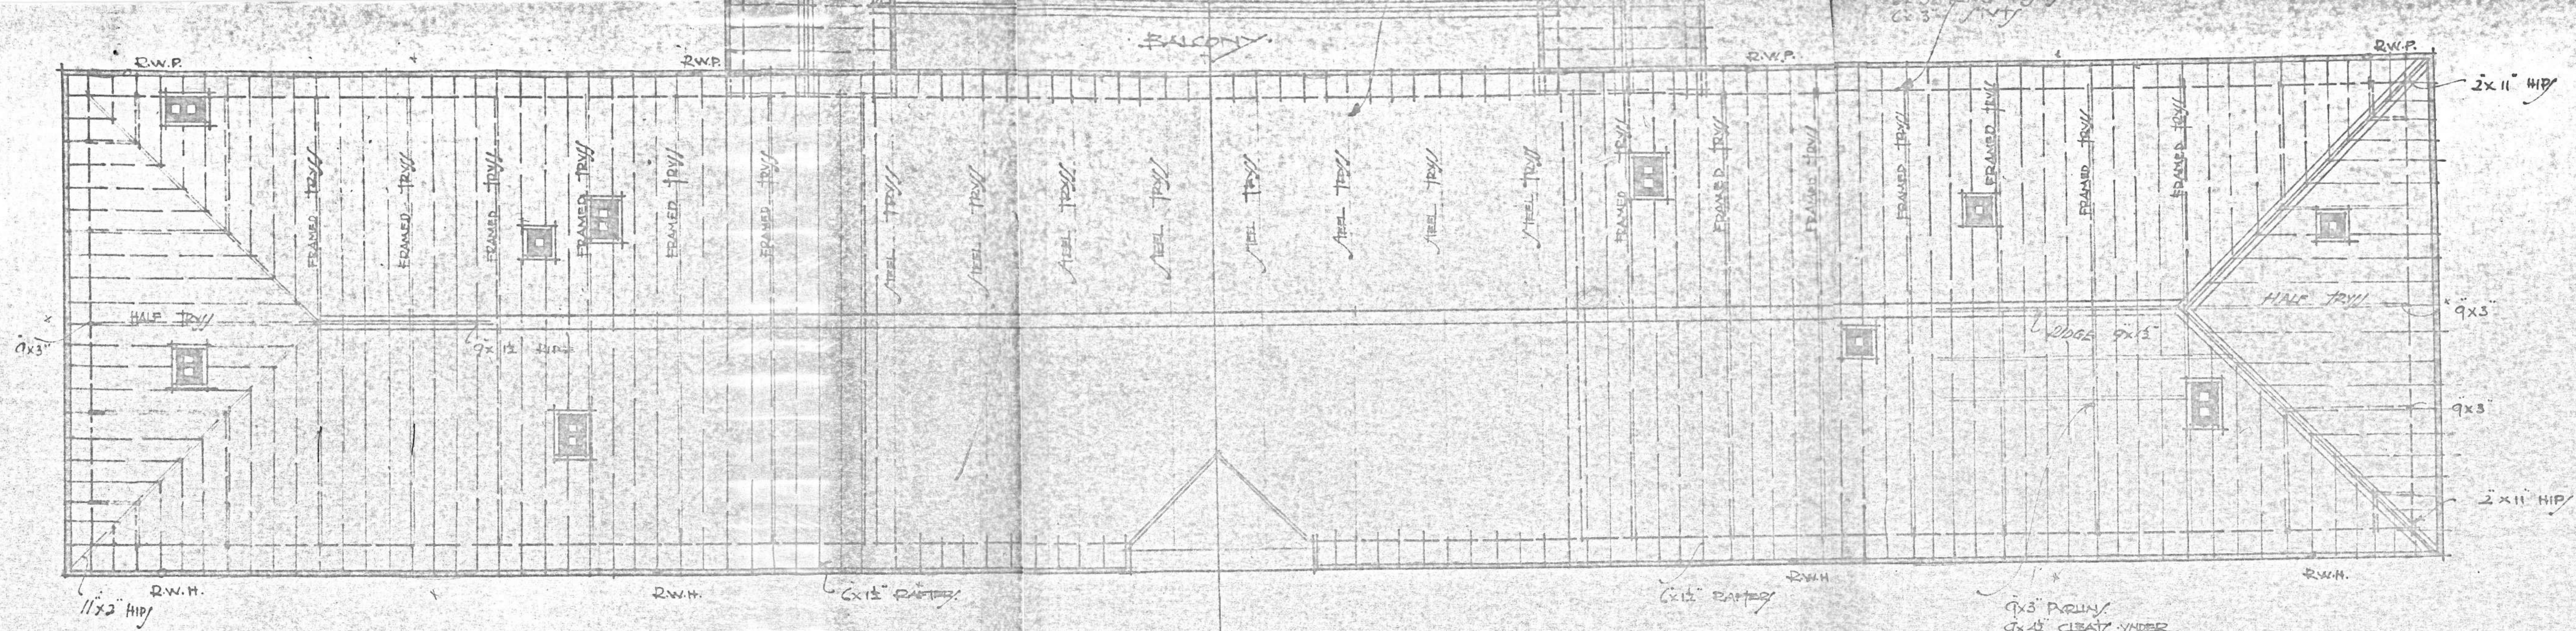

ROOF PLANS

SCALE 8 FEET TO AN INCH



N. J. Cowin
 Civil Engineer, N. J.
 ARCHITECT
 DETROIT