



Size of Standard Board 2450x1800	
WESTERN HIGHVELD BULK WATER SCHEME CONTRACT 1	
CONTRACT NO.: TO BE CONFIRMED	
	Project Funder: DEPARTMENT OF WATER AND SANITATION
	Client (Implementation Agent): NKANGALA DISTRICT MUNICIPALITY
	DR JS MOROKA LOCAL MUNICIPALITY
	Consultant: KUFANIKIWA CONSULTIING
	Contractor: TO BE CONFIRMED
	


FRONT ELEVATION
SCALE 1:10

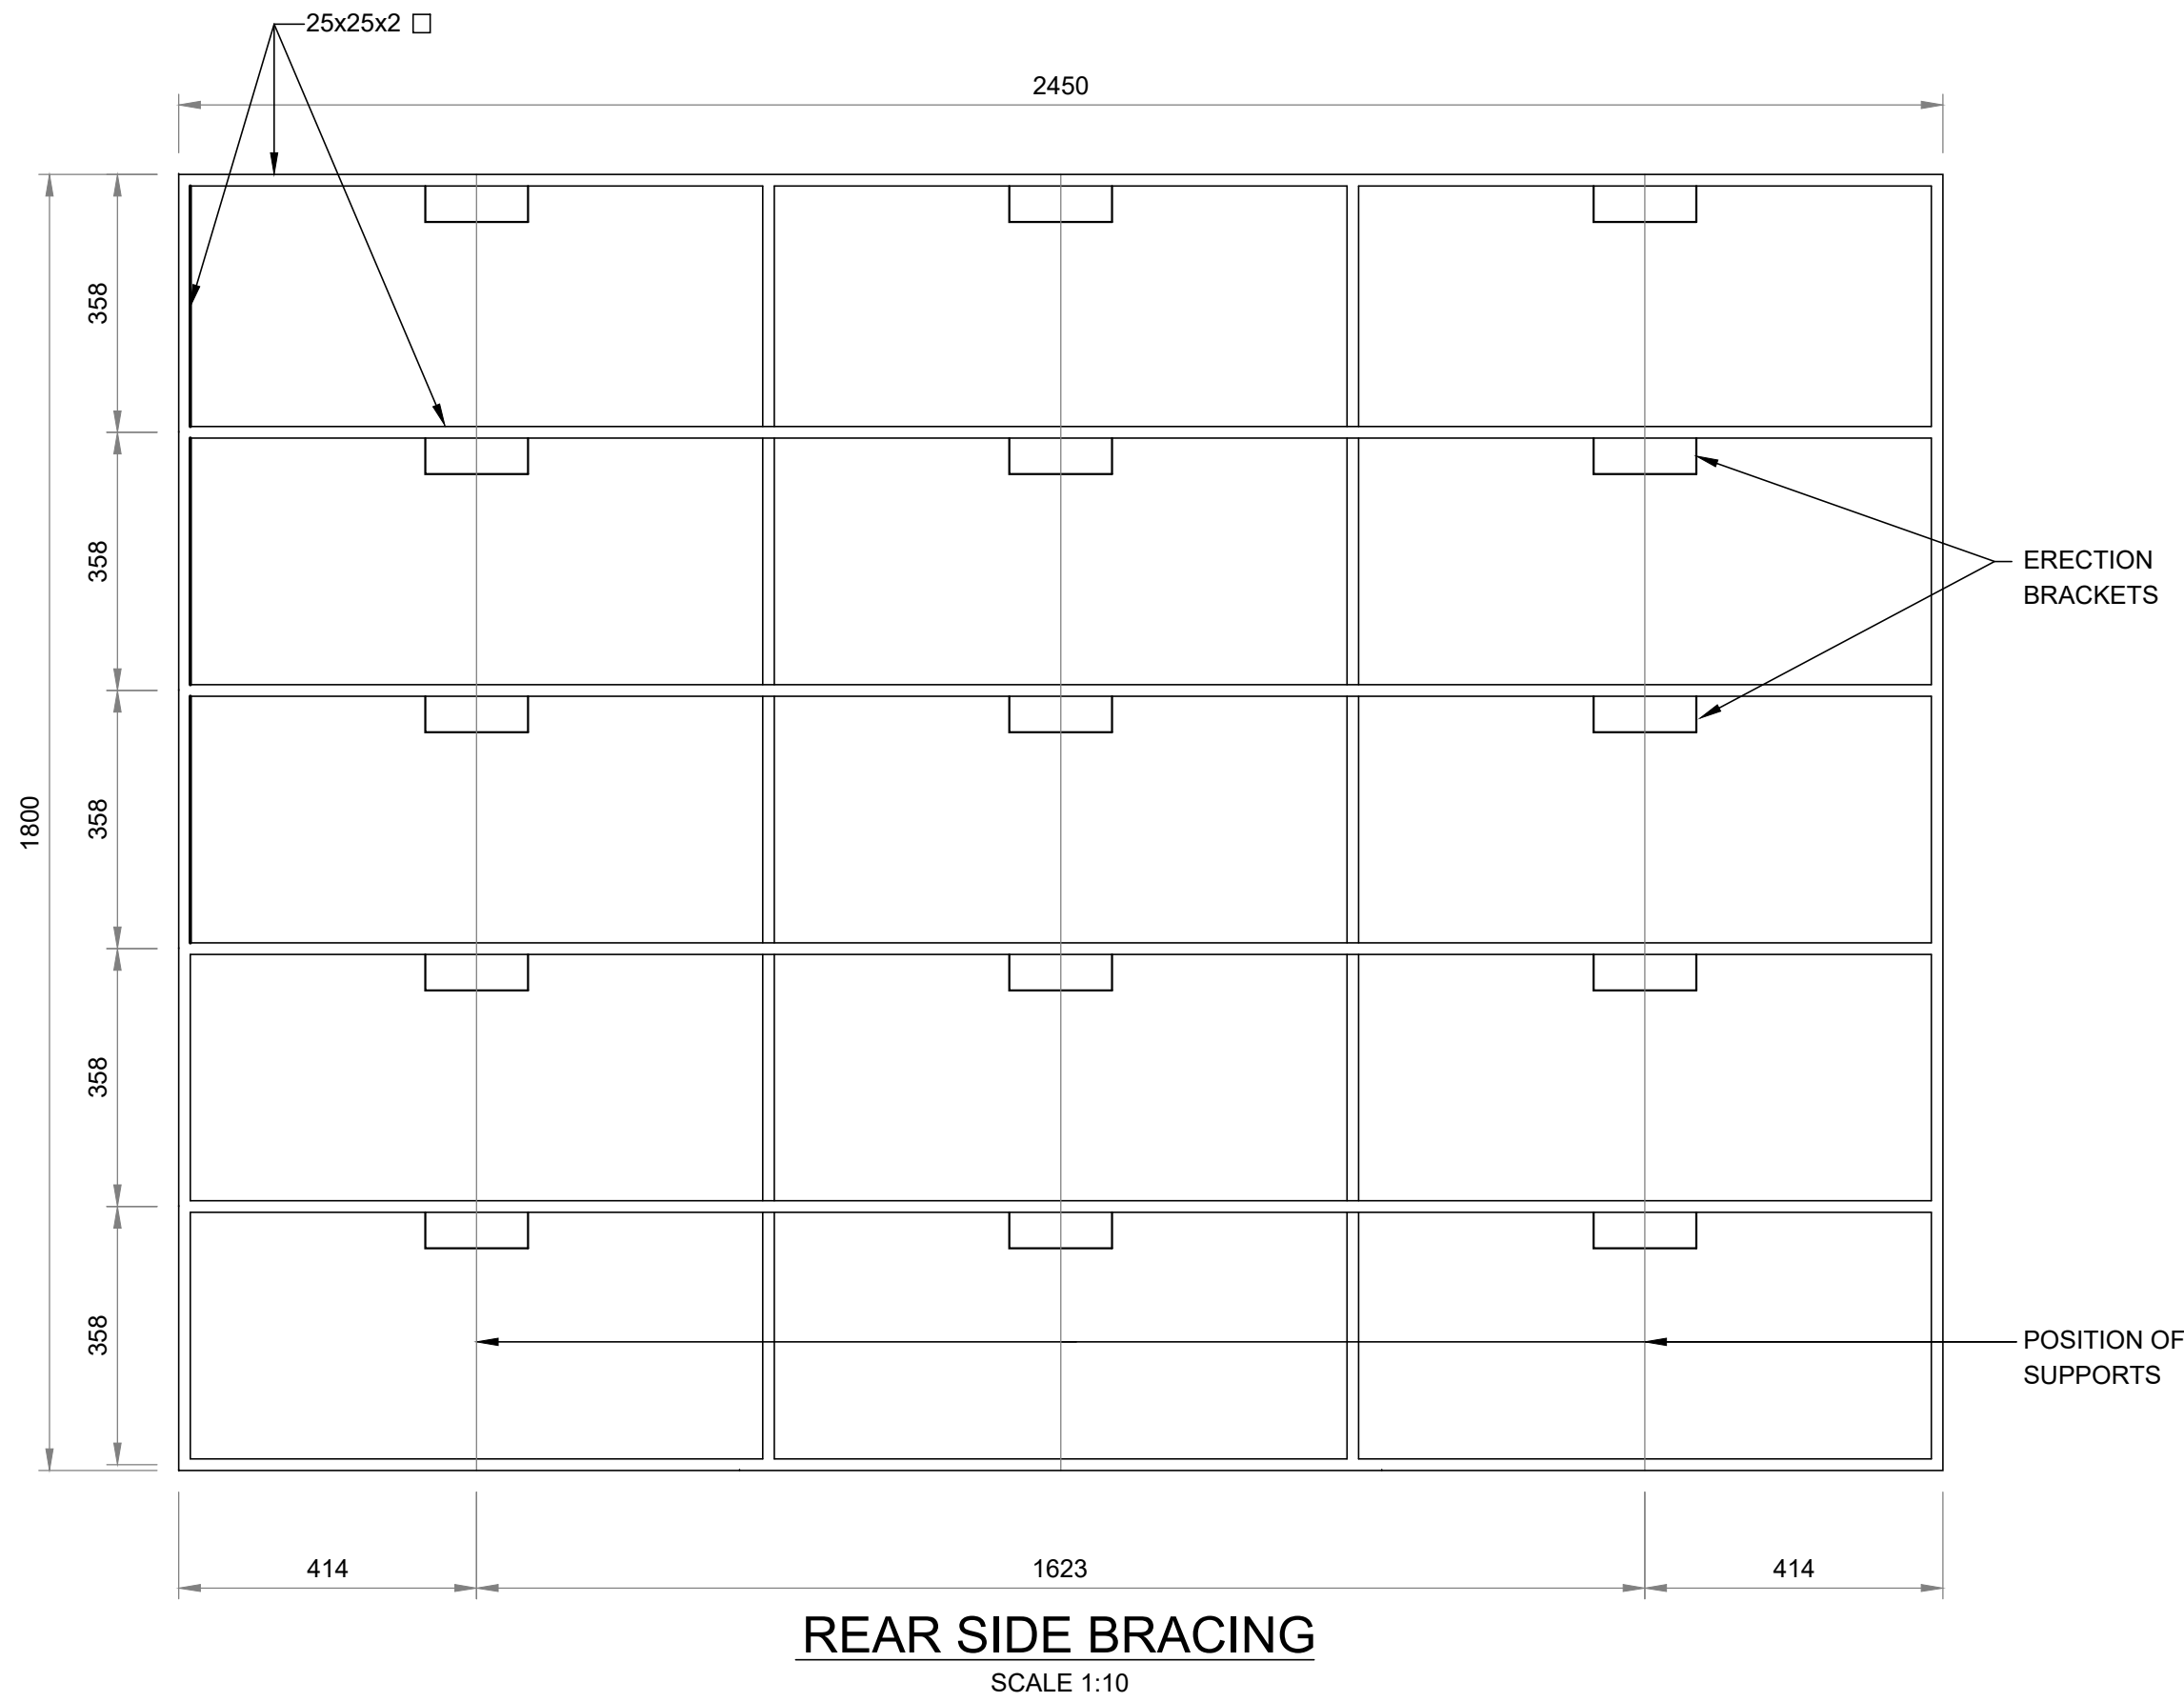


SIGN BOARD DETAIL

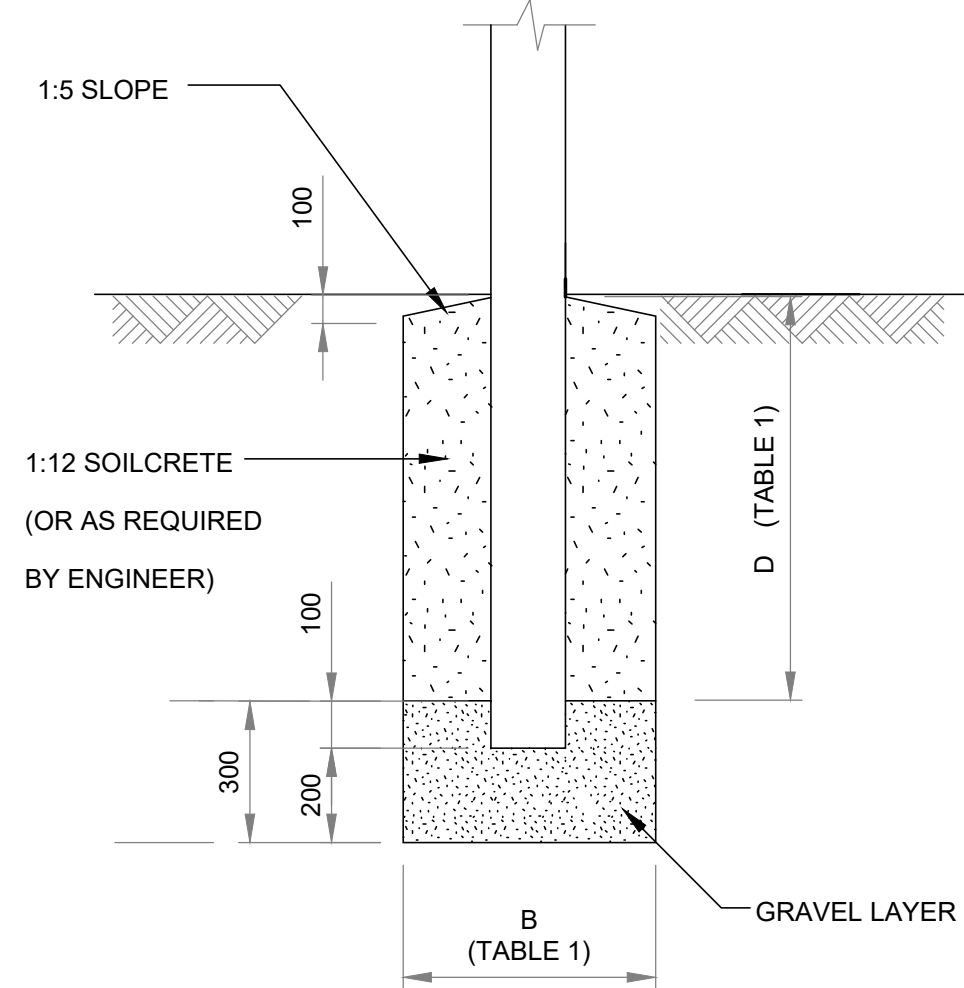


FOUNDATION DETAIL
N.T.S.

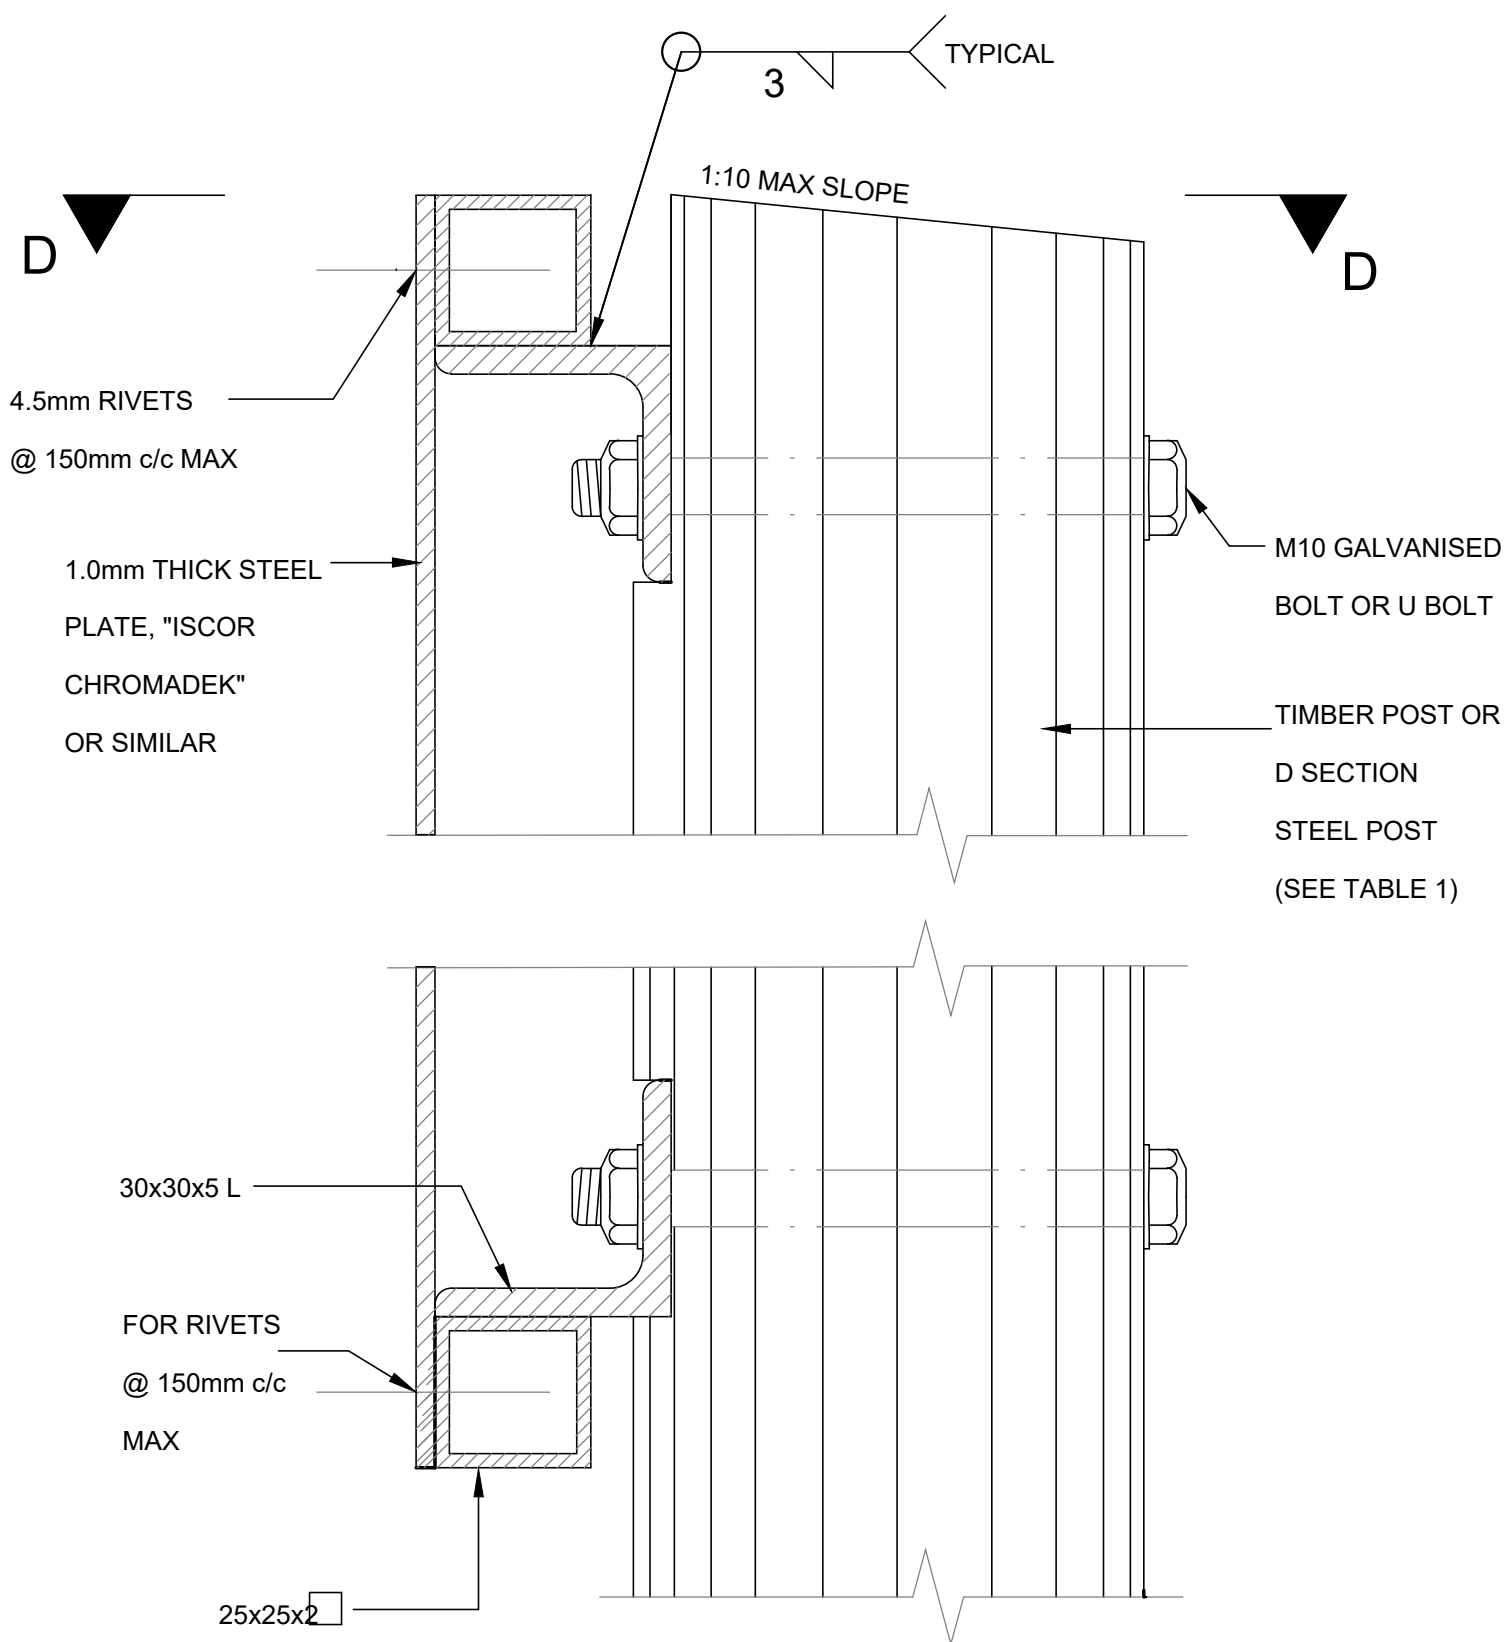

SIDE ELEVATION
N.T.S.

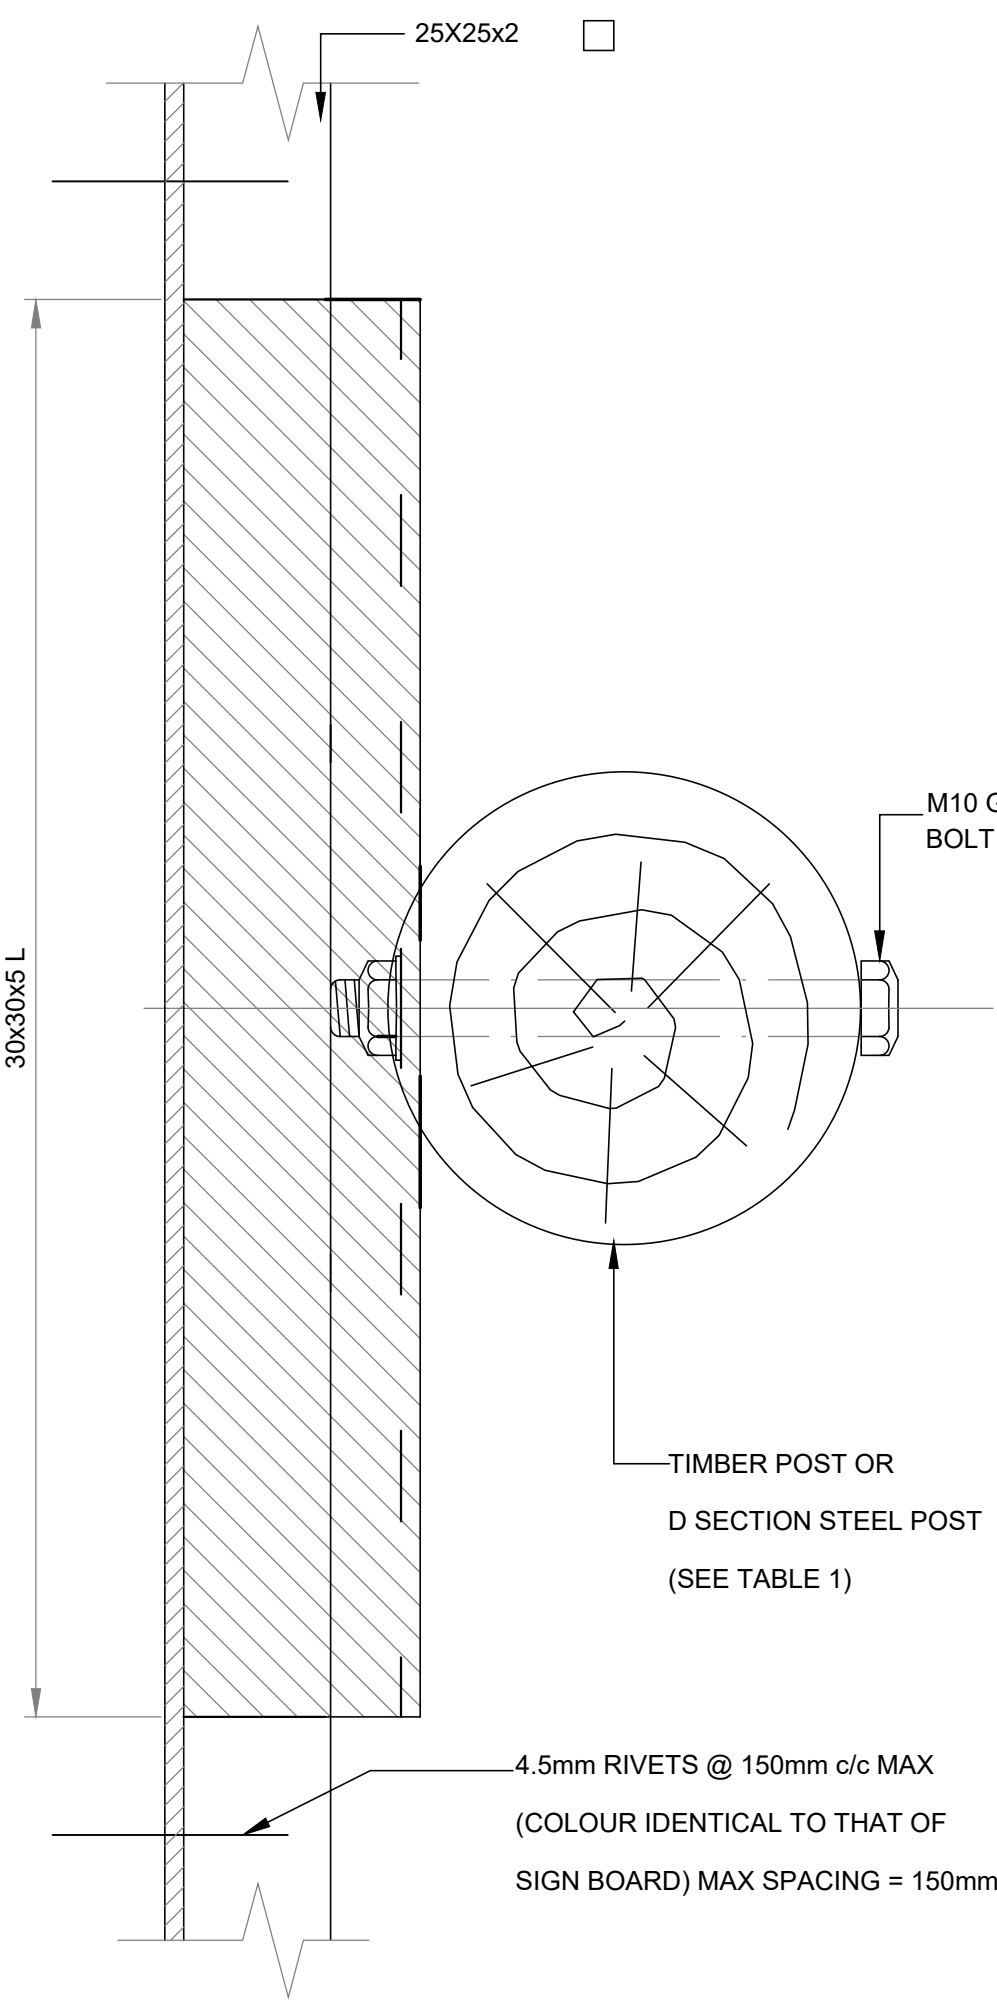

PLAN: SECTION D-D
N.T.S.

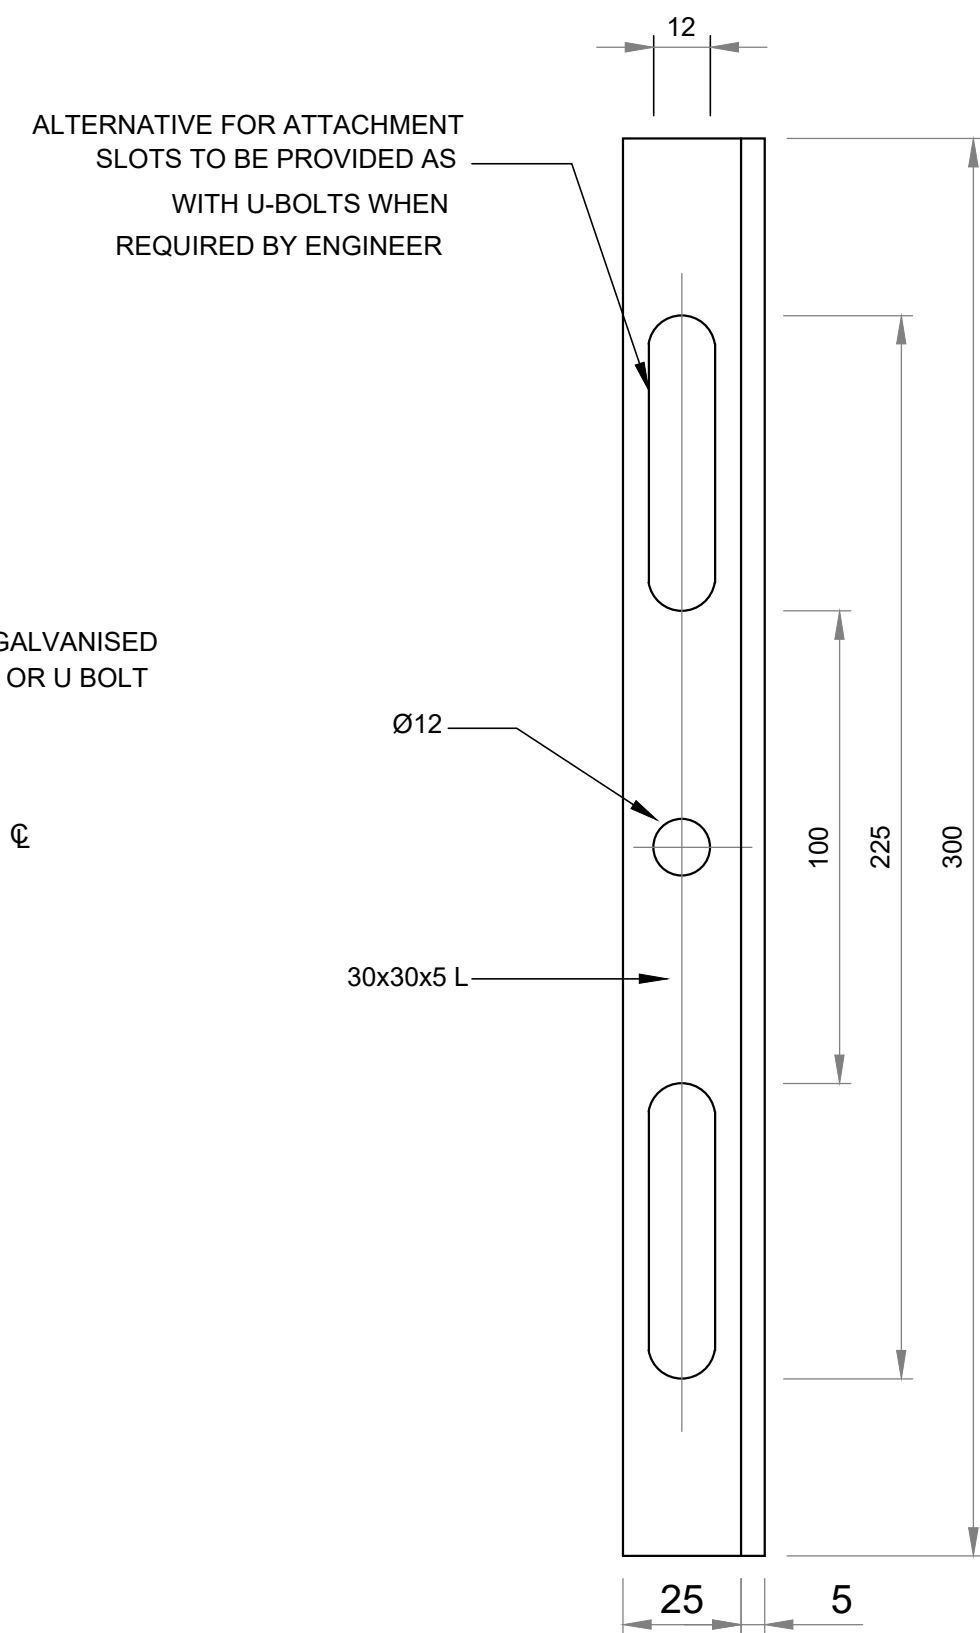

ELEVATION
ERECTION BRACKET
N.T.S.

NOTES:

1. ALL EMBLEMS TO BE DISPLAYED IN FULL COLOUR ON A SEMI-MATT WHITE BACKGROUND.
2. DESCRIPTION: MATT-BLACK, SERIES DIN B LETTERS AND NUMBERS ON A SEMI-MATT SMOKE-GREY BACKGROUND.
3. BORDER : GREEN NON-REFLECTORIZED.
4. ONE SIGN BOARD IN ENGLISH SHALL BE ERECTED AS DETERMINED BY THE ENGINEER.
5. DESCRIPTION OF WORK (NUMBER OF KILOMETRES AND TYPE OF WORK, eg "13.5 km RE= CONSTRUCTION OF ROAD P207-1"). DESCRIPTION STARTS CENTERED ON THE LEFT-HAND SIDE AND IN THE FIRST 105mm-DIMENSION BELOW
6. (a) SAFCEC EMBLEM ONLY, IF CONTRACTOR IS A MEMBER. ALL OTHER CASES, INCLUDING DEPARTMENTAL CONSTRUCTION, REMAIN BLANK.
(b) IF DEPARTMENTAL CONSTRUCTION, THE CONTRACTOR AND TELEPHONE ARE REPLACED WITH "KWAZULU NATAL PROVINCE CONSTRUCTION UNIT : TEL :"
7. IF PROJECT IS NOT FINANCED BY KWAZULU NATAL, SIGN BOARD IS ENLARGED TO ACCOMMODATE DETAILS OF FINANCING COMPANY AND HIS EMBLEM MAY APPEAR IN THE BLOCK ON THE LEFT.
8. NEW CESA LOGO TO BE OBTAINED FROM SAICE, JOHANNESBURG.

TABLE 1				
ERECTION DETAILS				
TYPE POST	UPRIGHT	STAY	D	B
TIMBER POST AND STAY	100mm	80mm	600mm	850mm
TIMBER POST	180mm	-	1000mm	1450mm
D SECTION STEEL POST	100mm x 4mm	-	1000mm	1450mm

FIXING DETAIL



water & sanitation
Department of Water and Sanitation
REPUBLIC OF SOUTH AFRICA

DEPARTMENT OF WATER AND SANITATION

Physical Address:
109 Francis Baard Street
Pretoria
0001
South Africa

Postal Address:
private Bag X315
Pretoria
0001
South Africa

CLIENT:



NKANGALA DISTRICT MUNICIPALITY

Physical Address:
2A Water Street
Midrand
1050

Telephone Number : (011) 249 2000

CLIENT:



Dr JS Moroka Local Municipality

Physical Address:
A2001/D Bongofundo Street
Sylvesters

Telephone Number : (011) 973 1101
Email : info@moroka.gov.za

Postal Address:
private Bag X4612
Westville

ENGINEER:



KUFANIKIWA
CONSULTING

Physical Address:
11 Darty Place
Darty Cloete Office park
Westville

Telephone Number : (031) 701 1038
Facsimile Number : (031) 701 0963
E-mail Address : www.kufanikiwa.co.za
Website Link or Address : info@kufanikiwa.co.za

DRAWING REVISIONS

REV	DATE	DRAWN	CHECKED	DESCRIPTION

PROJECT NAME:

WESTERN HIGHVELD BULK WATER
SCHEME

DRAWING TITLE:

CONTRACT NAMEBOARD

RESPONSIBLE PERSONNEL	SIGNATURE	DATE
DESIGNED	S. NGCOBO	
DRAWN	L. JIYANA	
CHECKED	S. MINGADI (PR Tech ENG)	
APPROVED	M. NDLOVU (PR Tech Eng)	
SCALE	AS SHOWN	

APPROVED : CLIENT

SIGNATURE

DATE

PROJECT NUMBER	DRAWING NUMBER
VU-WTR-21-006	206

STAGE	SHEET SIZE	SHEET No.	REVISION
TENDER	A0	1 OF 1	0

COPYRIGHT RESERVED

FOR TENDER