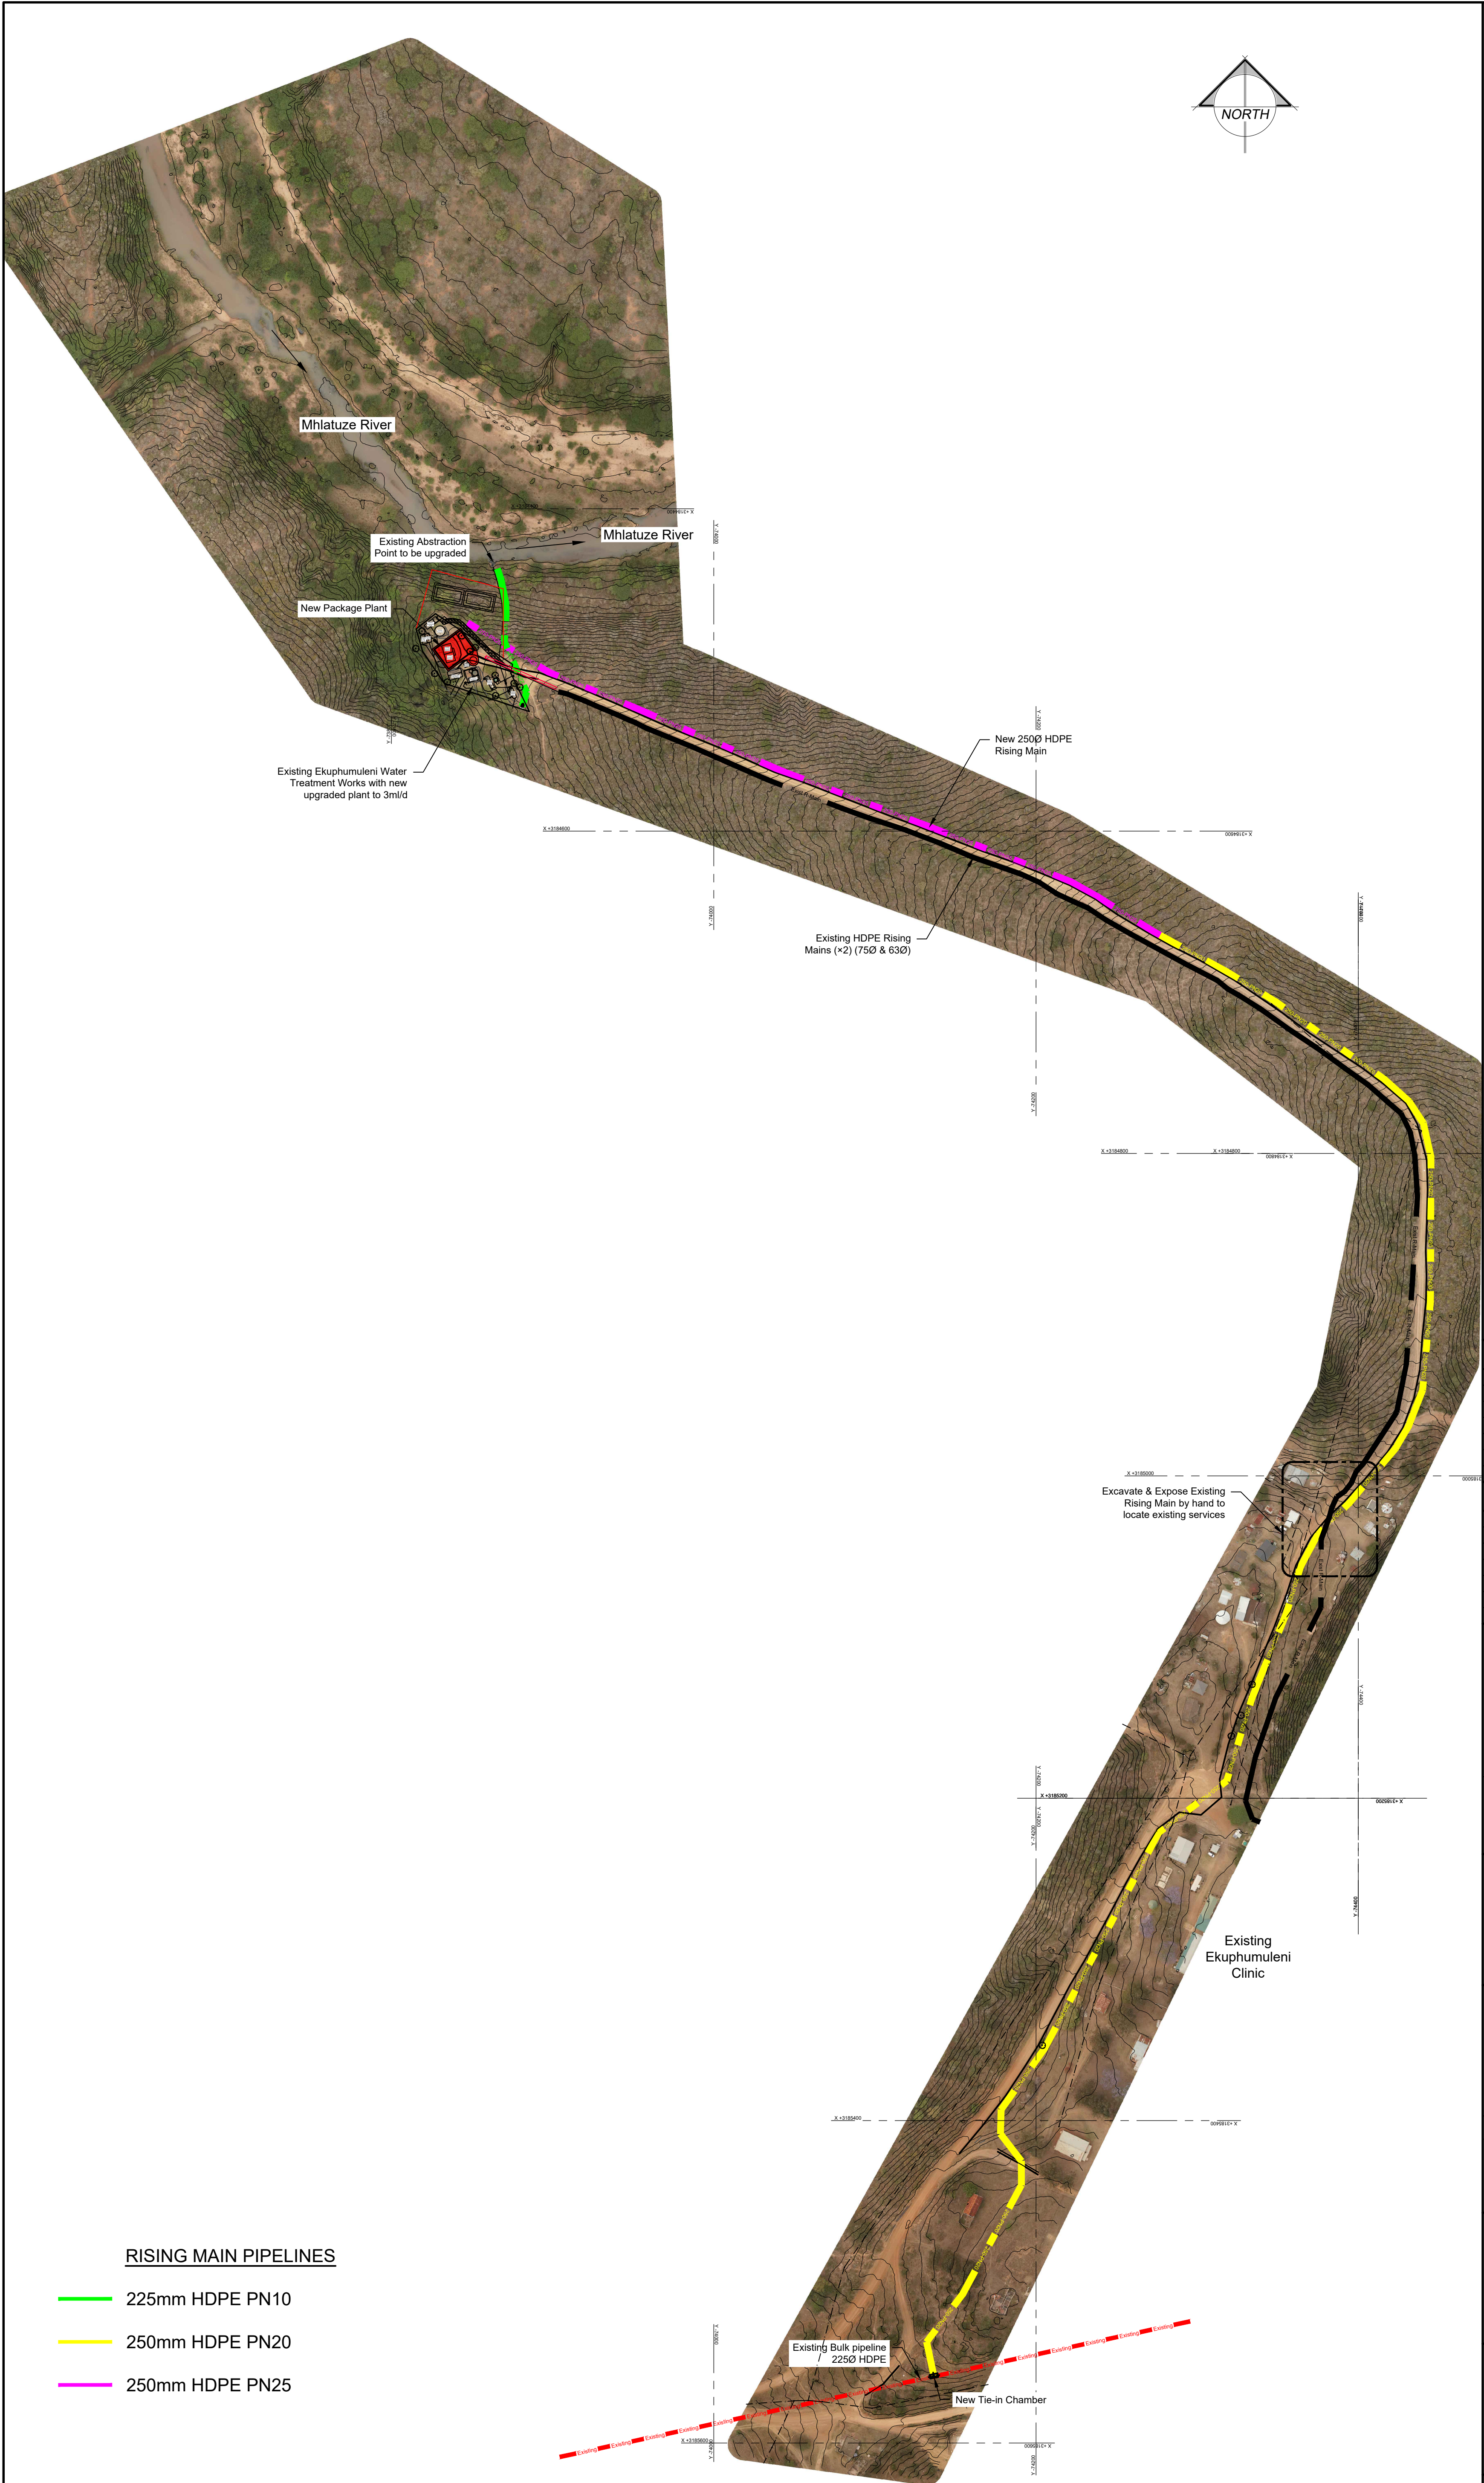


Do not scale off drawing - ASK THE ENGINEER IF UNCERTAIN!
Any discrepancies between any drawings must be clarified before work is continued on site.

FOR TENDER PURPOSES ONLY

READ THIS DRAWING IN CONJUNCTION WITH

Drawing Number	Drawing Description

AMENDMENTS

Rev.	Date	Description

ECA CONSULTING

Civil and Structural Engineers

VRVHEID OFFICE:
161 High Street |
Vryheid | Kwa Zulu Natal |
RSA
vryheid@ecacsaconsult.co.za
Tel: +27 (0)34 983 3625
www.ecacsaconsult.co.za
OTHER OFFICES:
MBOMBELA | GAUTENG |
PIETERMARITZBURG |
LADYSMITH

Approved by Engineer: Name: J.W. Janse v Rensburg
Designation: PrTechEng
ECSA Reg.: 201070143
Signature: _____
Date: 28 Oct 2022

Project Funder/ Client:
mig
Municipal Infrastructure Grant



Project Implementing Agent:
KING CETSHWAYO DISTRICT MUNICIPALITY




Approved by Client:
Name: _____
Signature: _____ Date: _____


Project:
KWAHLOKOHLKO SSA5: PHASE 4 BULK AUGMENTATION

Drawing description:
SITE LAYOUT PLAN


Drawn: G.D Bezuidenhout Date: Jul 2022
Scale/s: As Shown
Drawing number: 22-032-V-PH4-01-01 Rev.: 00

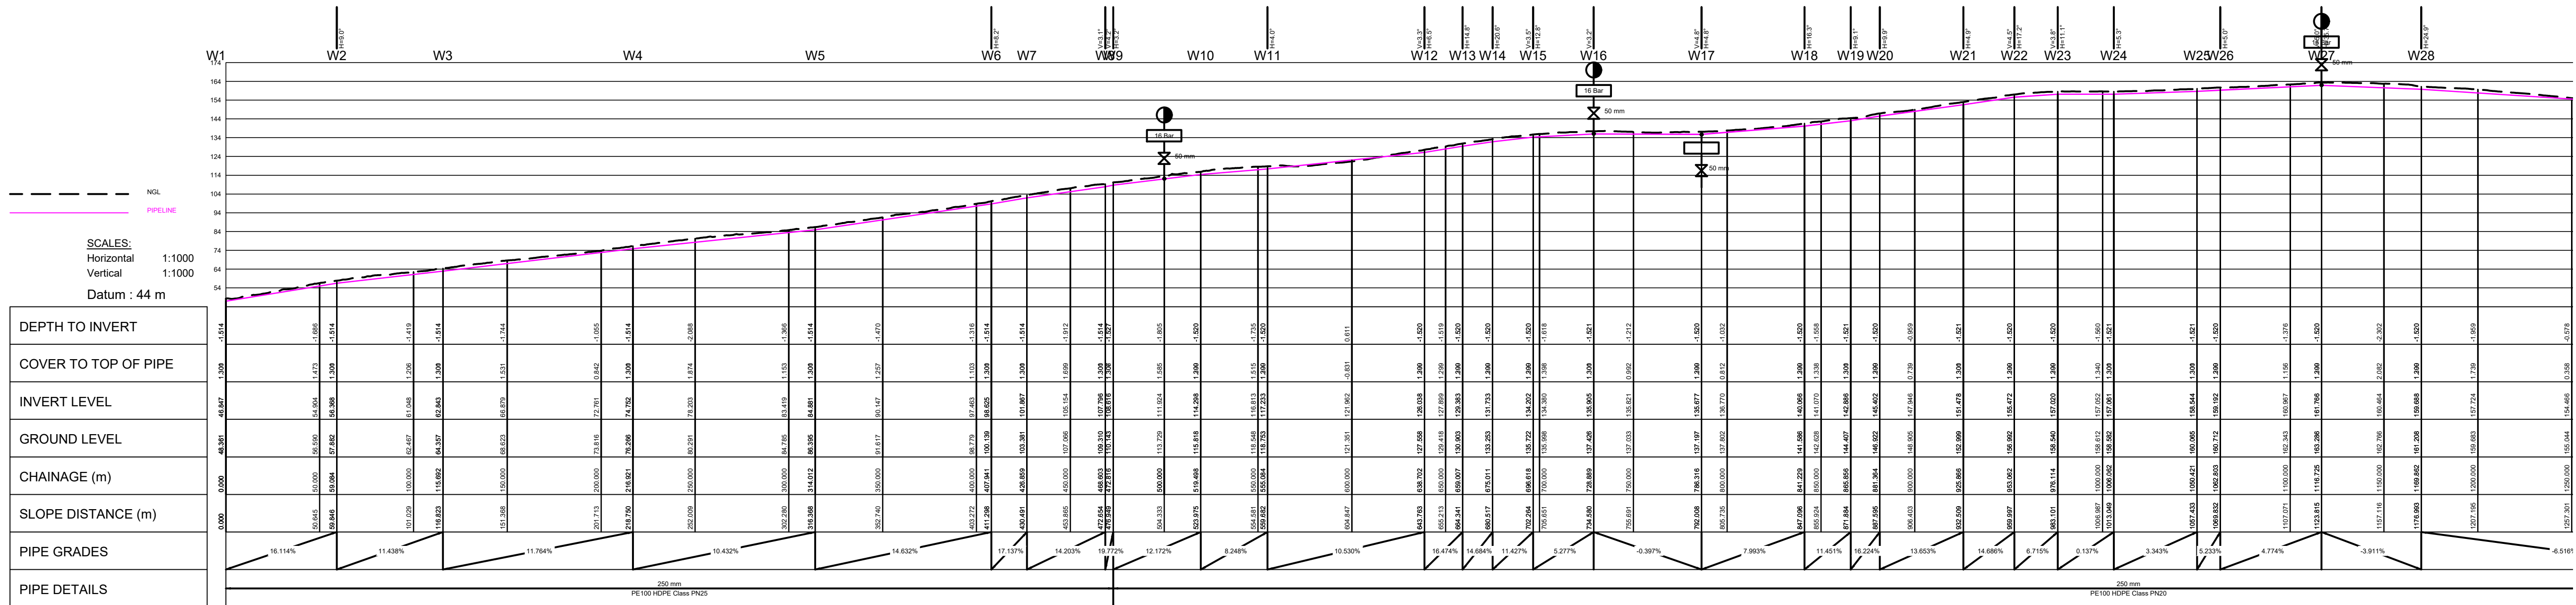

RIISING MAIN LONG SECTION
Scale 1 : 2000

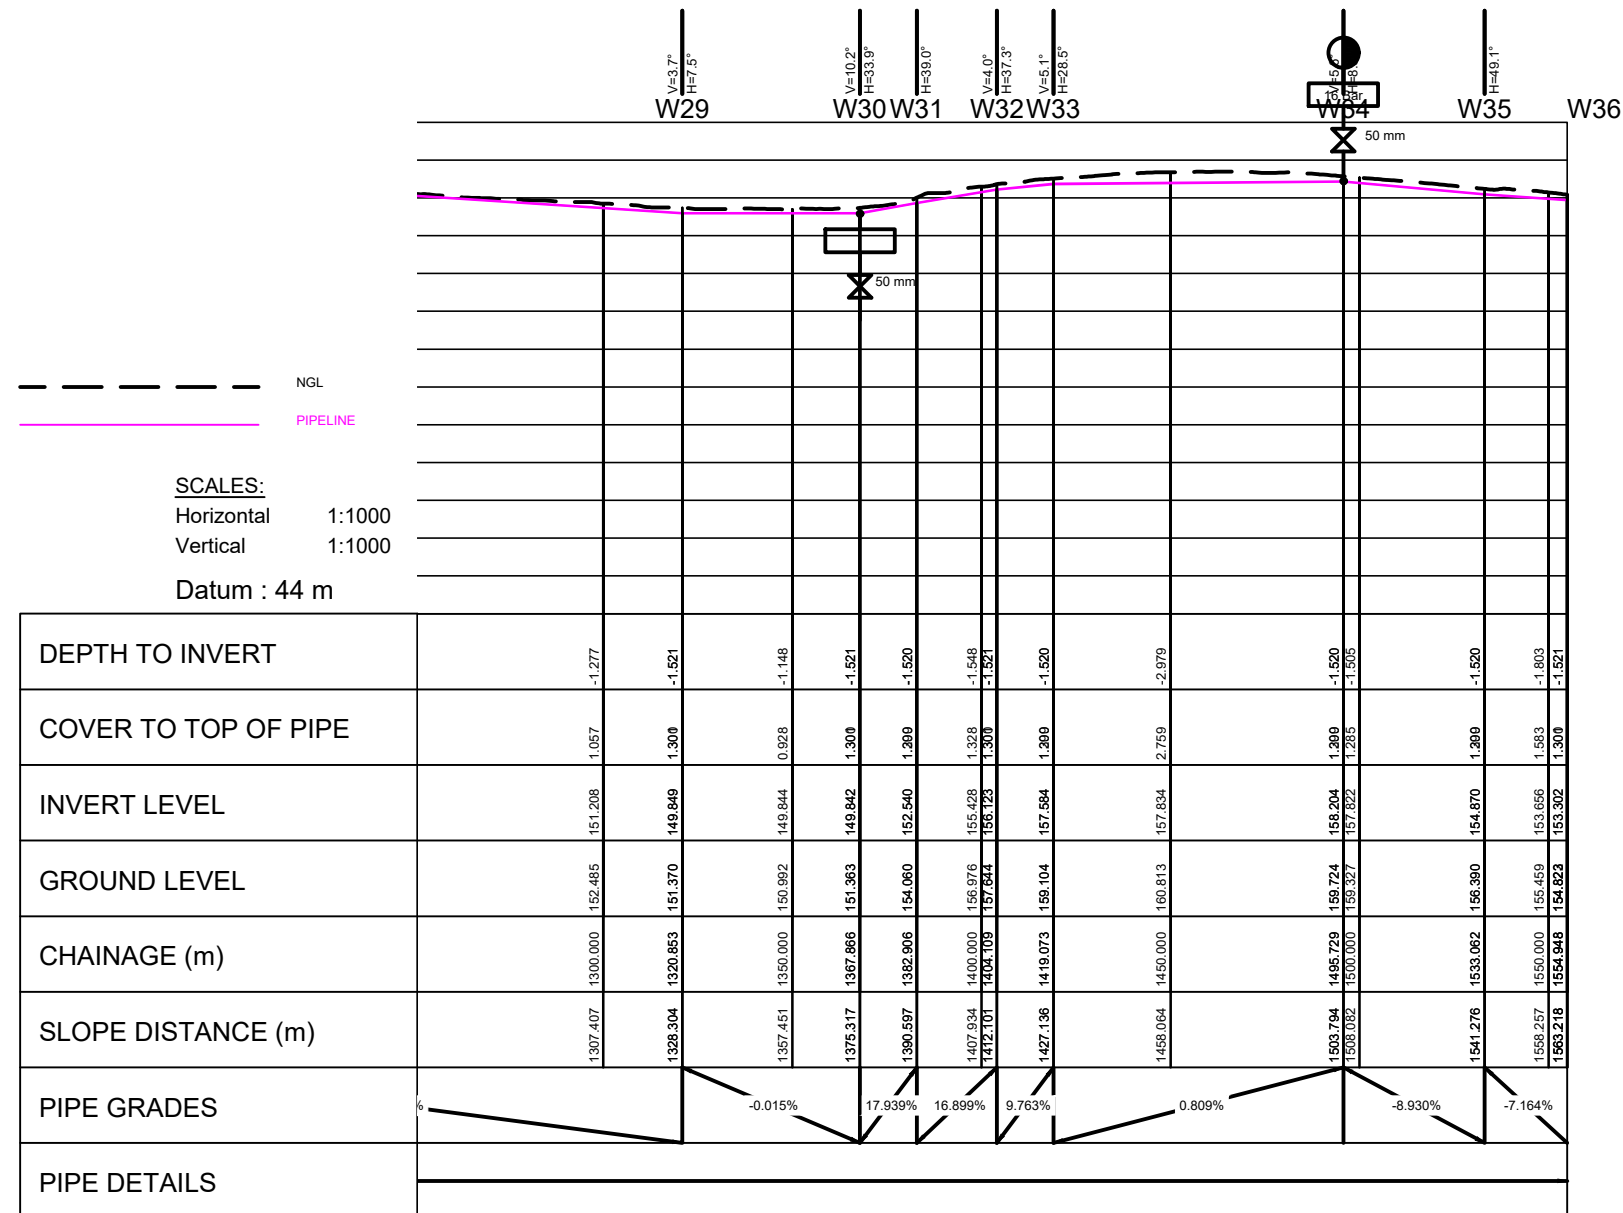

RIISING MAIN LONG SECTION
(CONTINUED)
Scale 1 : 2000

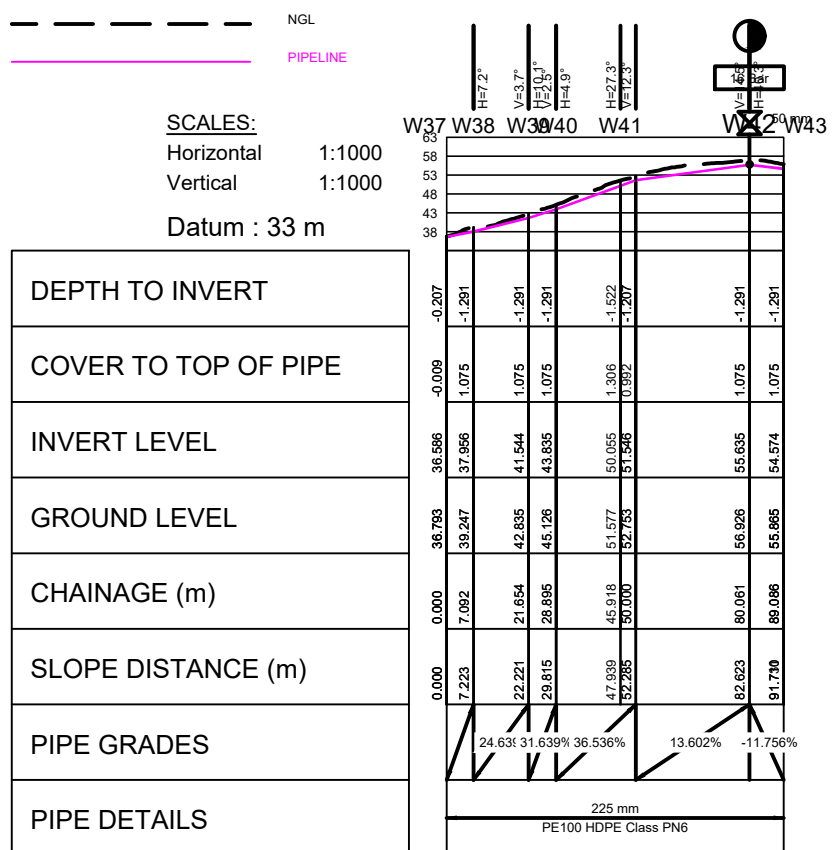

RAW WATER RISING MAIN
LONG SECTION
Scale 1 : 2000

Do not scale off drawing - ASK THE ENGINEER IF UNCERTAIN!
Any discrepancies between any drawings must be clarified before work is continued on site.

FOR TENDER
PURPOSES ONLY

READ THIS DRAWING IN CONJUNCTION WITH

Drawing Number	Drawing Description

AMENDMENTS

Rev.	Date	Description

ECA CONSULTING

Civil and Structural Engineers

VRVHEID OFFICE:
161 High Street |
Vryheid | Kwa Zulu Natal |
RSA
vryheid@ecaconsult.co.za
Tel: +27 (0)34 983 2825
www.ecaconsult.co.za

OTHER OFFICES:
MBOMBELA | GAUTENG |
PIETERMARITZBURG |
LADYSMITH

Approved by Engineer: _____ Signature: _____
Name: J.W. Janse v Rensburg
Designation: PrTechEng
ECSA Reg.: 201070143 Date: 28 Oct 2022

Project Funder/ Client:

**mig**
Municipal
Infrastructure
Grant



Project Implementing Agent:

**KING
CETSHWAYO
DISTRICT
MUNICIPALITY**

**KING CETSHWAYO**
DISTRICT MUNICIPALITY

Approved by Client: _____
Name: _____
Signature: _____ Date: _____


Project:
**KWAHLOKOHLOKO SSA5:
PHASE 4 BULK
AUGMENTATION**

Drawing description:
LONG SECTIONS

Drawn: G.D Bezuidenhout Date: Jul 2022
Scale/s: As Shown
Drawing number: 22-032-V-PH4-01-02 Rev.: 00



PLAN
Scale 1:1000

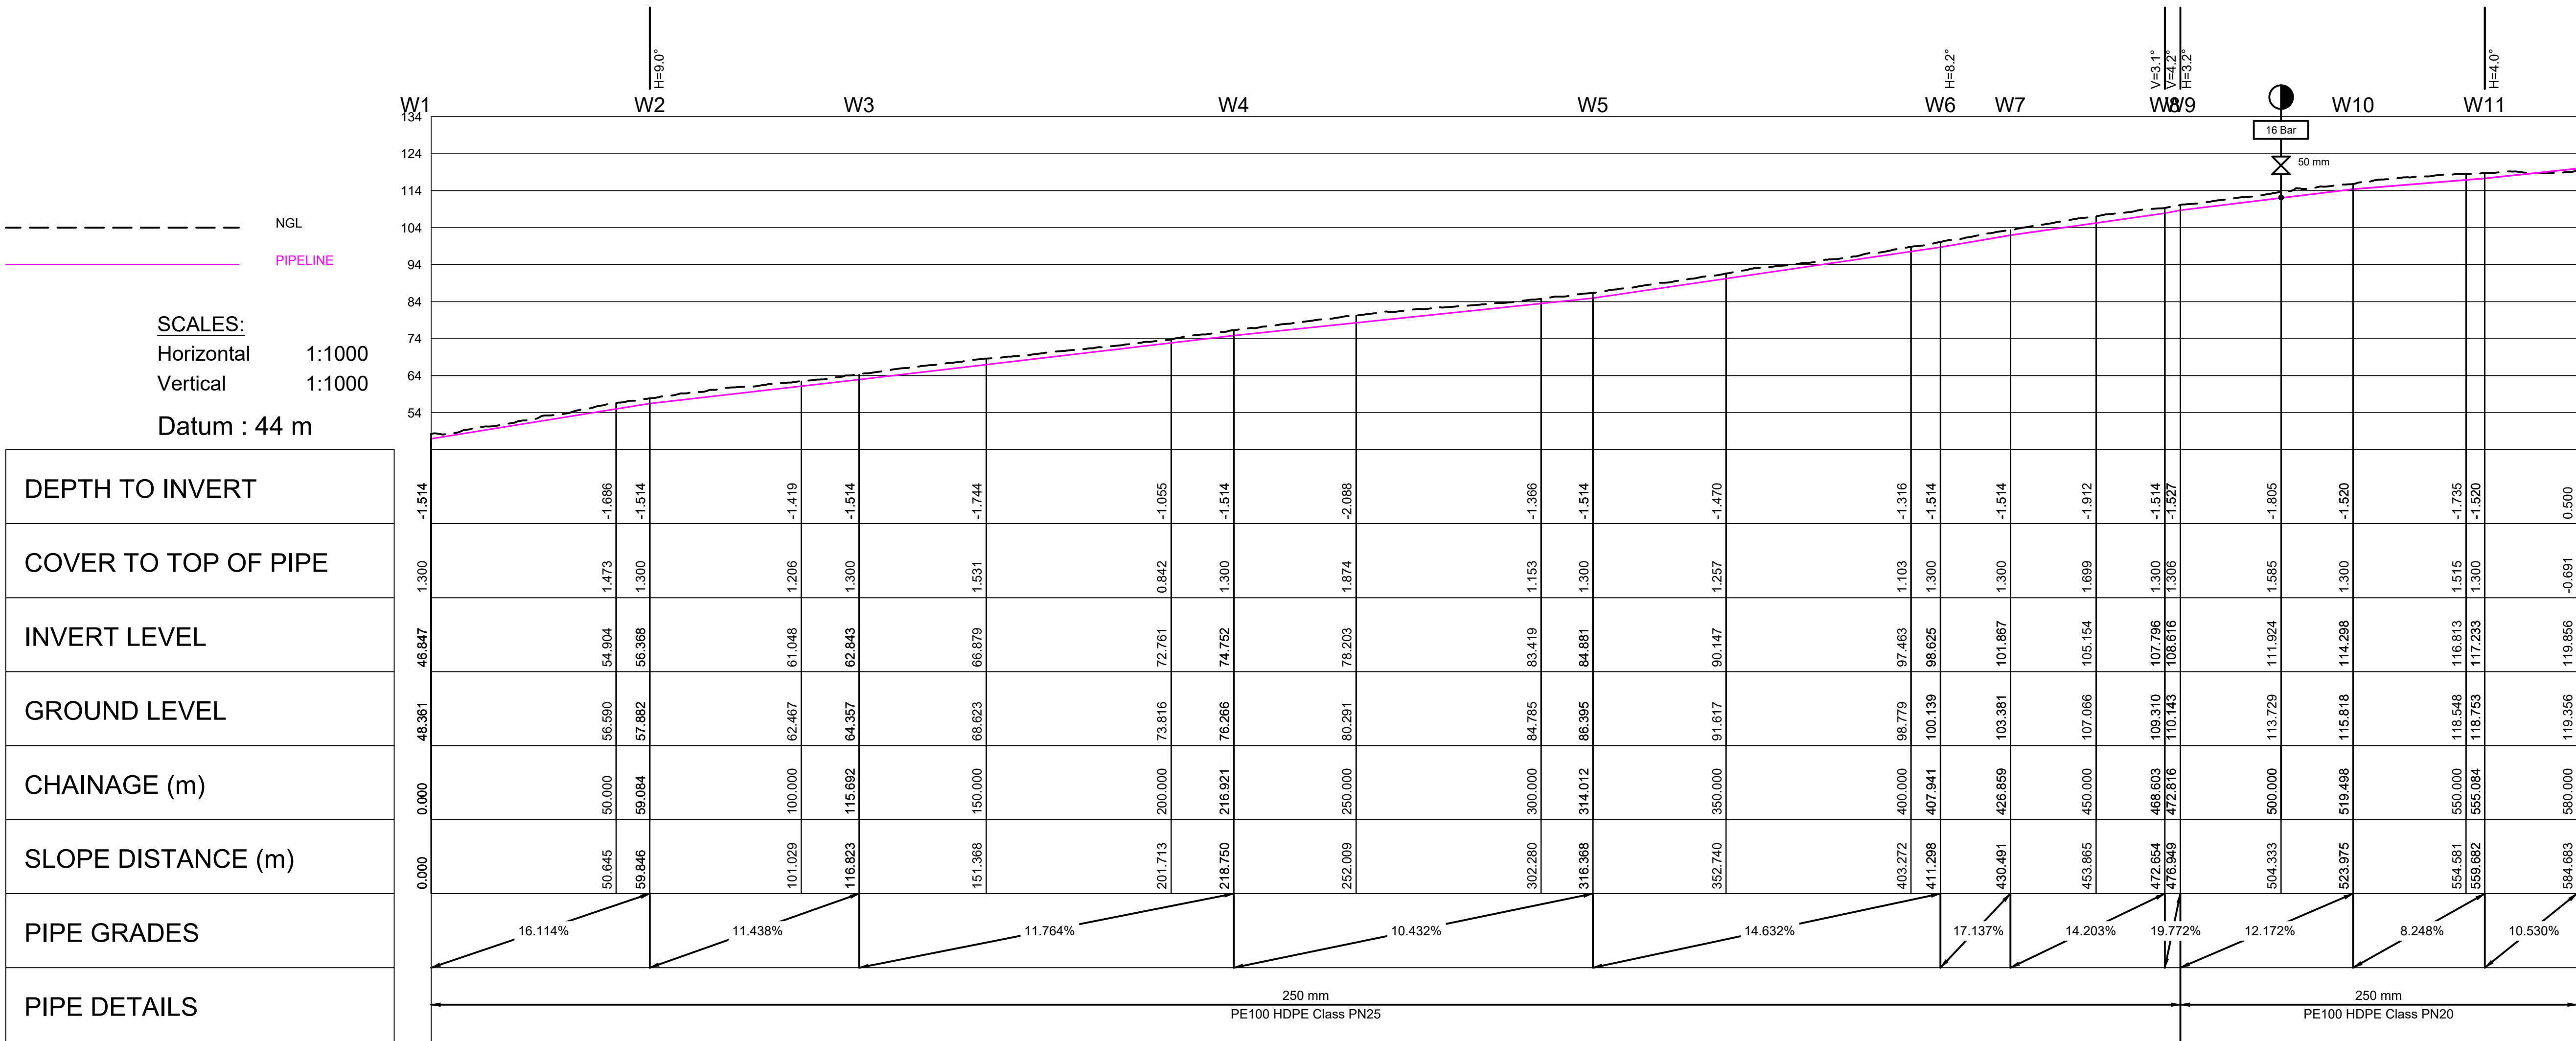

LONG SECTION
Scale 1:1000

Do not scale off drawing - ASK THE ENGINEER IF UNCERTAIN!
Any discrepancies between any drawings must be clarified before work is continued on site.

FOR TENDER
PURPOSES ONLY

READ THIS DRAWING IN CONJUNCTION WITH

Drawing Number	Drawing Description

AMENDMENTS

Rev.	Date	Description

ECA CONSULTING

Civil and Structural Engineers

VRVHEID OFFICE:
161 High Street |
Vryheid | Kwa Zulu Natal |
RSA
vryheid@ecaconsult.co.za
Tel: +27 (0)34 983 2825
www.ecaconsult.co.za
OTHER OFFICES:
MBOMBELA | GAUTENG |
PIETERMARITZBURG |
LADYSMITH

Approved by Engineer: Signature: _____
Name: J.W. Janse v Rensburg
Designation: PrTechEng
ECSA Reg.: 201070143 Date: 28 Oct 2022

Project Funder/ Client:

Municipal
Infrastructure
Grant

Project Implementing Agent:

**KING
CETSHWAYO
DISTRICT
MUNICIPALITY**

DISTRICT MUNICIPALITY

Approved by Client:

Name: _____

Signature: _____ Date: _____

Project:

**KWAHLOKOHLOKO SSA5:
PHASE 4 BULK
AUGMENTATION**


Drawing description:

**RIISING MAIN PLAN &
LONG SECTION
SHEET 01**


Drawn: G.D Bezuidenhout Date: Jul 2022

Scale/s: As Shown

Drawing number: 22-032-V-PH4-01-03 Rev.: 00

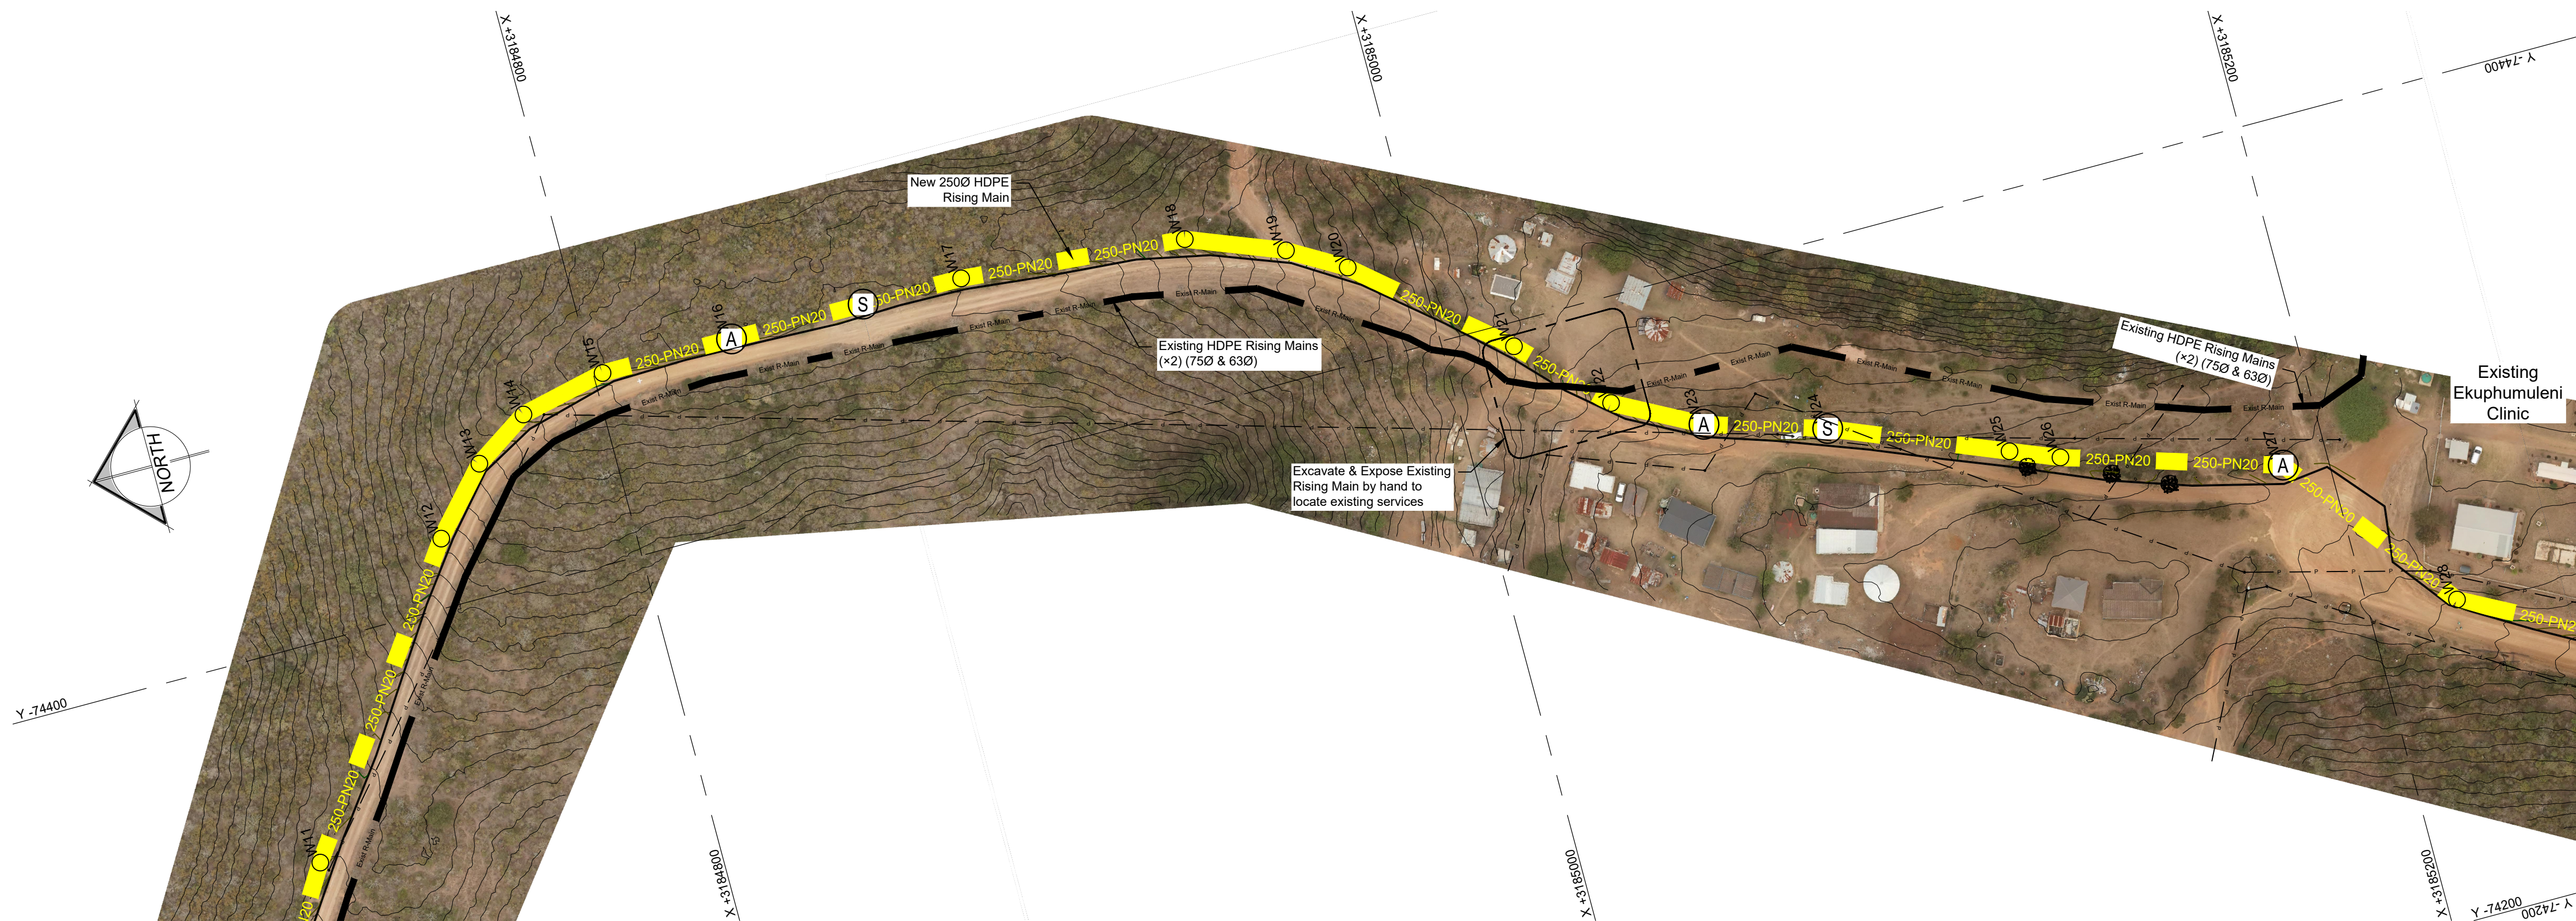

PLAN
Scale 1:1000

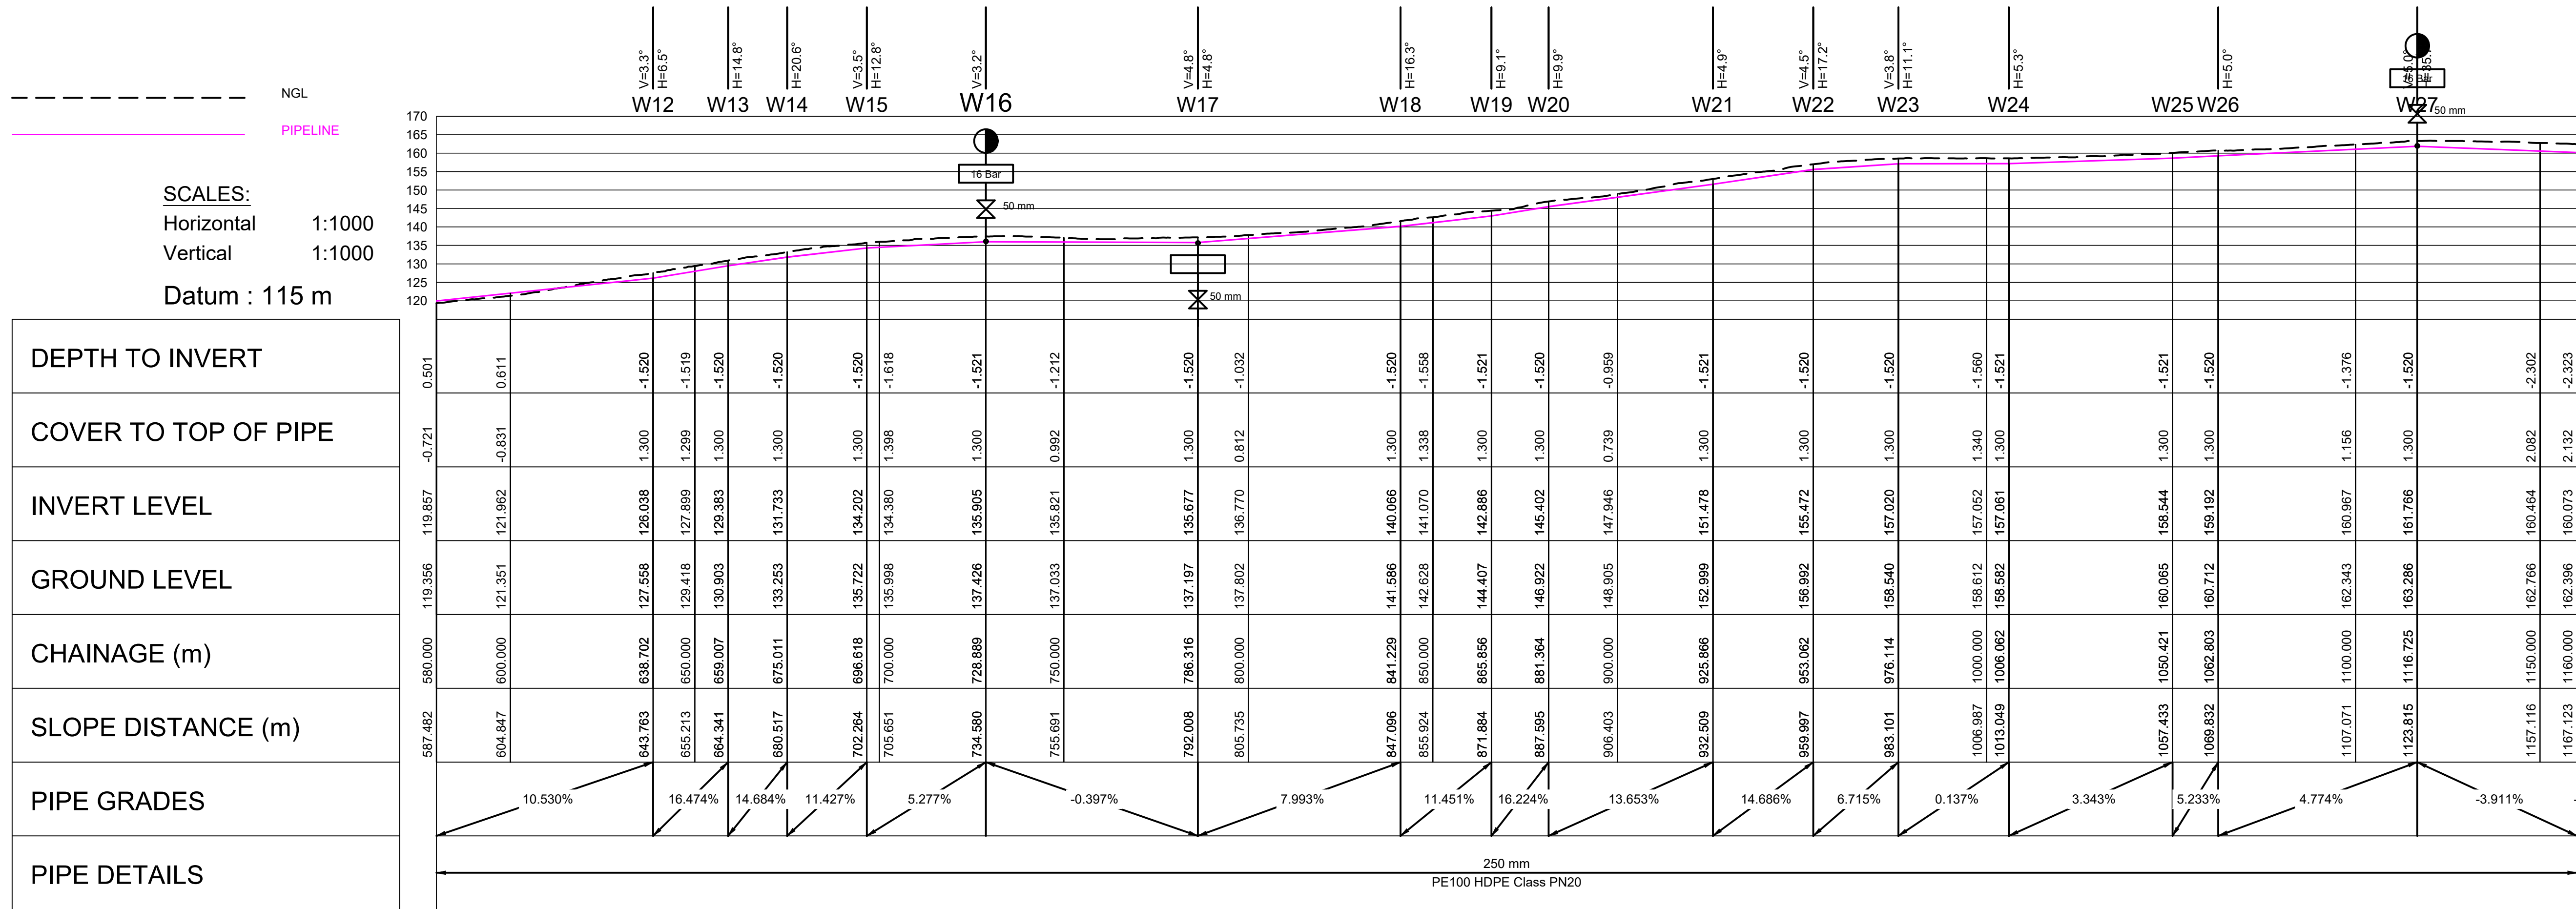

PROFILE
Scale 1:1000

Do not scale off drawing - ASK THE ENGINEER IF UNCERTAIN!
Any discrepancies between any drawings must be clarified before work is continued on site.

FOR TENDER
PURPOSES ONLY

READ THIS DRAWING IN CONJUNCTION WITH

Drawing Number	Drawing Description

AMENDMENTS

Rev.	Date	Description

ECA CONSULTING
Civil and Structural Engineers
Company Reg.: 2004/019299/07
ISO Registered 9001:2015

VRVHEID OFFICE:
161 High Street |
Vryheid | Kwa Zulu Natal |
RSA
vryheid@ecaconsult.co.za
Tel: +27 (0)34 983 2825
www.ecaconsult.co.za
OTHER OFFICES:
MBOMBELA | GAUTENG |
PIETERMARITZBURG |
LADYSMITH

Approved by Engineer: _____ Signature: _____
Name: J.W. Janse v Rensburg
Designation: PrTechEng
ECSA Reg.: 201070143 Date: 28 Oct 2022

Project Funder/ Client:
mig
Municipal Infrastructure Grant

Project Implementing Agent:
KING CETSHWAYO DISTRICT MUNICIPALITY

Approved by Client: _____
Name: _____
Signature: _____ Date: _____

Project:
KWAHLOKOHLOKO SSA5: PHASE 4 BULK AUGMENTATION

Drawing description:
RIISING MAIN PLAN & LONG SECTION SHEET 02

Drawn: G.D Bezuidenhout Date: Jul 2022
Scale/s: As Shown
Drawing number: 22-032-V-PH4-01-04 Rev.: 00




PLAN
Scale 1:1000

--- NGL
--- PIPELINE

SCALES:
Horizontal 1:1000
Vertical 1:1000
Datum : 146 m

DEPTH TO INVERT
COVER TO TOP OF PIPE
INVERT LEVEL
GROUND LEVEL
CHAINAGE (m)
SLOPE DISTANCE (m)
PIPE GRADES
PIPE DETAILS

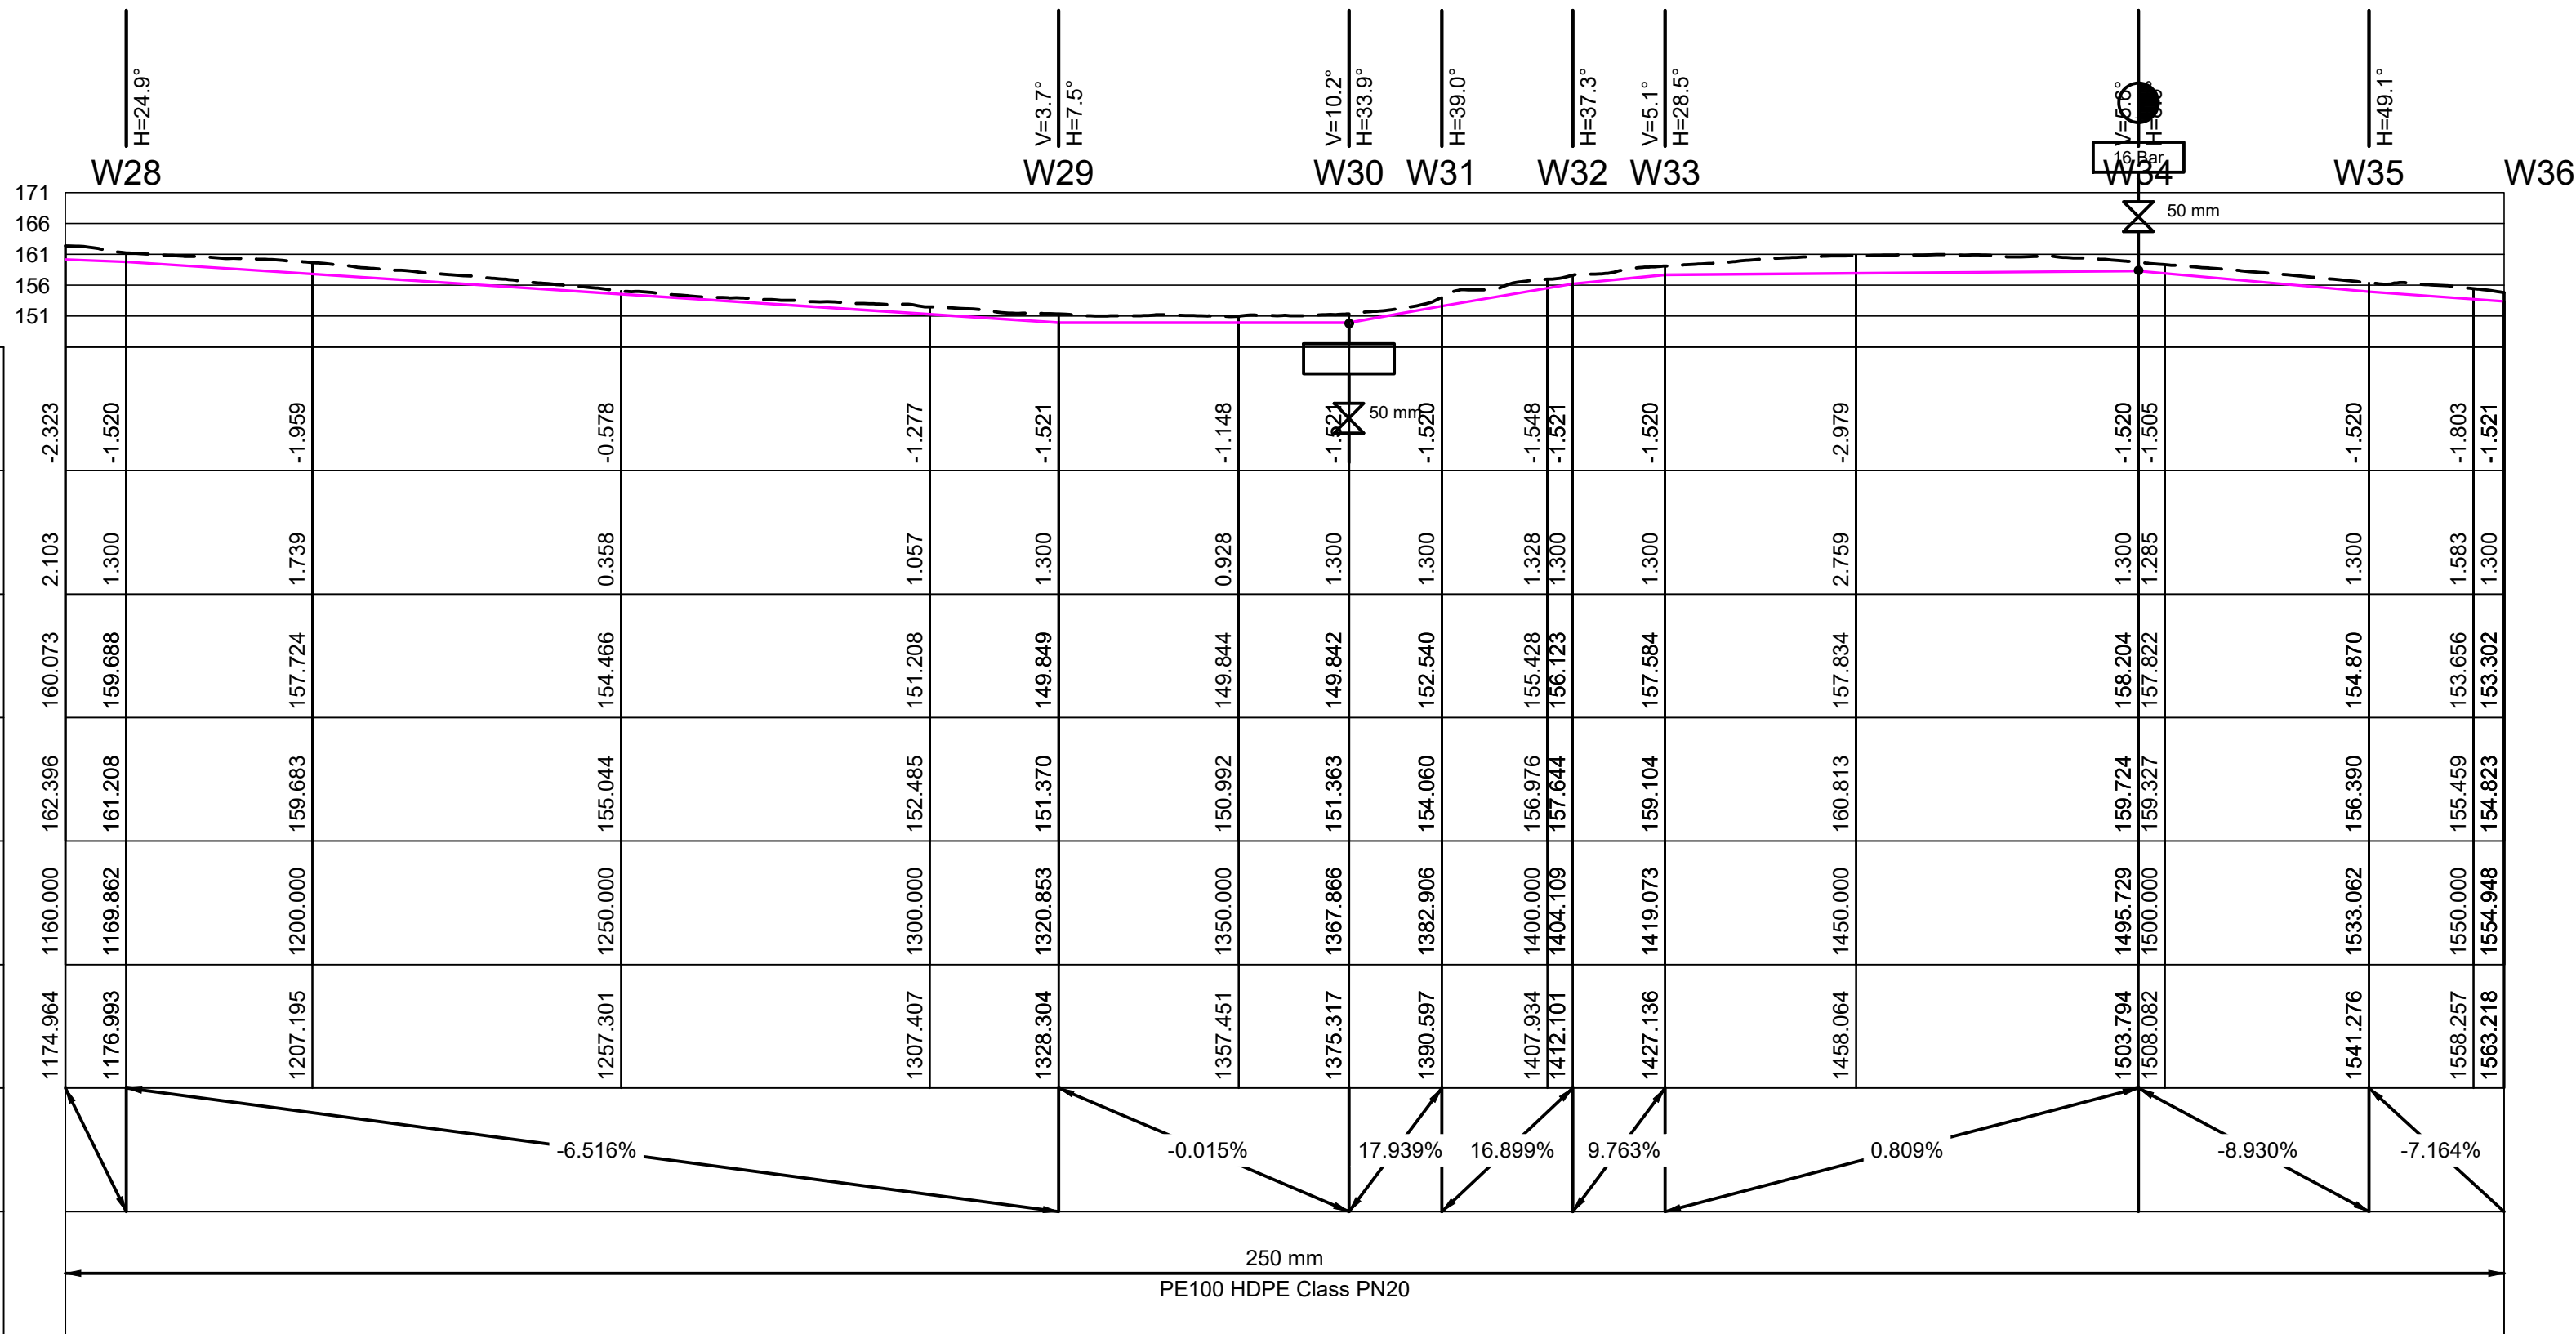

PROFILE
Scale 1:1000

Do not scale off drawing - ASK THE ENGINEER IF UNCERTAIN!
Any discrepancies between any drawings must be clarified before work is continued on site.

FOR TENDER
PURPOSES ONLY

READ THIS DRAWING IN CONJUNCTION WITH

Drawing Number	Drawing Description

AMENDMENTS

Rev.	Date	Description

ECA CONSULTING

Civil and Structural Engineers

VRVHEID OFFICE:
161 High Street |
Vryheid | Kwa Zulu Natal |
RSA
vryheid@ecaconsult.co.za
Tel: +27 (0)34 983 2825
www.ecaconsult.co.za
OTHER OFFICES:
MBOMBELA | GAUTENG |
PIETERMARITZBURG |
LADYSMITH

Approved by Engineer: Signature:
Name: J.W. Janse v Rensburg
Designation: PrTechEng
ECSA Reg.: 201070143 Date: 28 Oct 2022

Project Funder/ Client:
mig
Municipal Infrastructure Grant


Project Implementing Agent:
KING CETSHWAYO DISTRICT MUNICIPALITY

Approved by Client:
Name: _____
Signature: _____ Date: _____

Project:
**KWAHLOKOHLOKO SSA5:
PHASE 4 BULK
AUGMENTATION**

Drawing description:
**RIISING MAIN PLAN &
LONG SECTION
SHEET 03**


Drawn: G.D Bezuidenhout Date: Jul 2022
Scale/s: As Shown
Drawing number: 22-032-V-PH4-01-05 Rev.: 00

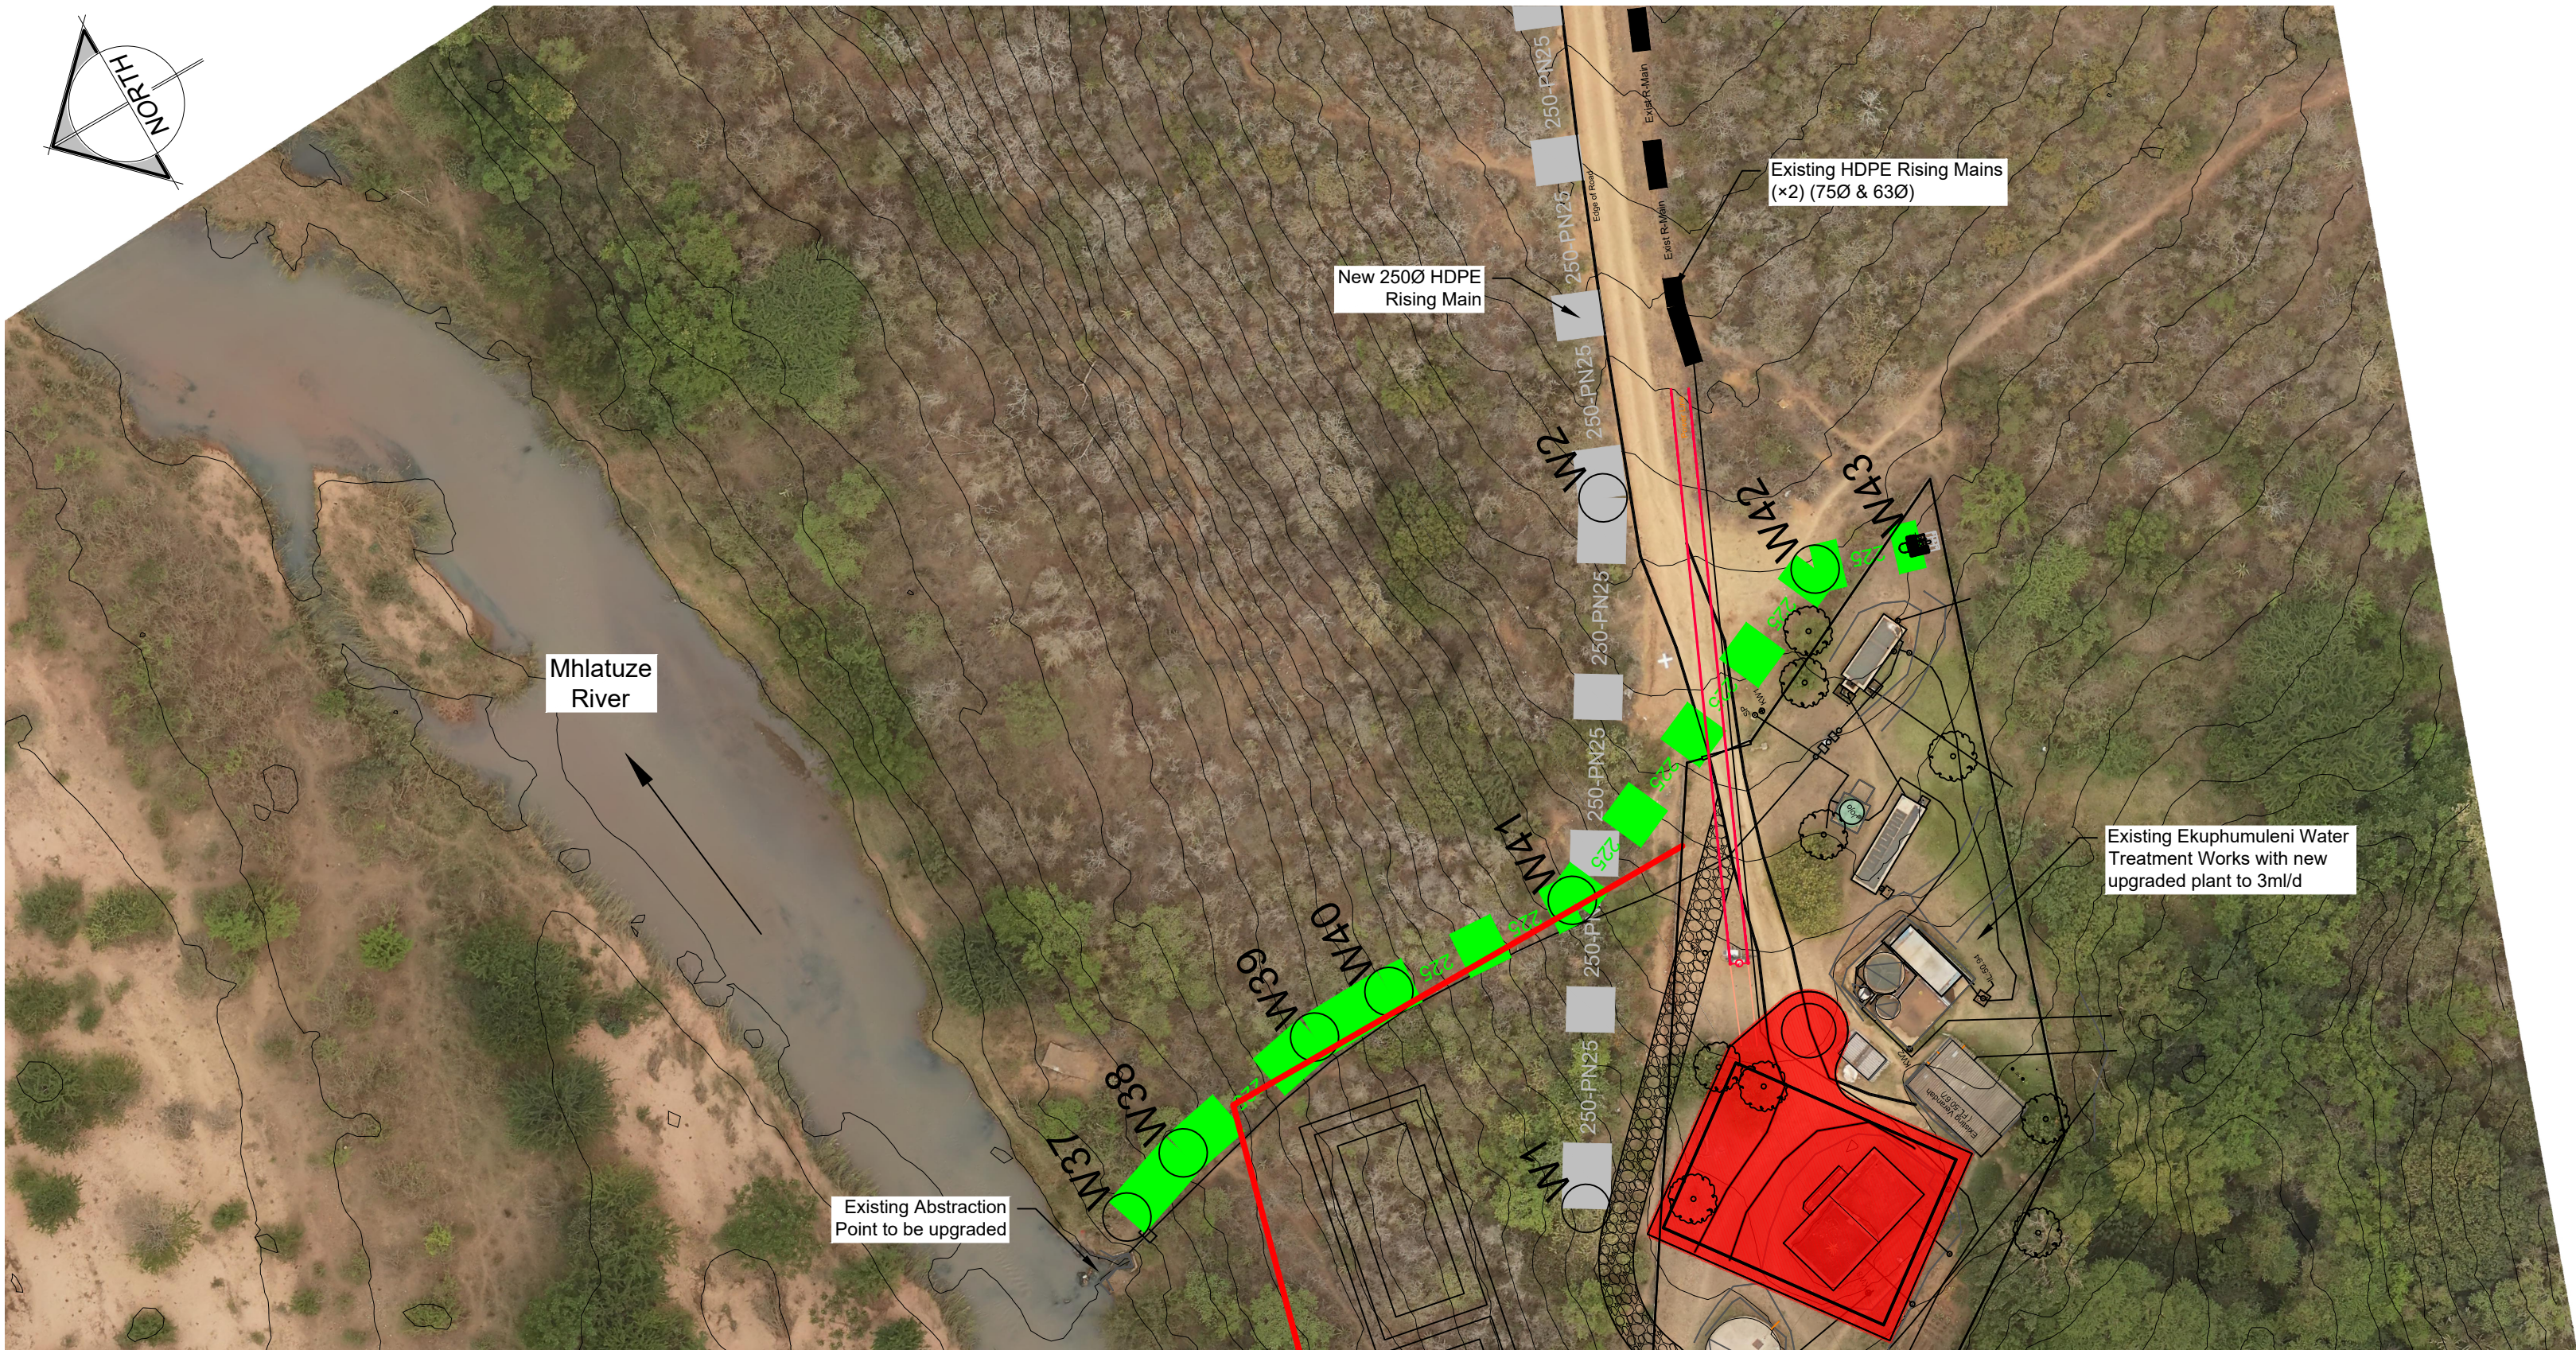

PLAN
Scale 1:500

----- NGL
----- PIPELINE

SCALES:
Horizontal 1:1000
Vertical 1:1000
Datum : 33 m

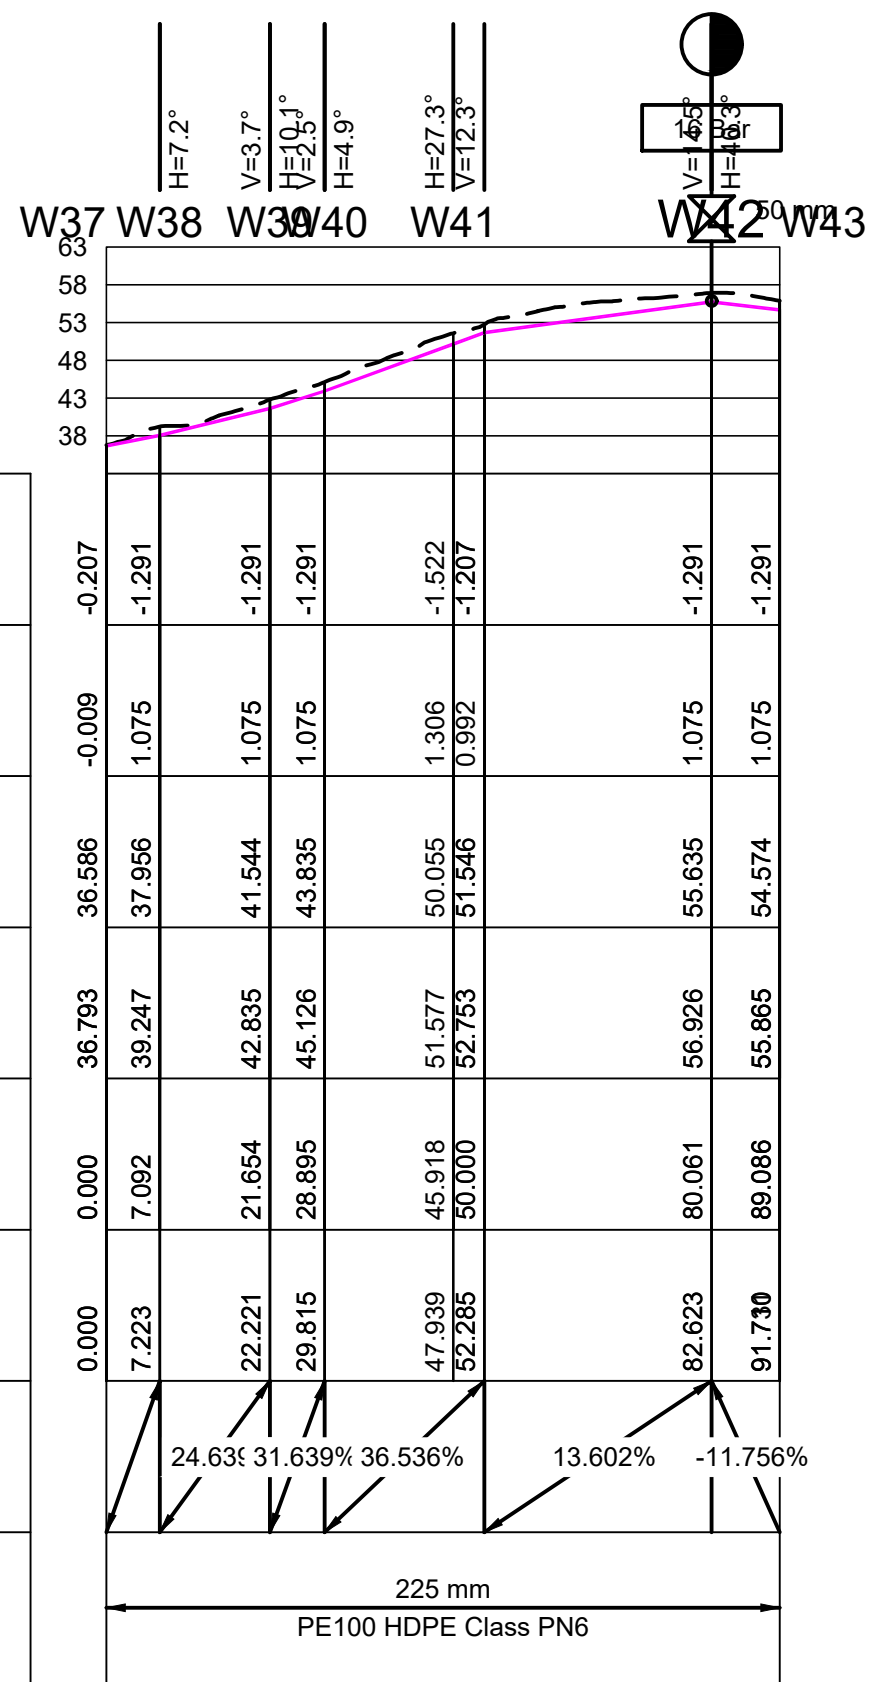

LONG SECTION
Scale 1:1000

Do not scale off drawing - ASK THE ENGINEER IF UNCERTAIN!
Any discrepancies between any drawings must be clarified before work is continued on site.

FOR TENDER
PURPOSES ONLY

READ THIS DRAWING IN CONJUNCTION WITH

Drawing Number	Drawing Description

AMENDMENTS

Rev.	Date	Description

ECA CONSULTING

Civil and Structural Engineers

VRVYHEID OFFICE:
161 High Street |
Vryheid | Kwa Zulu Natal |
RSA
vryheid@ecaconsult.co.za
Tel: +27 (0)34 983 2825
www.ecaconsult.co.za
OTHER OFFICES:
MBOMBELA | GAUTENG |
PIETERMARITZBURG |
LADYSMITH

Approved by Engineer: Signature: _____
Name: J.W. Janse v Rensburg
Designation: PrTechEng
ECSA Reg.: 201070143 Date: 28 Oct 2022

Project Funder/ Client:



Project Implementing Agent:

KING CETSHWAYO DISTRICT MUNICIPALITY

Approved by Client: _____
Name: _____
Signature: _____ Date: _____


Project:

**KWAHLOKOHLOKO SSA5:
PHASE 4 BULK
AUGMENTATION**


Drawing description:

**RAW WATER RISING MAIN
PLAN & LONG SECTION
SHEET 01**


Drawn: G.D Bezuidenhout Date: Jul 2022
Scale/s: As Shown
Drawing number: 22-032-V-PH4-01-06 Rev.: 00

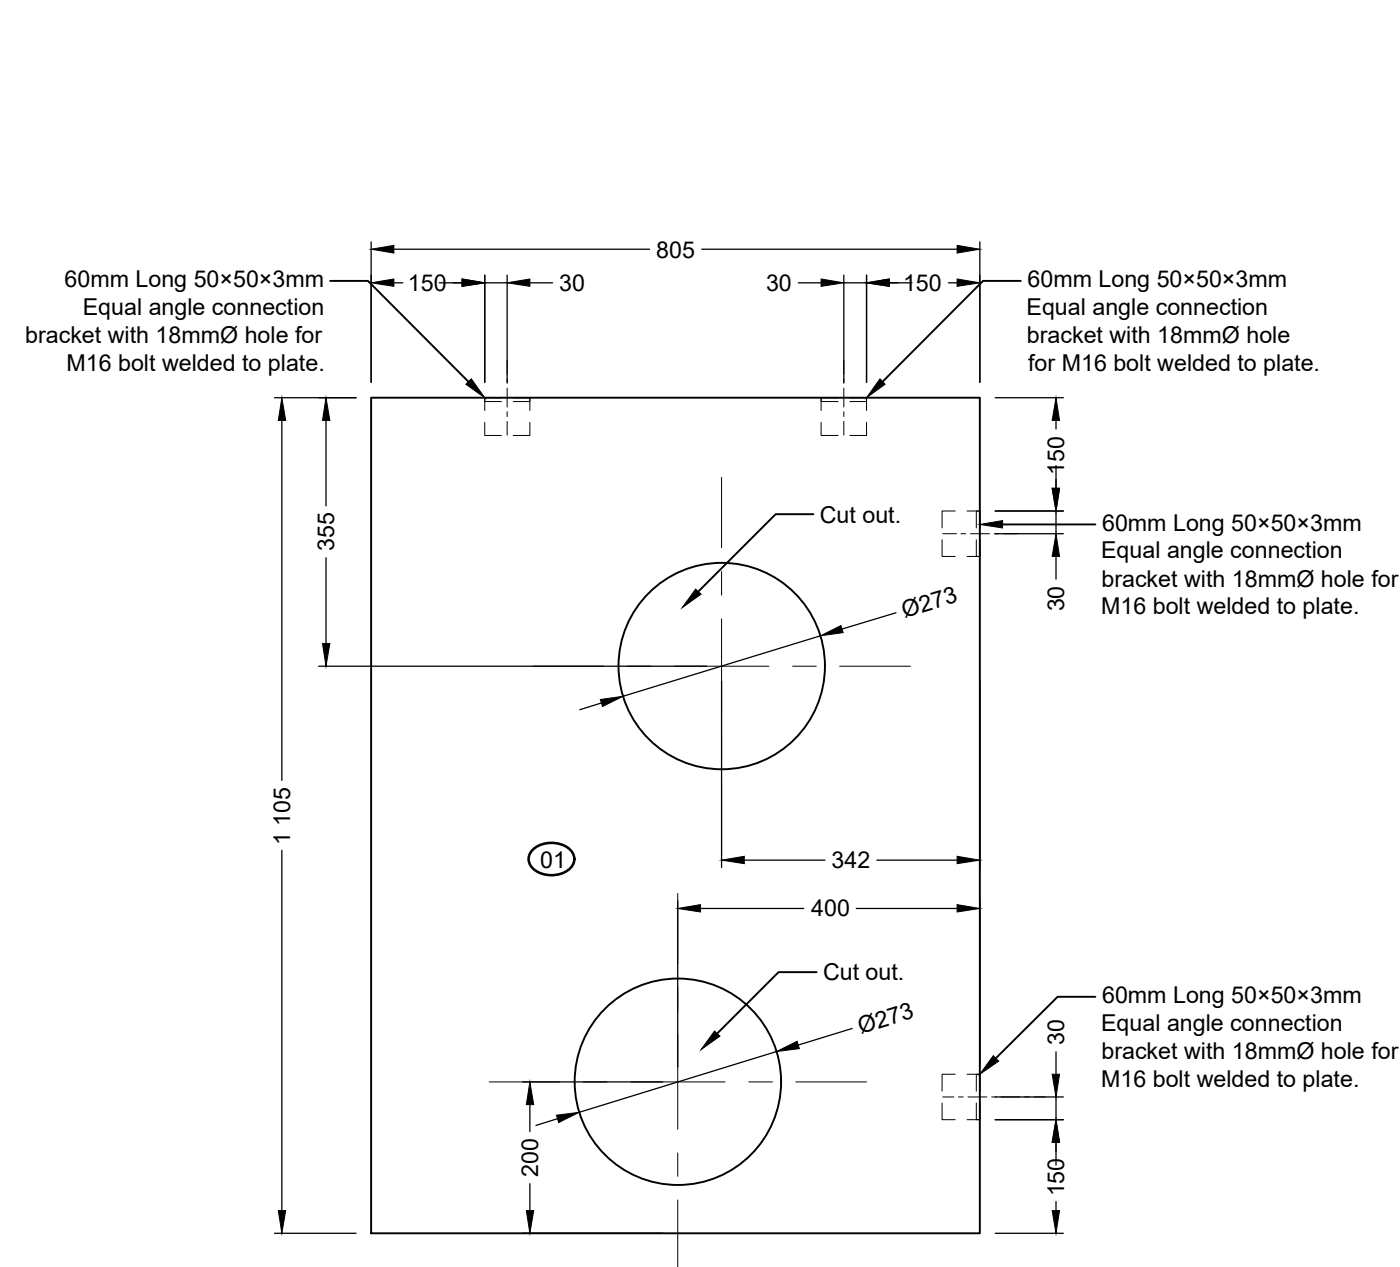


SPLITTER BOX BASE PLATE
Scale 1 : 10

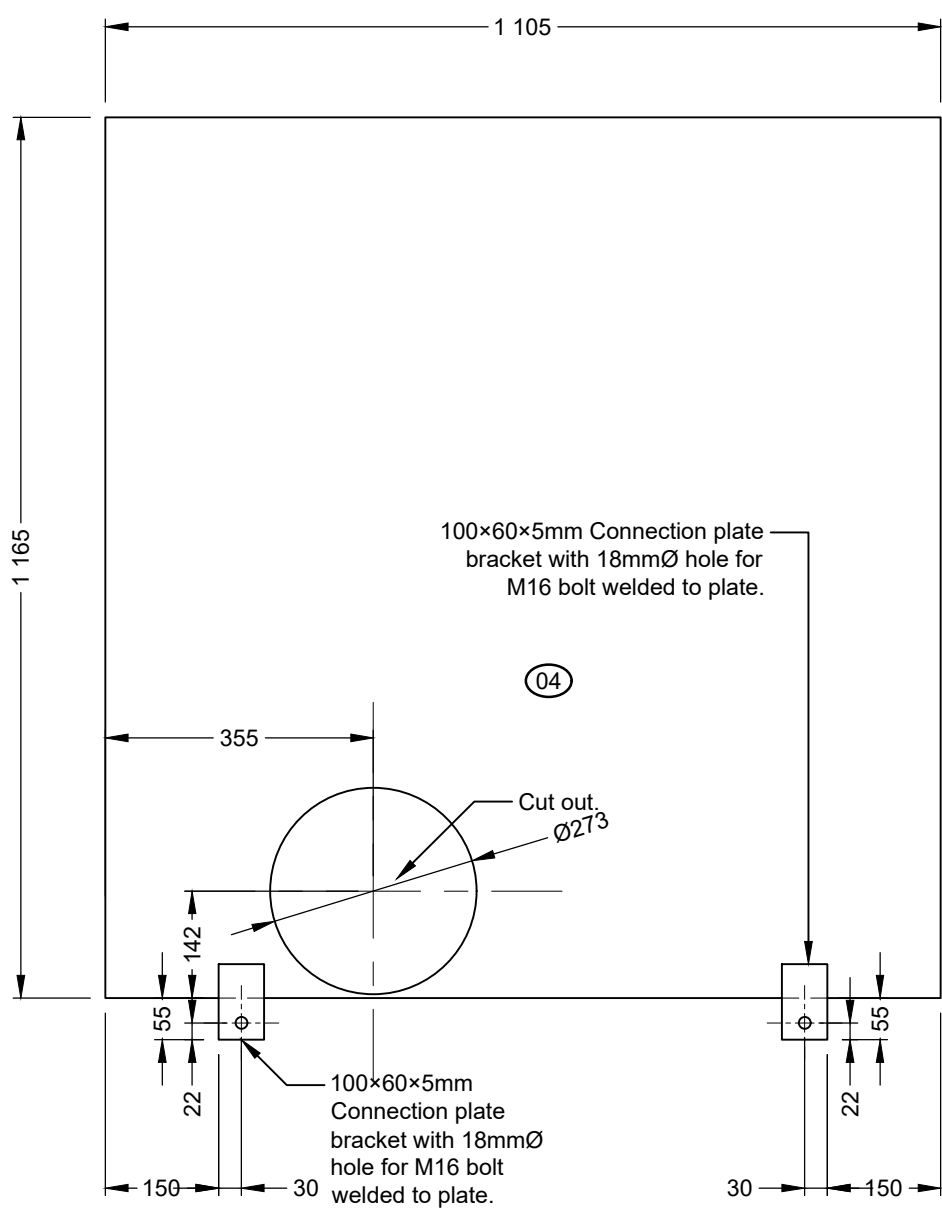


FRONT PLATE
Scale 1 : 10

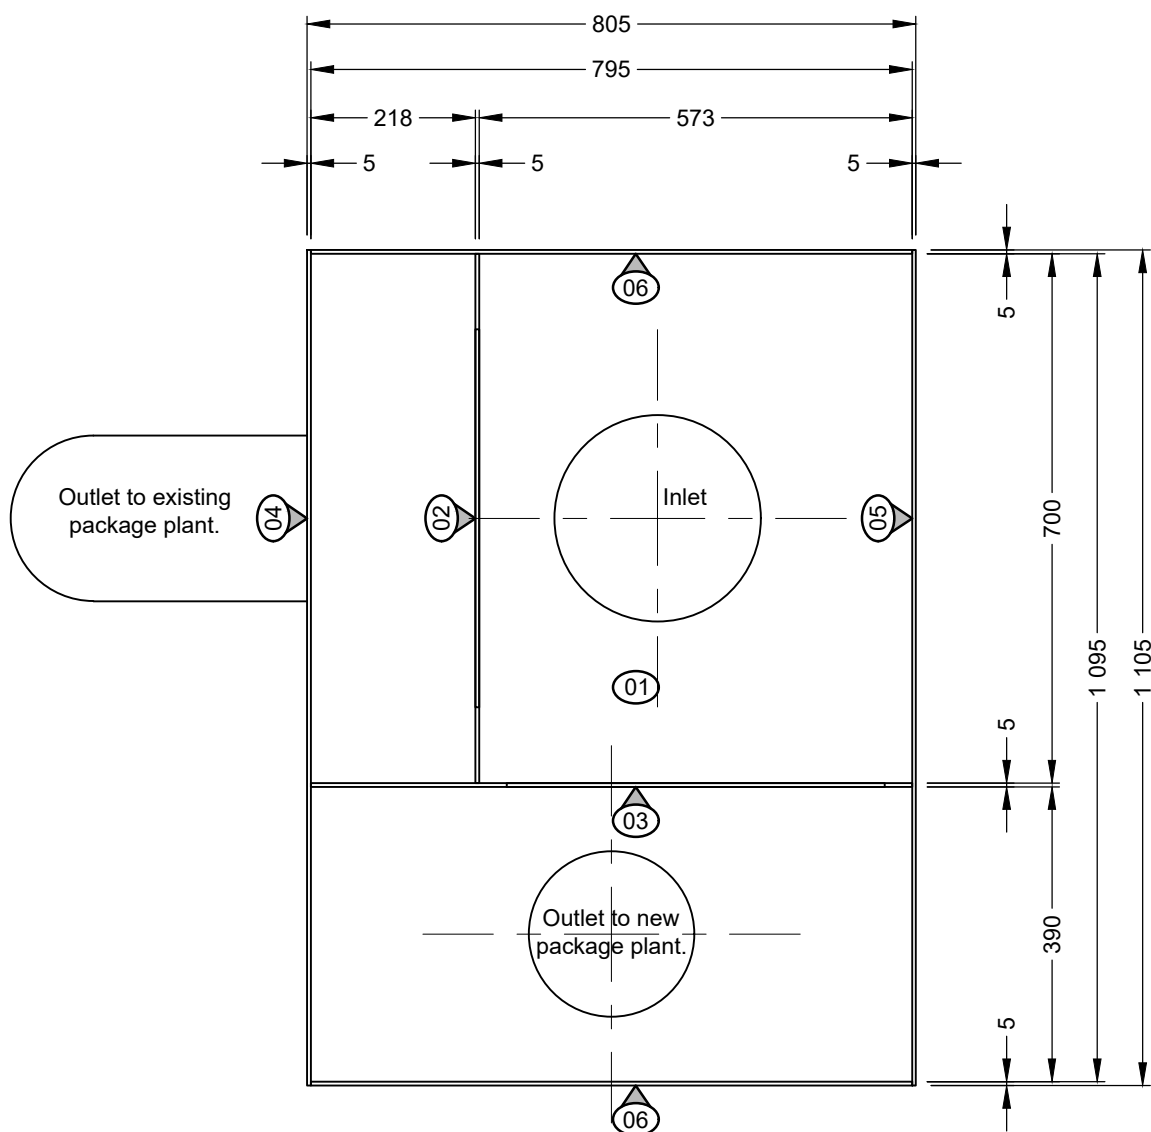


SPLITTER BOX PLAN
Scale 1 : 10

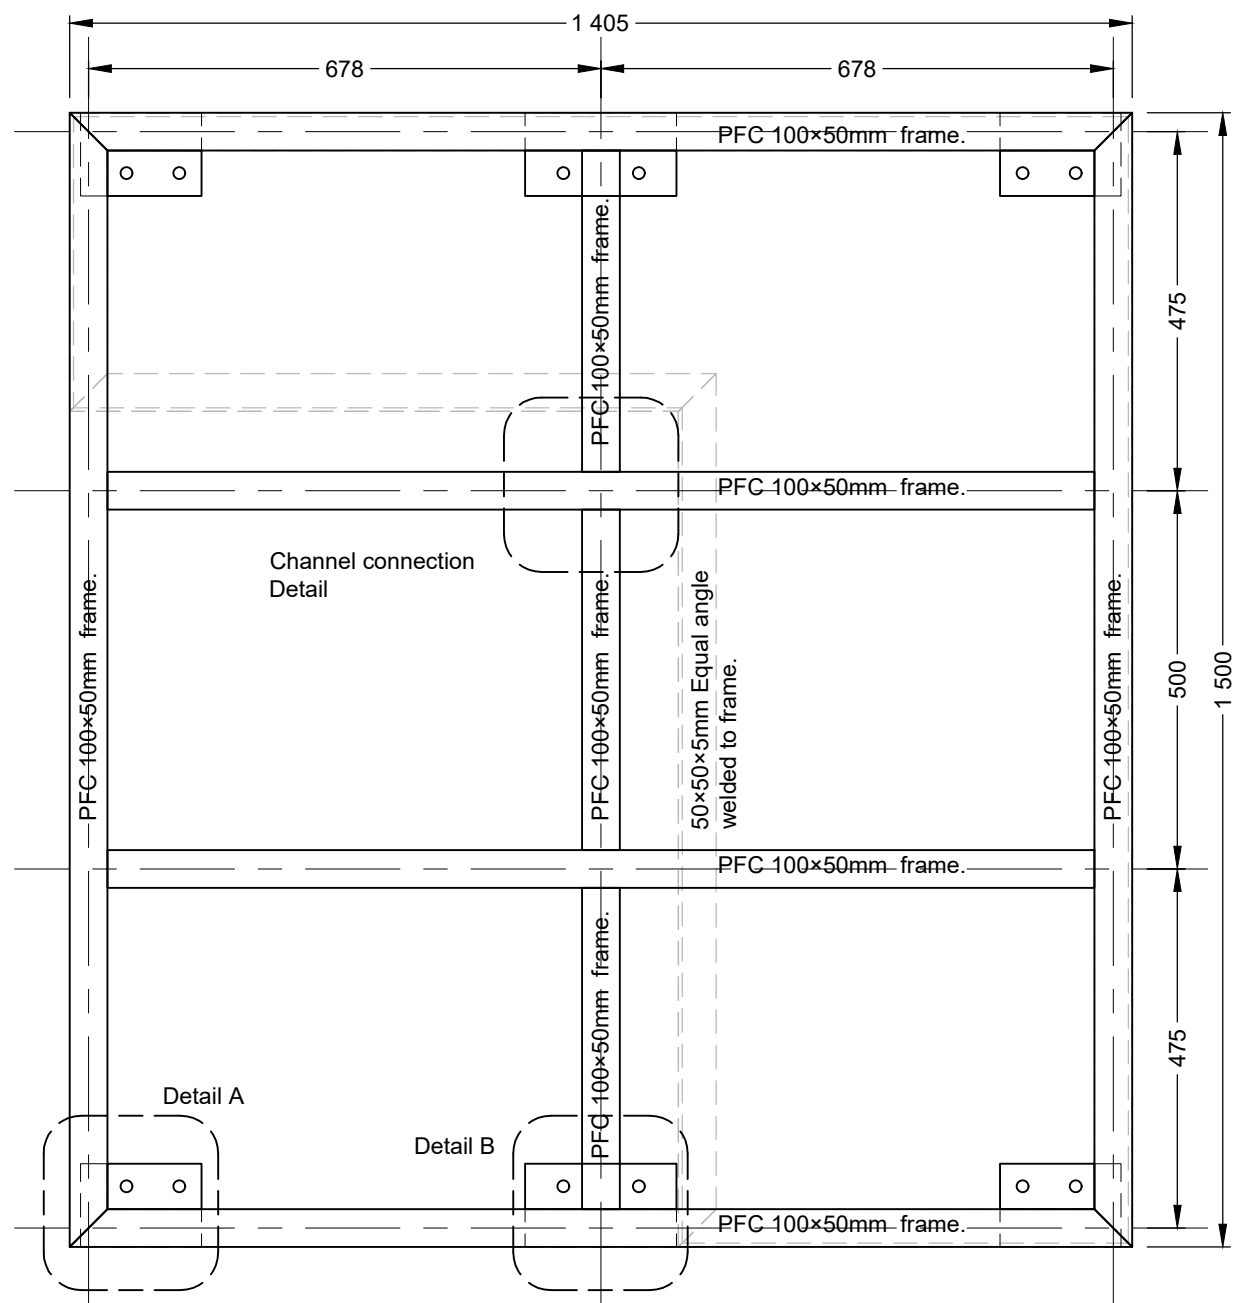


SPLITTER BOX & WALKWAY
FRAME DETAIL PLAN
Scale 1 : 10

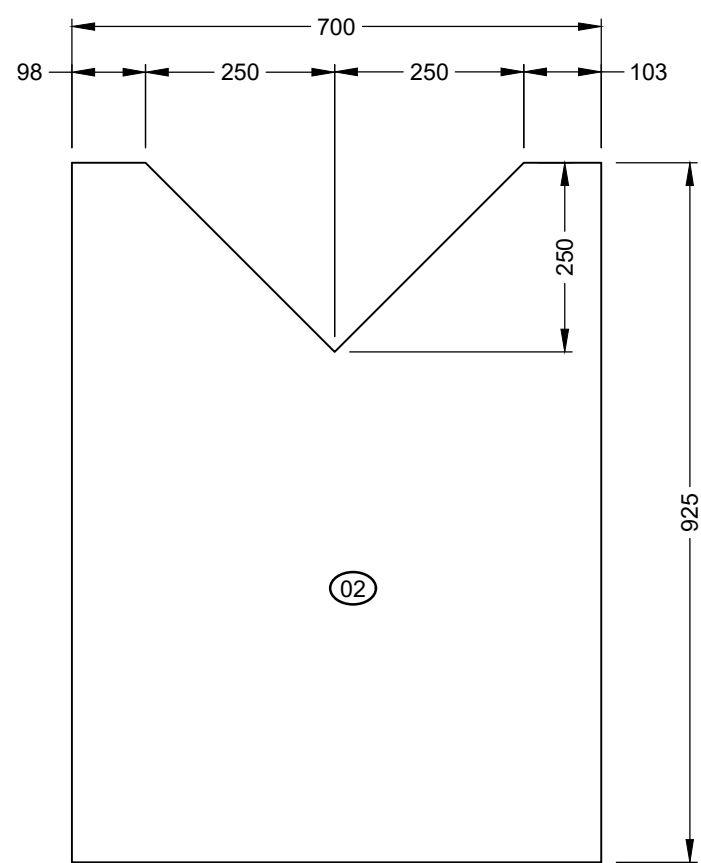


WATER OVERFLOW PLATE
Scale 1 : 10

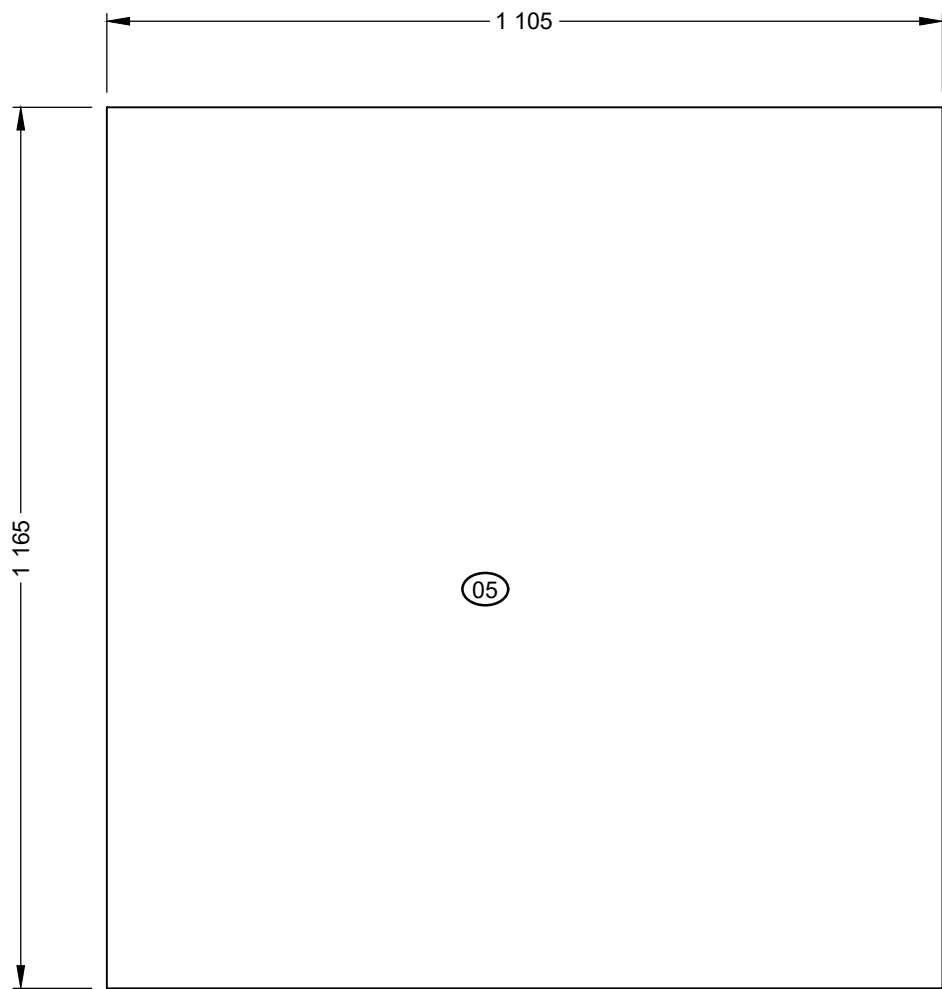


BACK PLATE
Scale 1 : 10

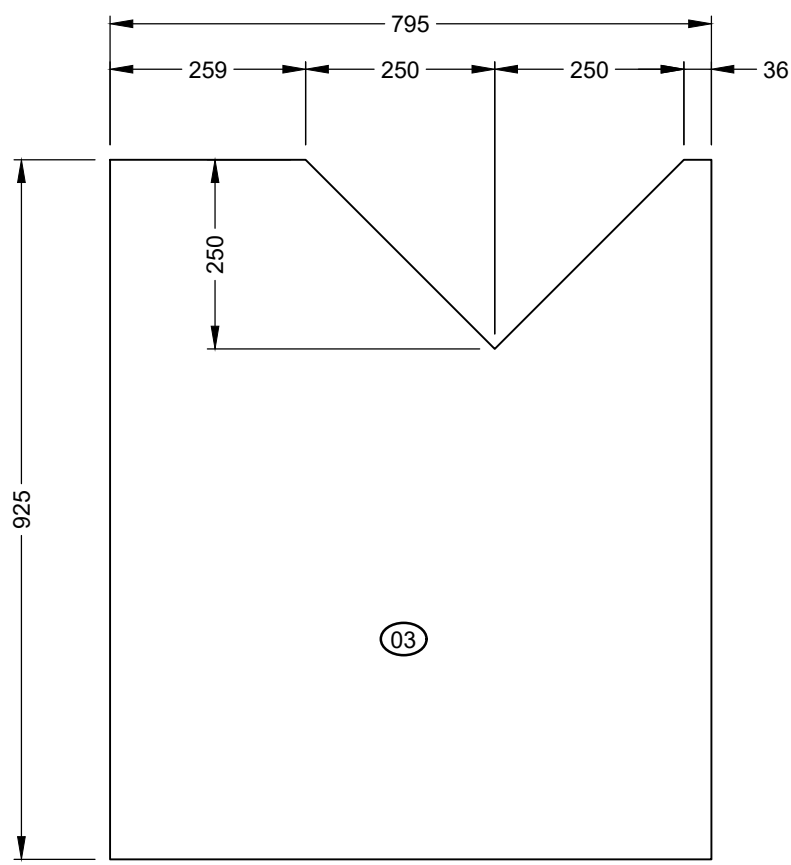

WATER OVERFLOW PLATE
Scale 1 : 10

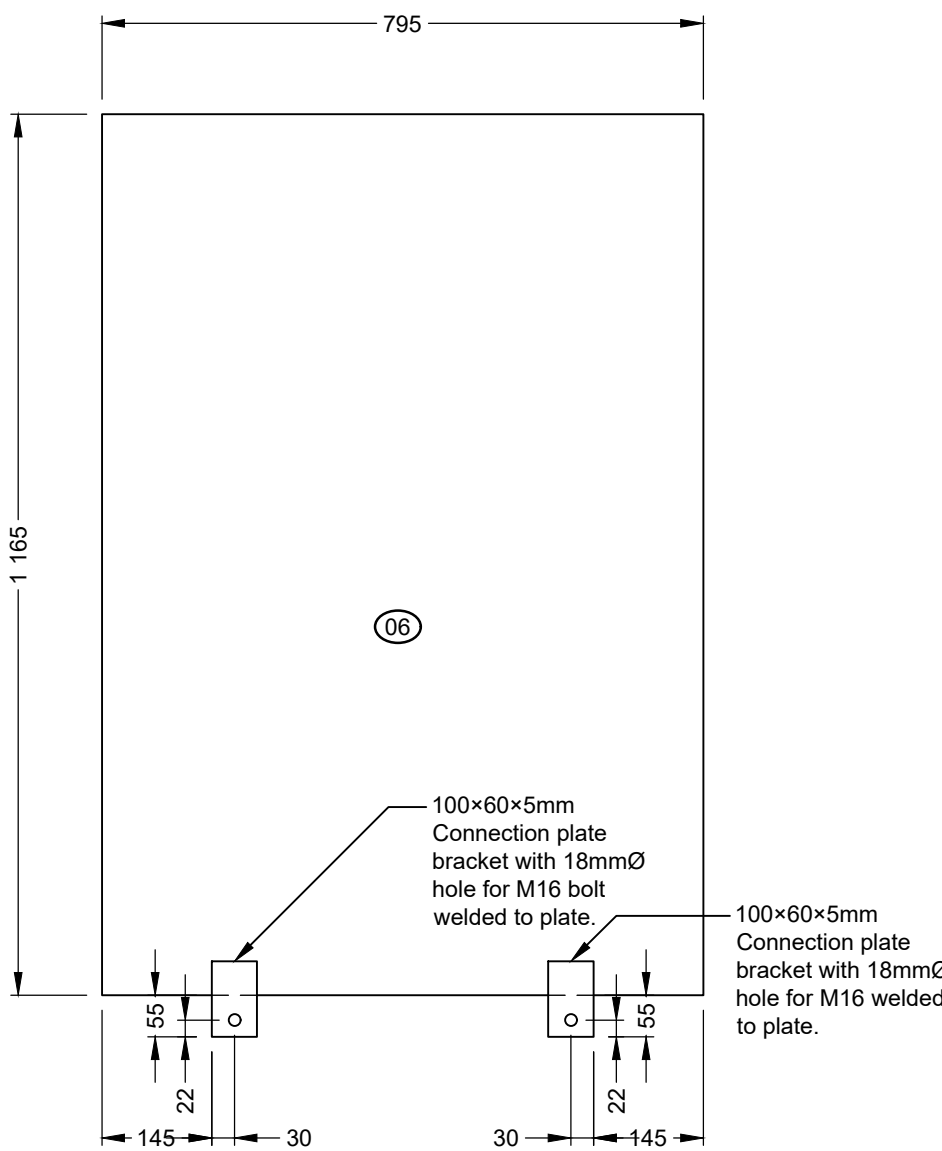


SIDE PLATE (×2)
Scale 1 : 10

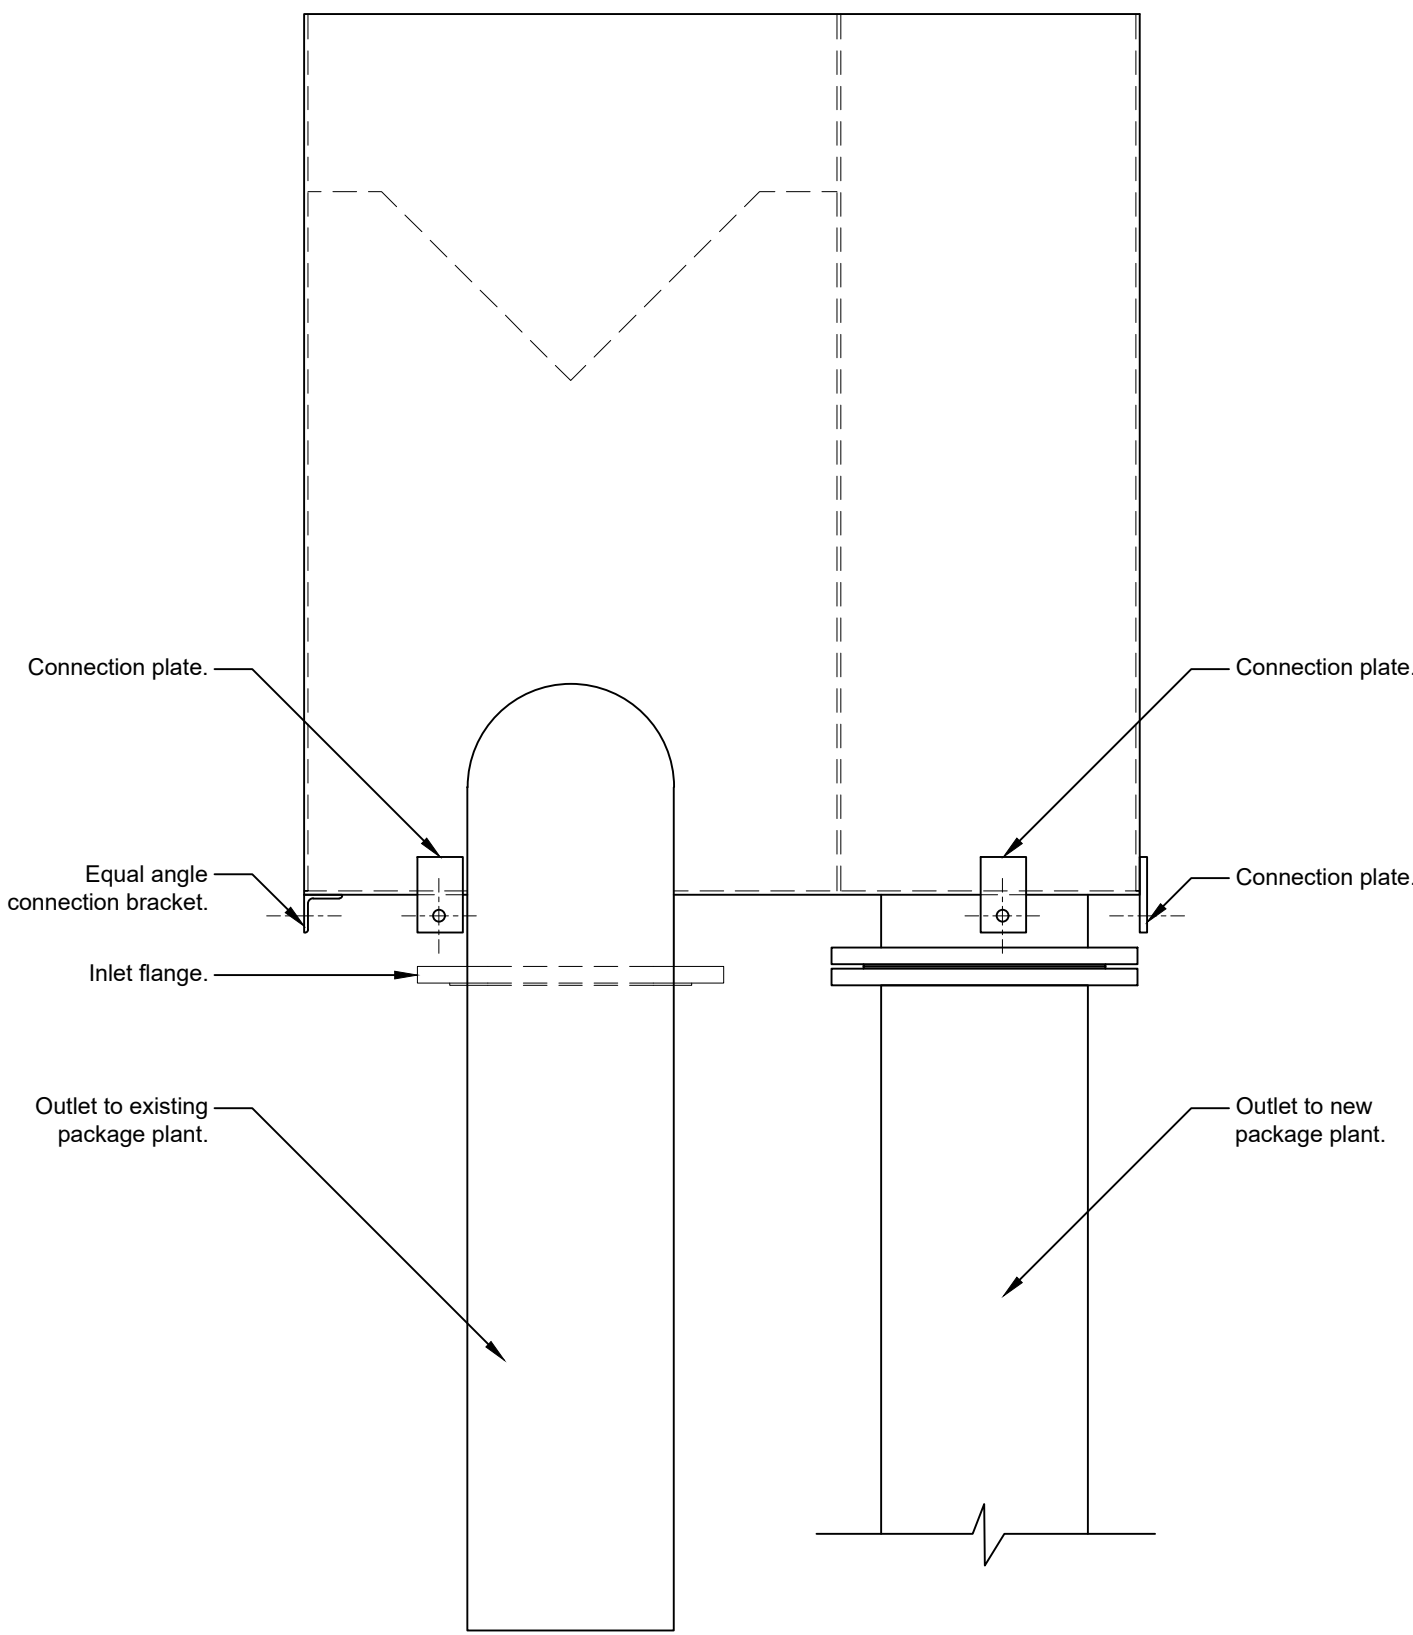

SPLITTER BOX FRONT ELEVATION
Scale 1 : 10

NOTE:
1 - All plates to be 5mm Thick
2 - Splitter box steelwork must be
thoroughly cleaned and hot dipped
galvanised as per specification to
SABS 763.

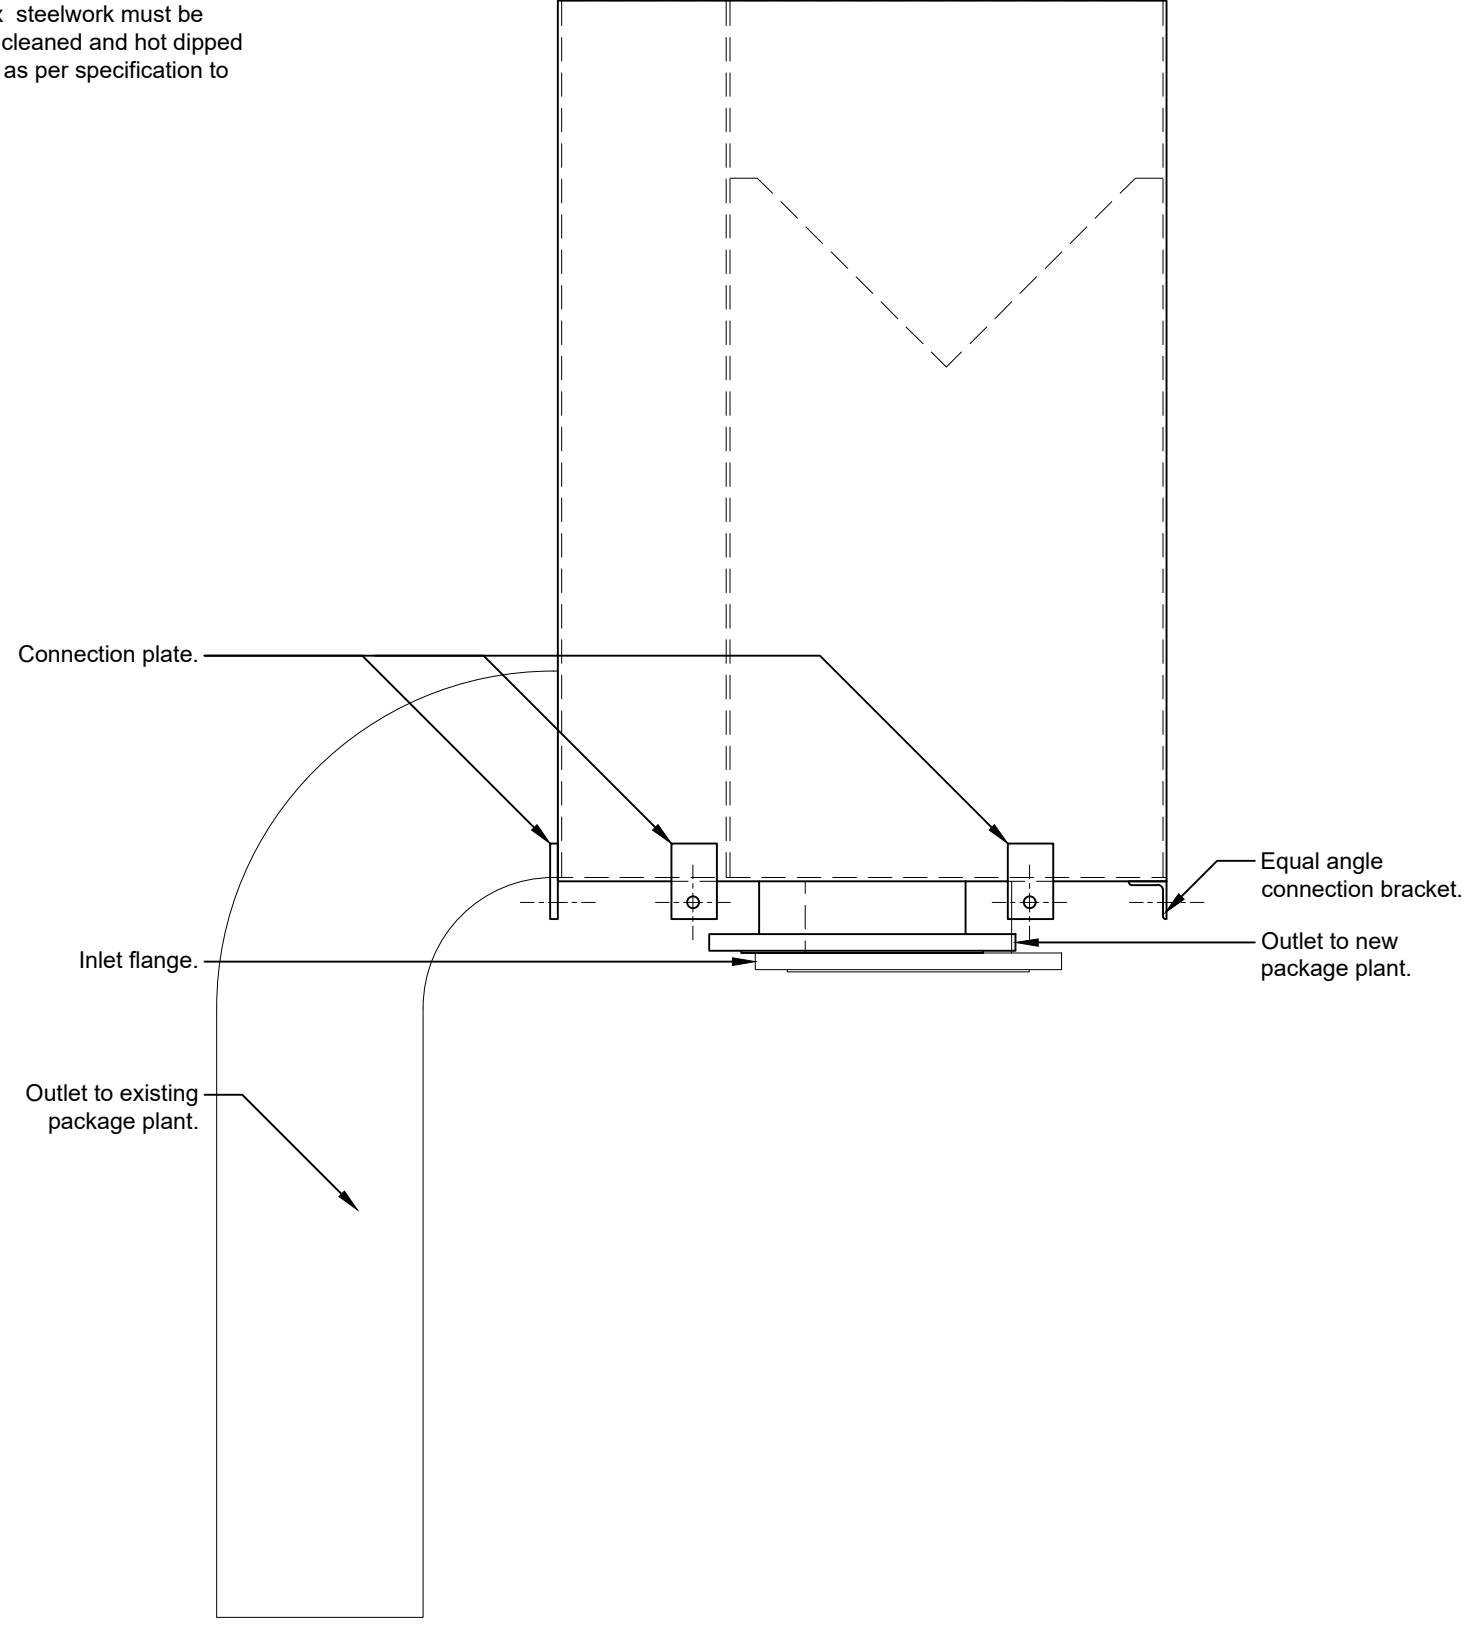

SPLITTER BOX SIDE ELEVATION
Scale 1 : 10

Do not scale off drawing - ASK THE ENGINEER IF
UNCERTAIN!
Any discrepancies between any drawings must be
clarified before work is continued on site.

FOR TENDER
PURPOSES ONLY

READ THIS DRAWING IN CONJUNCTION WITH

Drawing Number	Drawing Description

AMENDMENTS

Rev.	Date	Description

ECA CONSULTING
VRVHEID
OFFICE:
161 High Street |
Vryheid | Kwa Zulu Natal |
RSA
vryheid@ecaconsult.co.za
Tel: +27 (0)34 963 2625
www.ecaconsult.co.za
OTHER OFFICES:
MBOMBELA | GAUTENG |
PIETERMARITZBURG |
LADYSMITH

Approved by Engineer:
Name: J.W. Janse v Rensburg
Designation: PrTechEng
ECOSA Reg.: 201070143
Signature: _____
Date: 27 Oct 2022

Project Funder/ Client:
mig
Municipal
Infrastructure
Grant

Project Implementing Agent:
**KING
CETSHWAYO
DISTRICT
MUNICIPALITY**

 
 
 
 
 
 
 
 
 
DISTRICT MUNICIPALITY


Approved by Client:
Name: _____
Signature: _____ Date: _____

Project:
**KWAHLOKOHLKO SSA5:
PHASE 4 BULK
AUGMENTATION**


Drawing description:
**SPLITTER BOX
DETAILS**

Drawn: G.D Bezuidenhout Date: Jul 2022
Scale/s: As Shown
Drawing number: 22-032-V-PH4-02-01 Rev.: 00

[illegible]

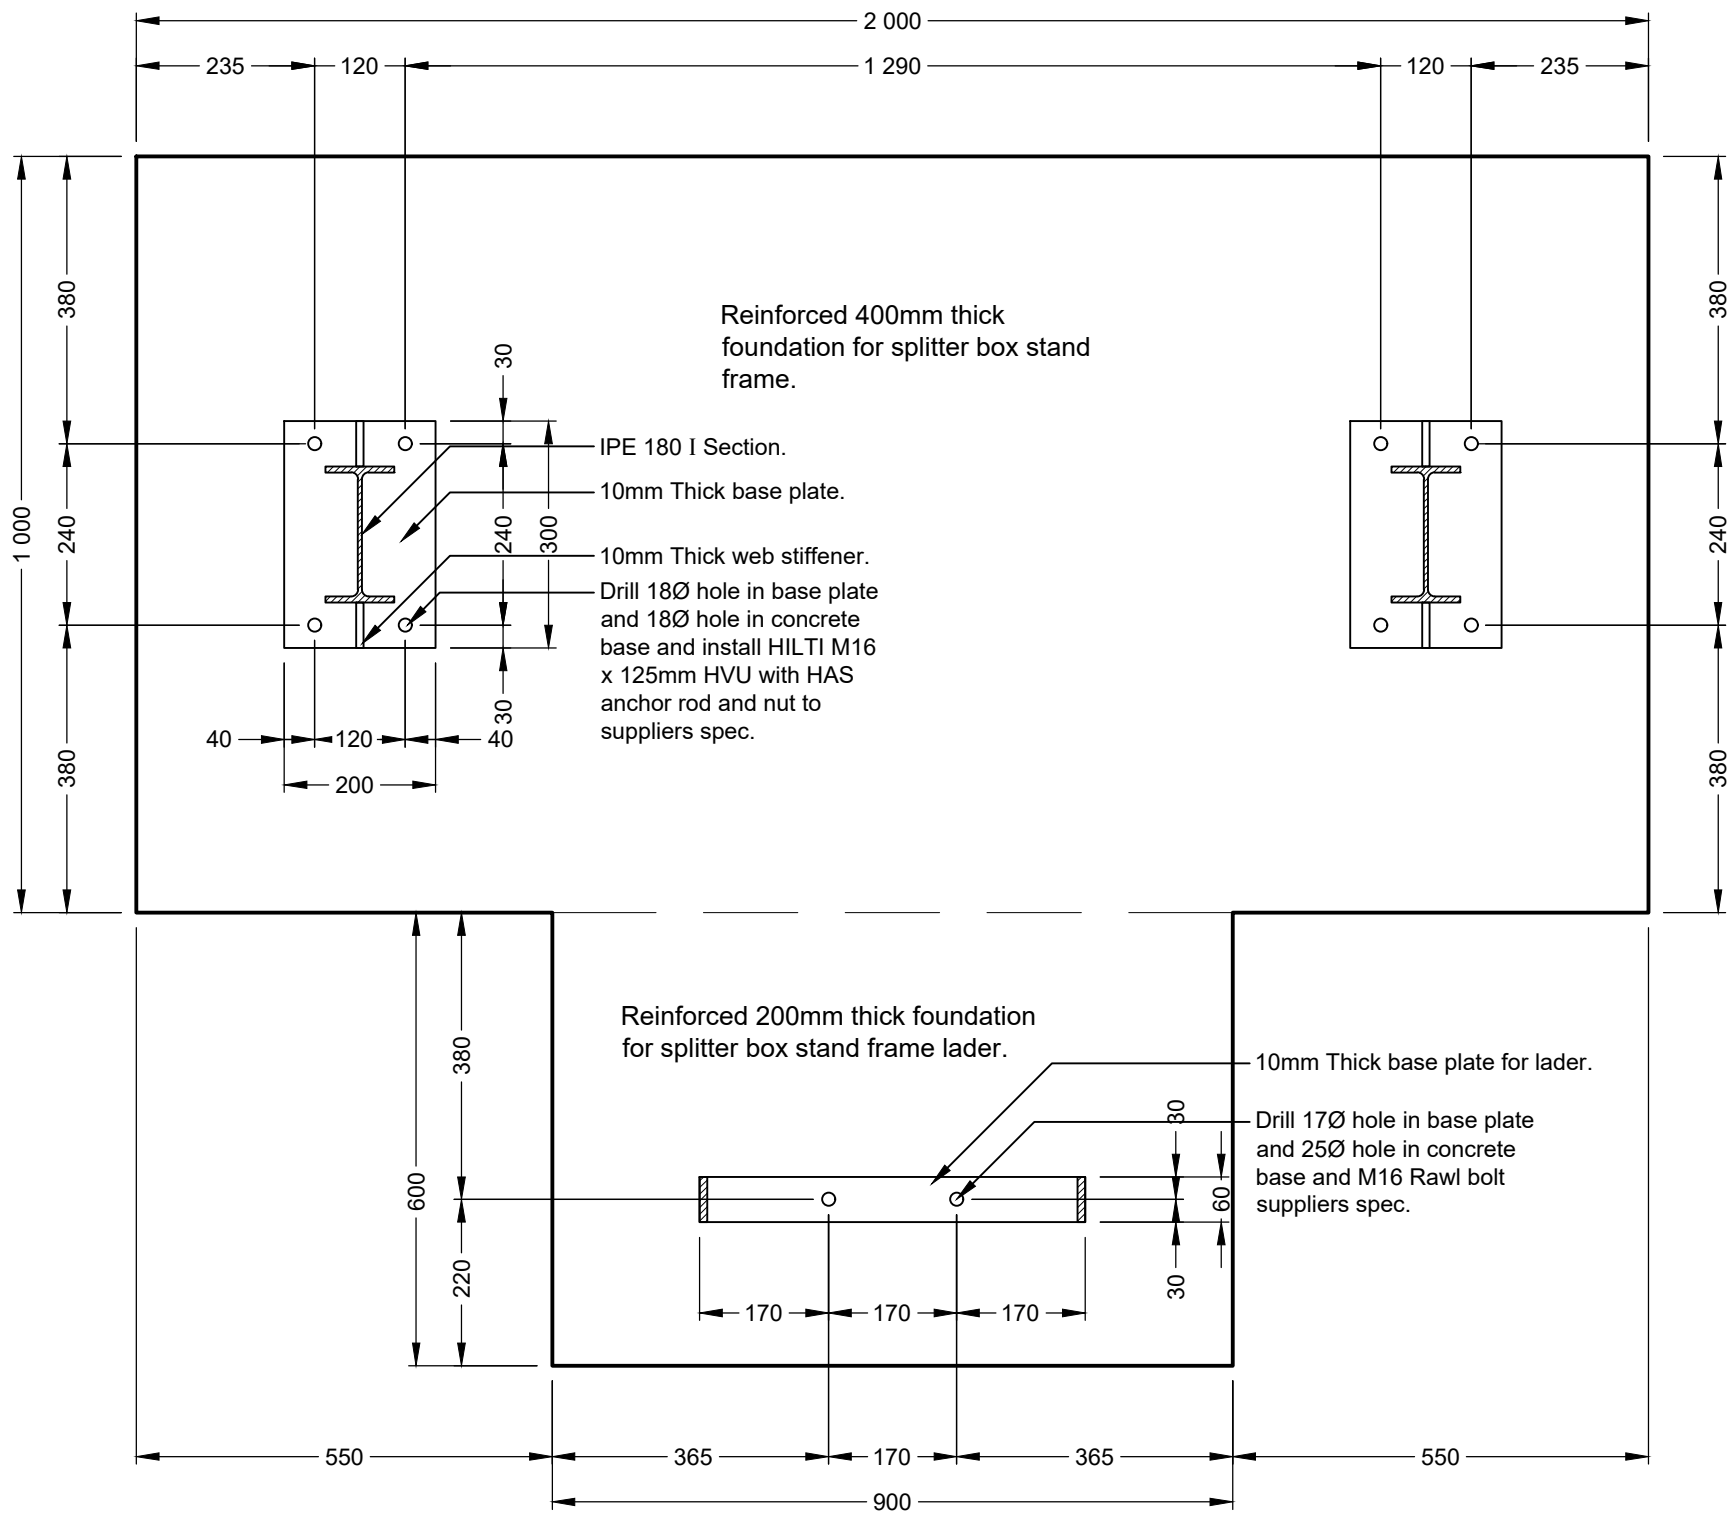

SPLITTER BOX FRAME
BASE FOUNDATION PLAN
Scale 1 : 10

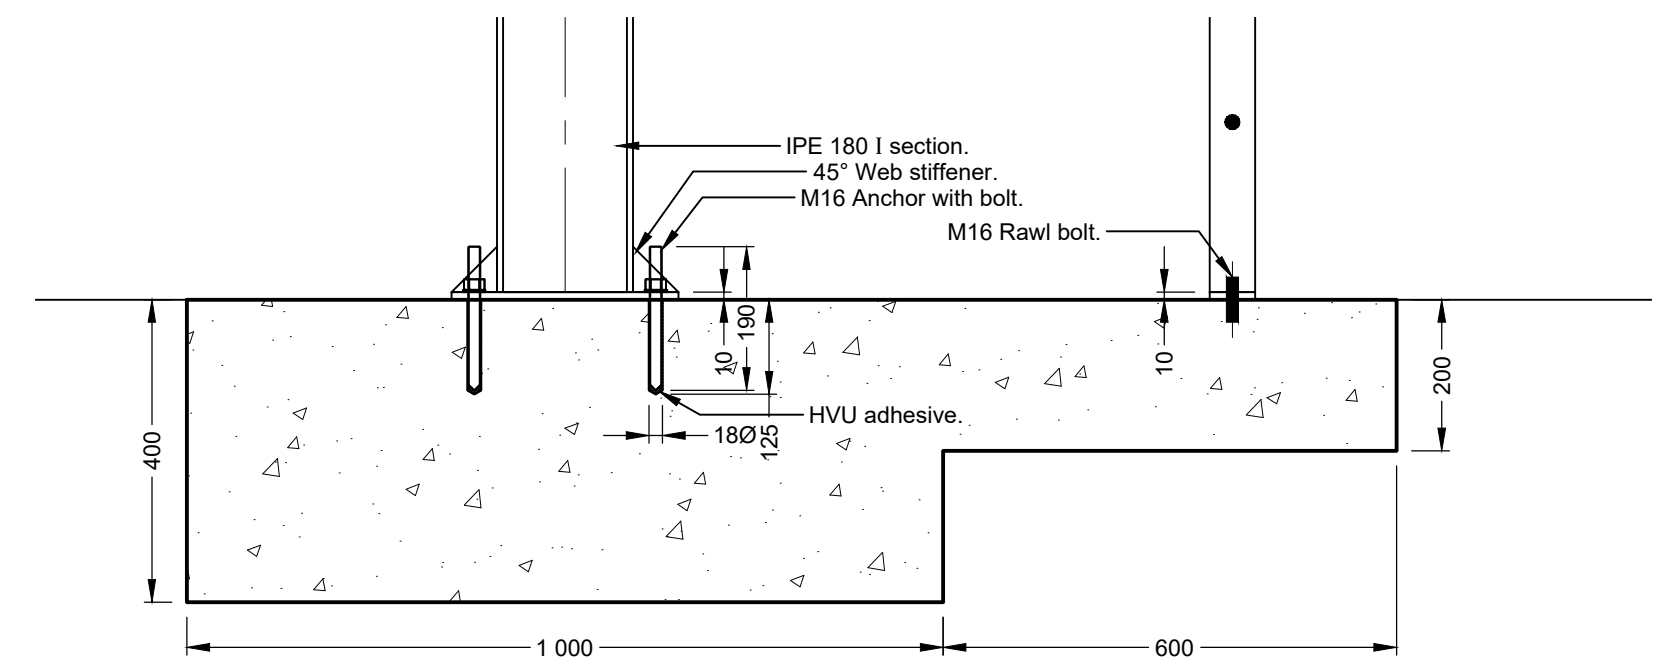

SPLITTER BOX STAND
FOUNDATION SECTION
Scale 1 : 10

Do not scale off drawing - ASK THE ENGINEER IF UNCERTAIN!
Any discrepancies between any drawings must be clarified before work is continued on site.

FOR TENDER
PURPOSES ONLY

READ THIS DRAWING IN CONJUNCTION WITH

Drawing Number	Drawing Description

AMENDMENTS

Rev.	Date	Description

ECA CONSULTING

Civil and Structural Engineers

VRYHEID
OFFICE:
161 High Street |
Vryheid | Kwa Zulu Natal |
RSA
vryheid@ecacconsult.co.za
Tel: +27 (0)34 963 2625
www.ecacconsult.co.za
OTHER OFFICES:
MBOMBELA | GAUTENG |
PIETERMARITZBURG |
LADYSMITH

Approved by Engineer: _____ Signature: _____
Name: J.W. Janse v Rensburg
Designation: PrTechEng
ECSA Reg.: 201070143 Date: 27 Oct 2022

Project Funder/ Client:
mig
Municipal
Infrastructure
Grant



Project Implementing Agent:
**KING
CETSHWAYO
DISTRICT
MUNICIPALITY**



KING CETSHWAYO
DISTRICT MUNICIPALITY

Approved by Client:
Name: _____
Signature: _____ Date: _____

Project:
**KWAHLOKOHLOKO SSA5:
PHASE 4 BULK
AUGMENTATION**


Drawing description:
**SPLITTER BOX STAND
FOUNDATION DETAILS**

Drawn: G.D Bezuidenhout Date: Jul 2022
Scale/s: As Shown
Drawing number: 22-032-V-PH4-02-03 Rev.: 00

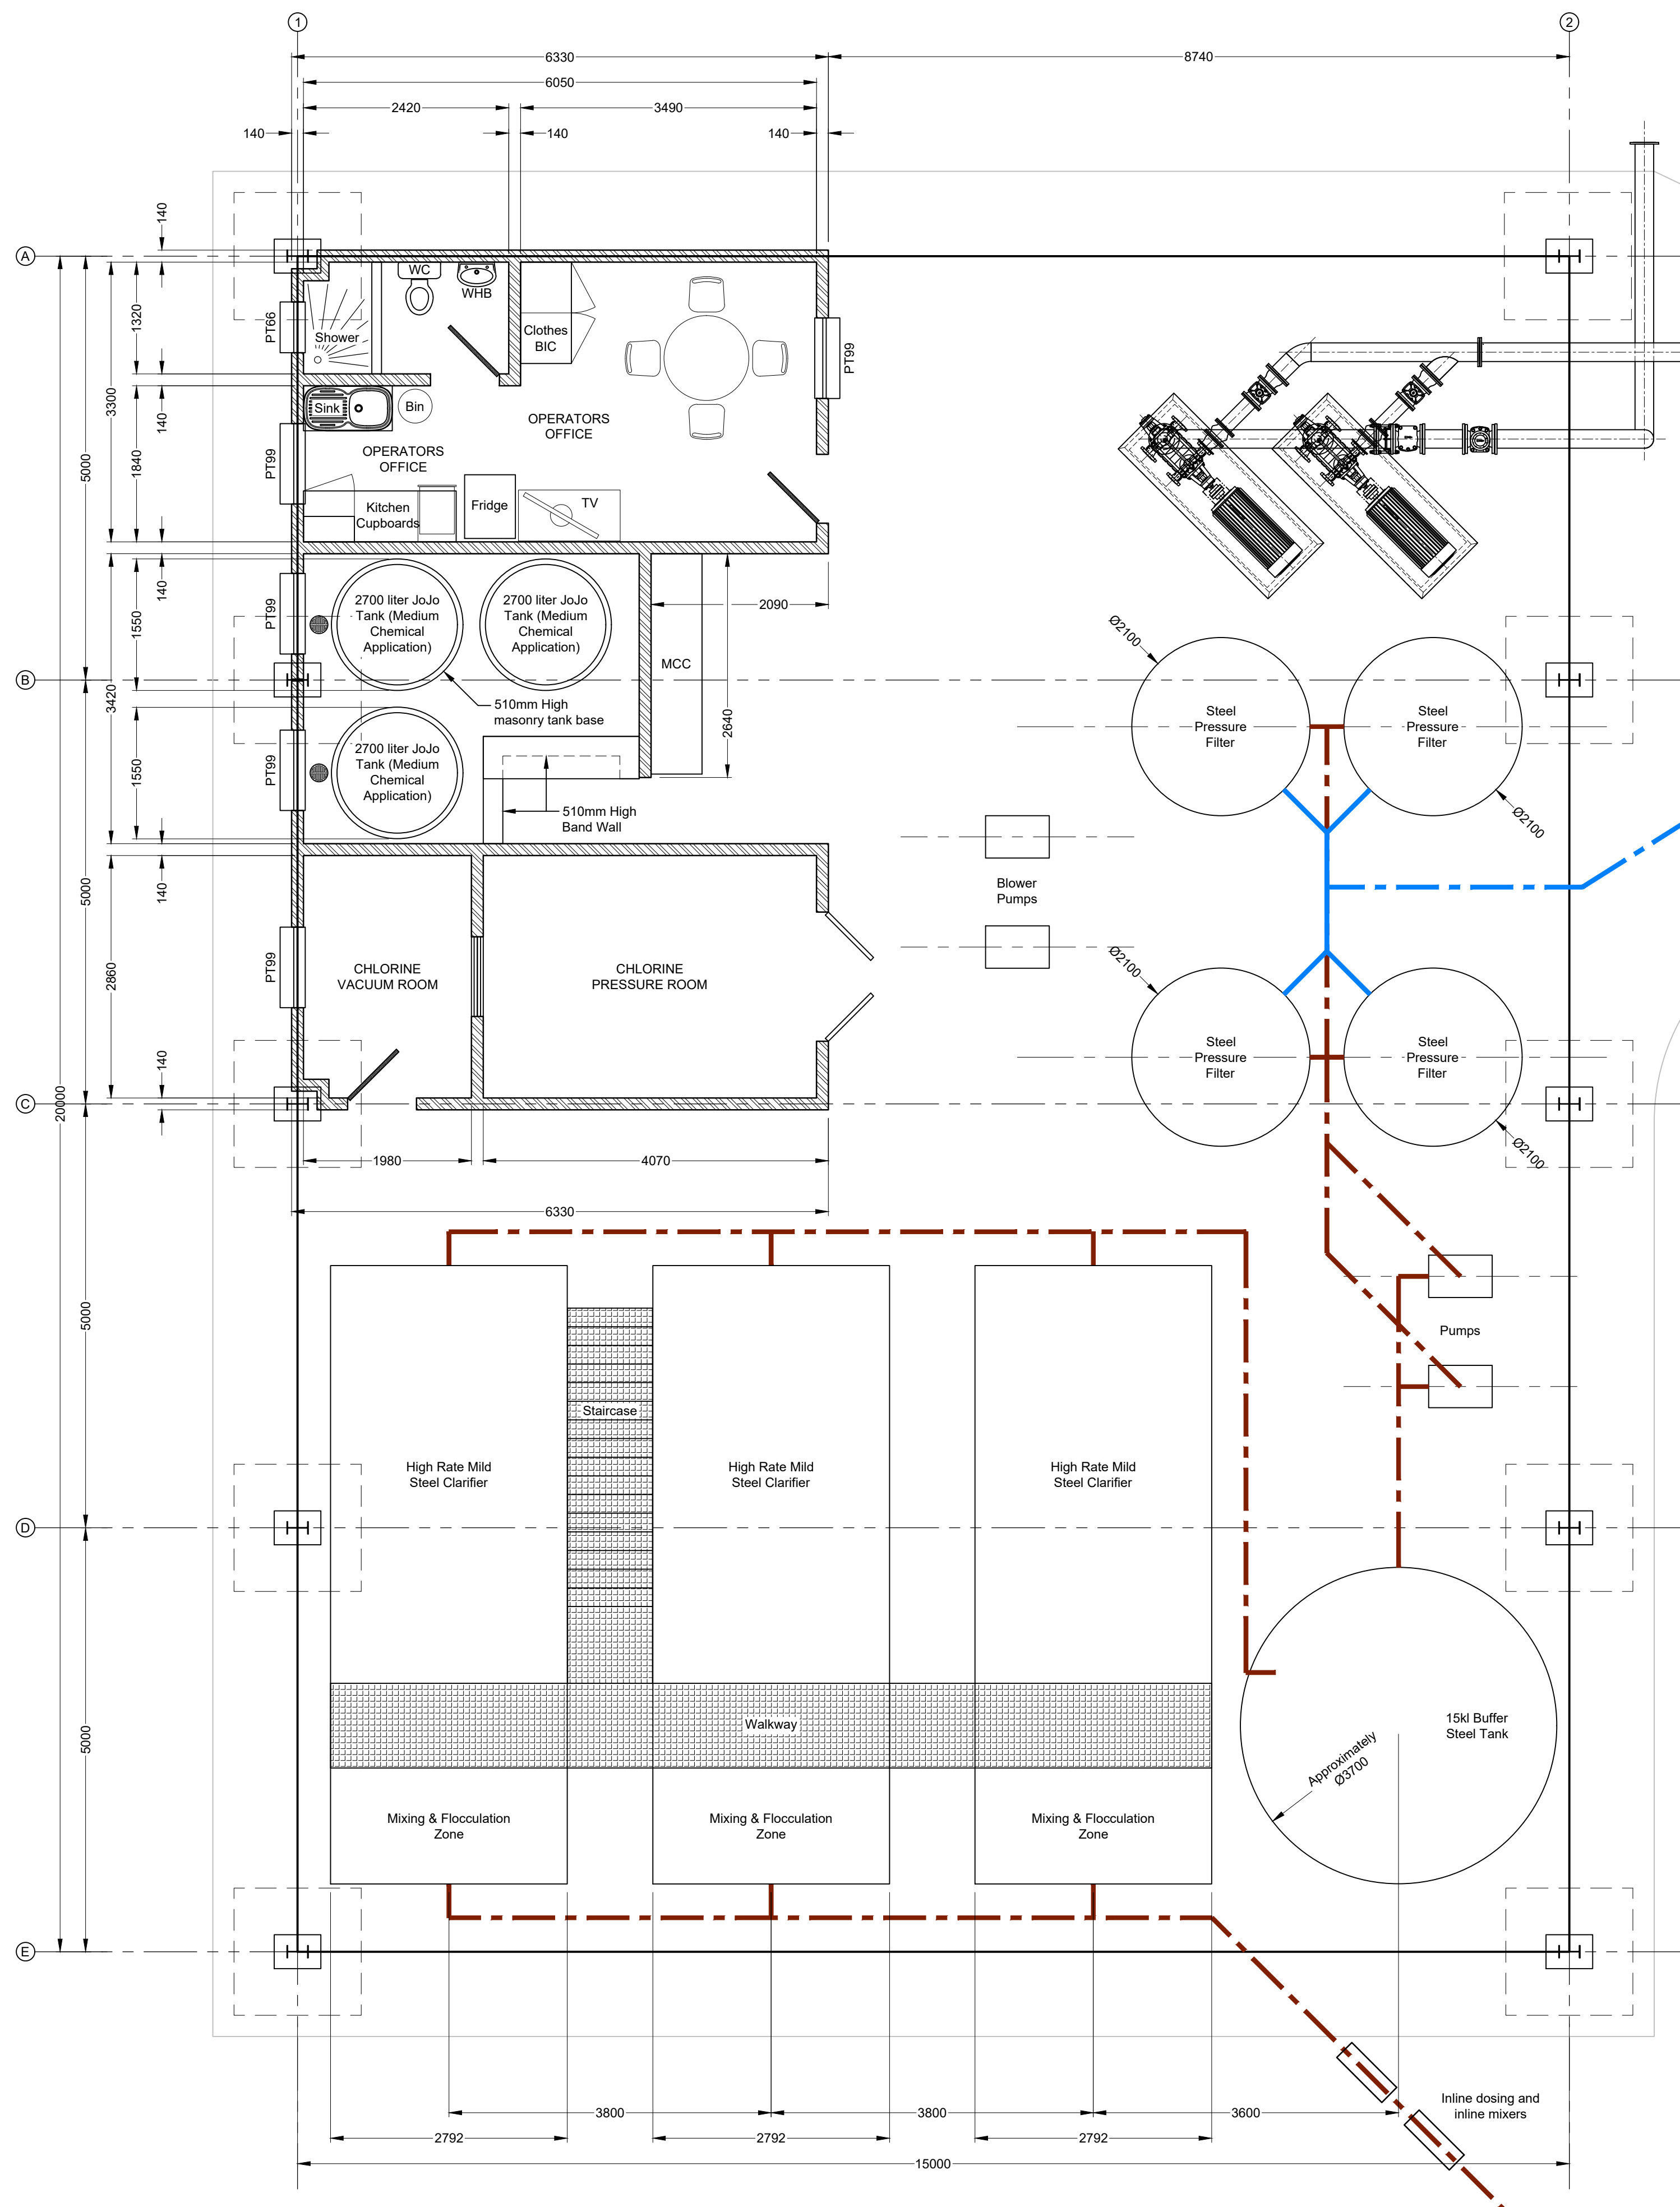

FLOOR PLAN
Scale 1 : 50

BENCHMARK DATA (WG 31) - TRIG No.92				
NAME	Y	X	Z	DESCRIPTION
KW1	-73875.80	3184504.06	55.68	12mm Iron Peg 0.6m from fence
KW2	-73845.31	3184500.65	51.36	12mm Iron Peg on corner of concrete slab
KW5	-74334.26	3185212.95	164.23	Centre of Manhole on Chamber
KW8	-73829.48	3184487.52	51.15	Black Cross on Blue PVC Pipe
1190	-74152.44	3185555.31	156.20	Stand Pipe in centre of concrete base

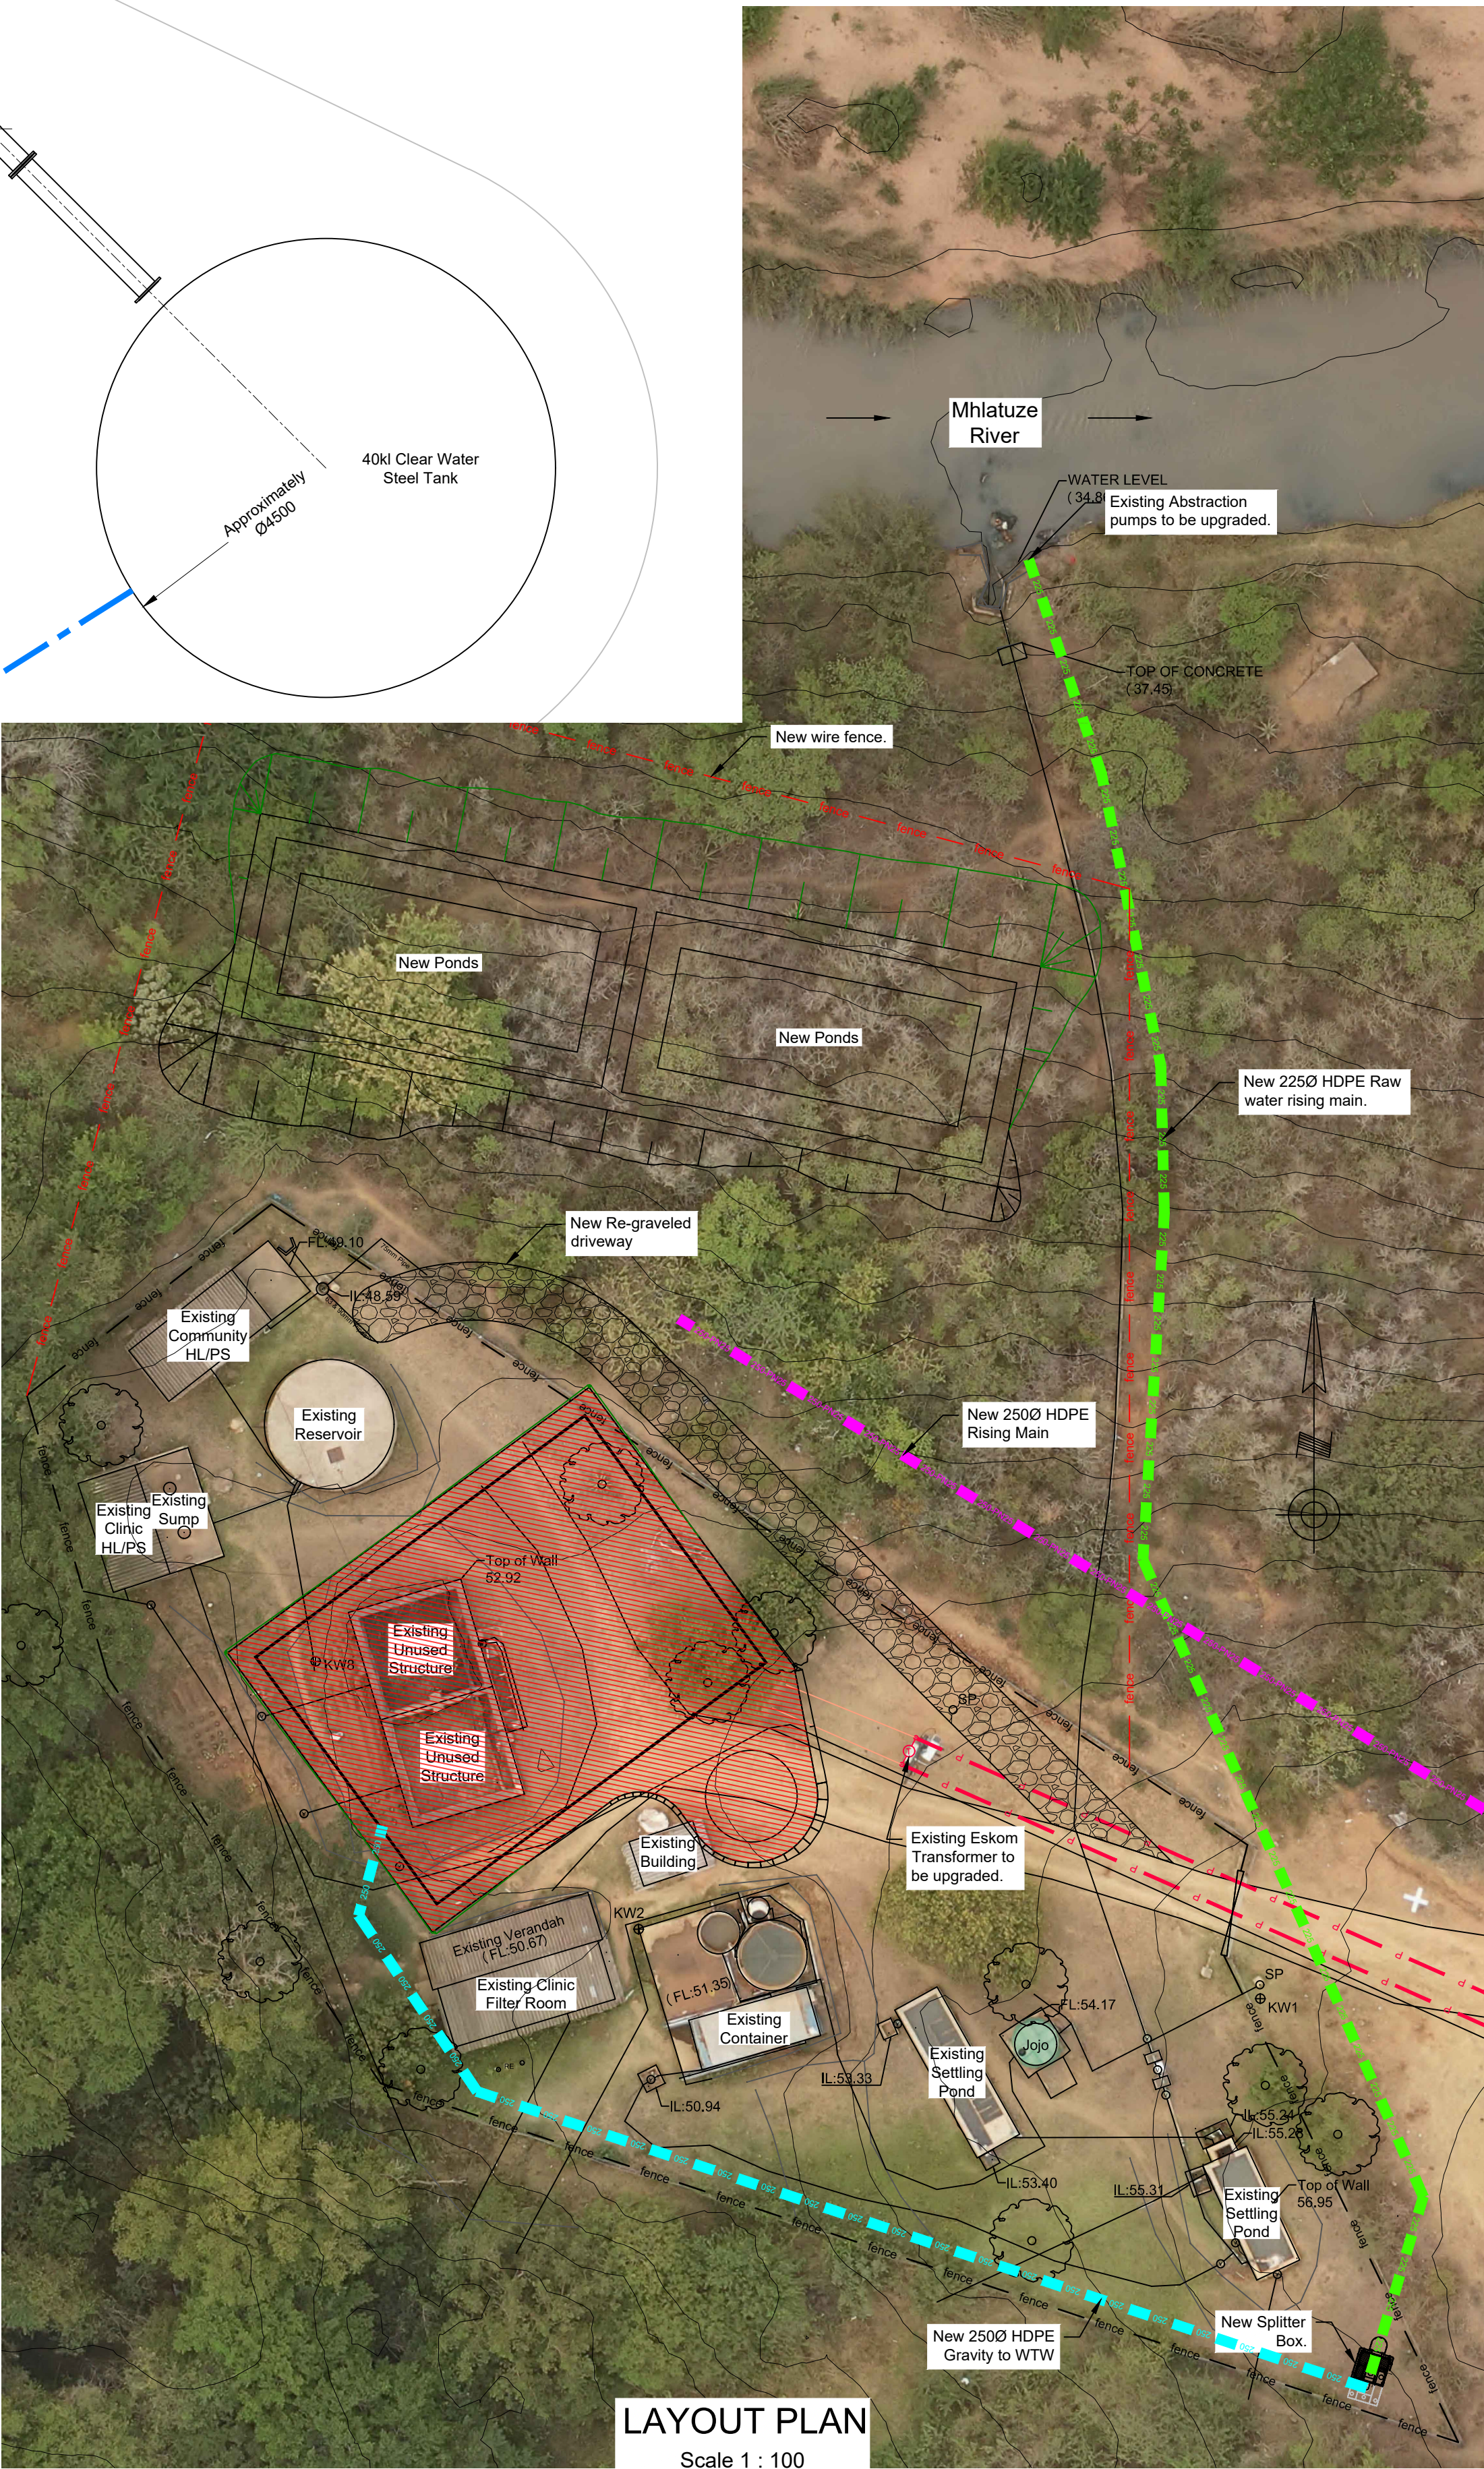

LAYOUT PLAN
Scale 1 : 100

Do not scale off drawing - ASK THE ENGINEER IF UNCERTAIN!
Any discrepancies between any drawings must be clarified before work is continued on site.

FOR TENDER
PURPOSES ONLY

READ THIS DRAWING IN CONJUNCTION WITH

Drawing Number	Drawing Description

AMENDMENTS

Rev.	Date	Description

ECA CONSULTING

Civil and Structural Engineers

VRVHEID OFFICE:
161 High Street |
Vryheid | Kwa Zulu Natal |
RSA
vryheid@ecaconsult.co.za
Tel: +27 (0)34 983 2825
www.ecaconsult.co.za
OTHER OFFICES:
Company Reg.: 2004/019299/07
ISO Registered 9001:2015
MBOMBELA | GAUTENG |
PIETERMARITZBURG |
LADYSMITH

Approved by Engineer: Signature: _____
Name: J.W. Janse v Rensburg
Designation: PrTechEng
ECSA Reg.: 201070143 Date: 27 Oct 2022

Project Funder/ Client:
mig
Municipal Infrastructure Grant


Project Implementing Agent:
KING CETHSWAYO DISTRICT MUNICIPALITY

Approved by Client: _____
Name: _____
Signature: _____ Date: _____

Project:
**KWAHLOKOHLOKO SSA5:
PHASE 4 BULK
AUGMENTATION**


Drawing description:
**PACKAGE PLANT
FLOOR & LAYOUT PLAN**

Drawn: G.D Bezuidenhout	Date: Jul 2022
Scale/s: As Shown	
Drawing number: 22-032-V-PH4-03-01	Rev.: 00

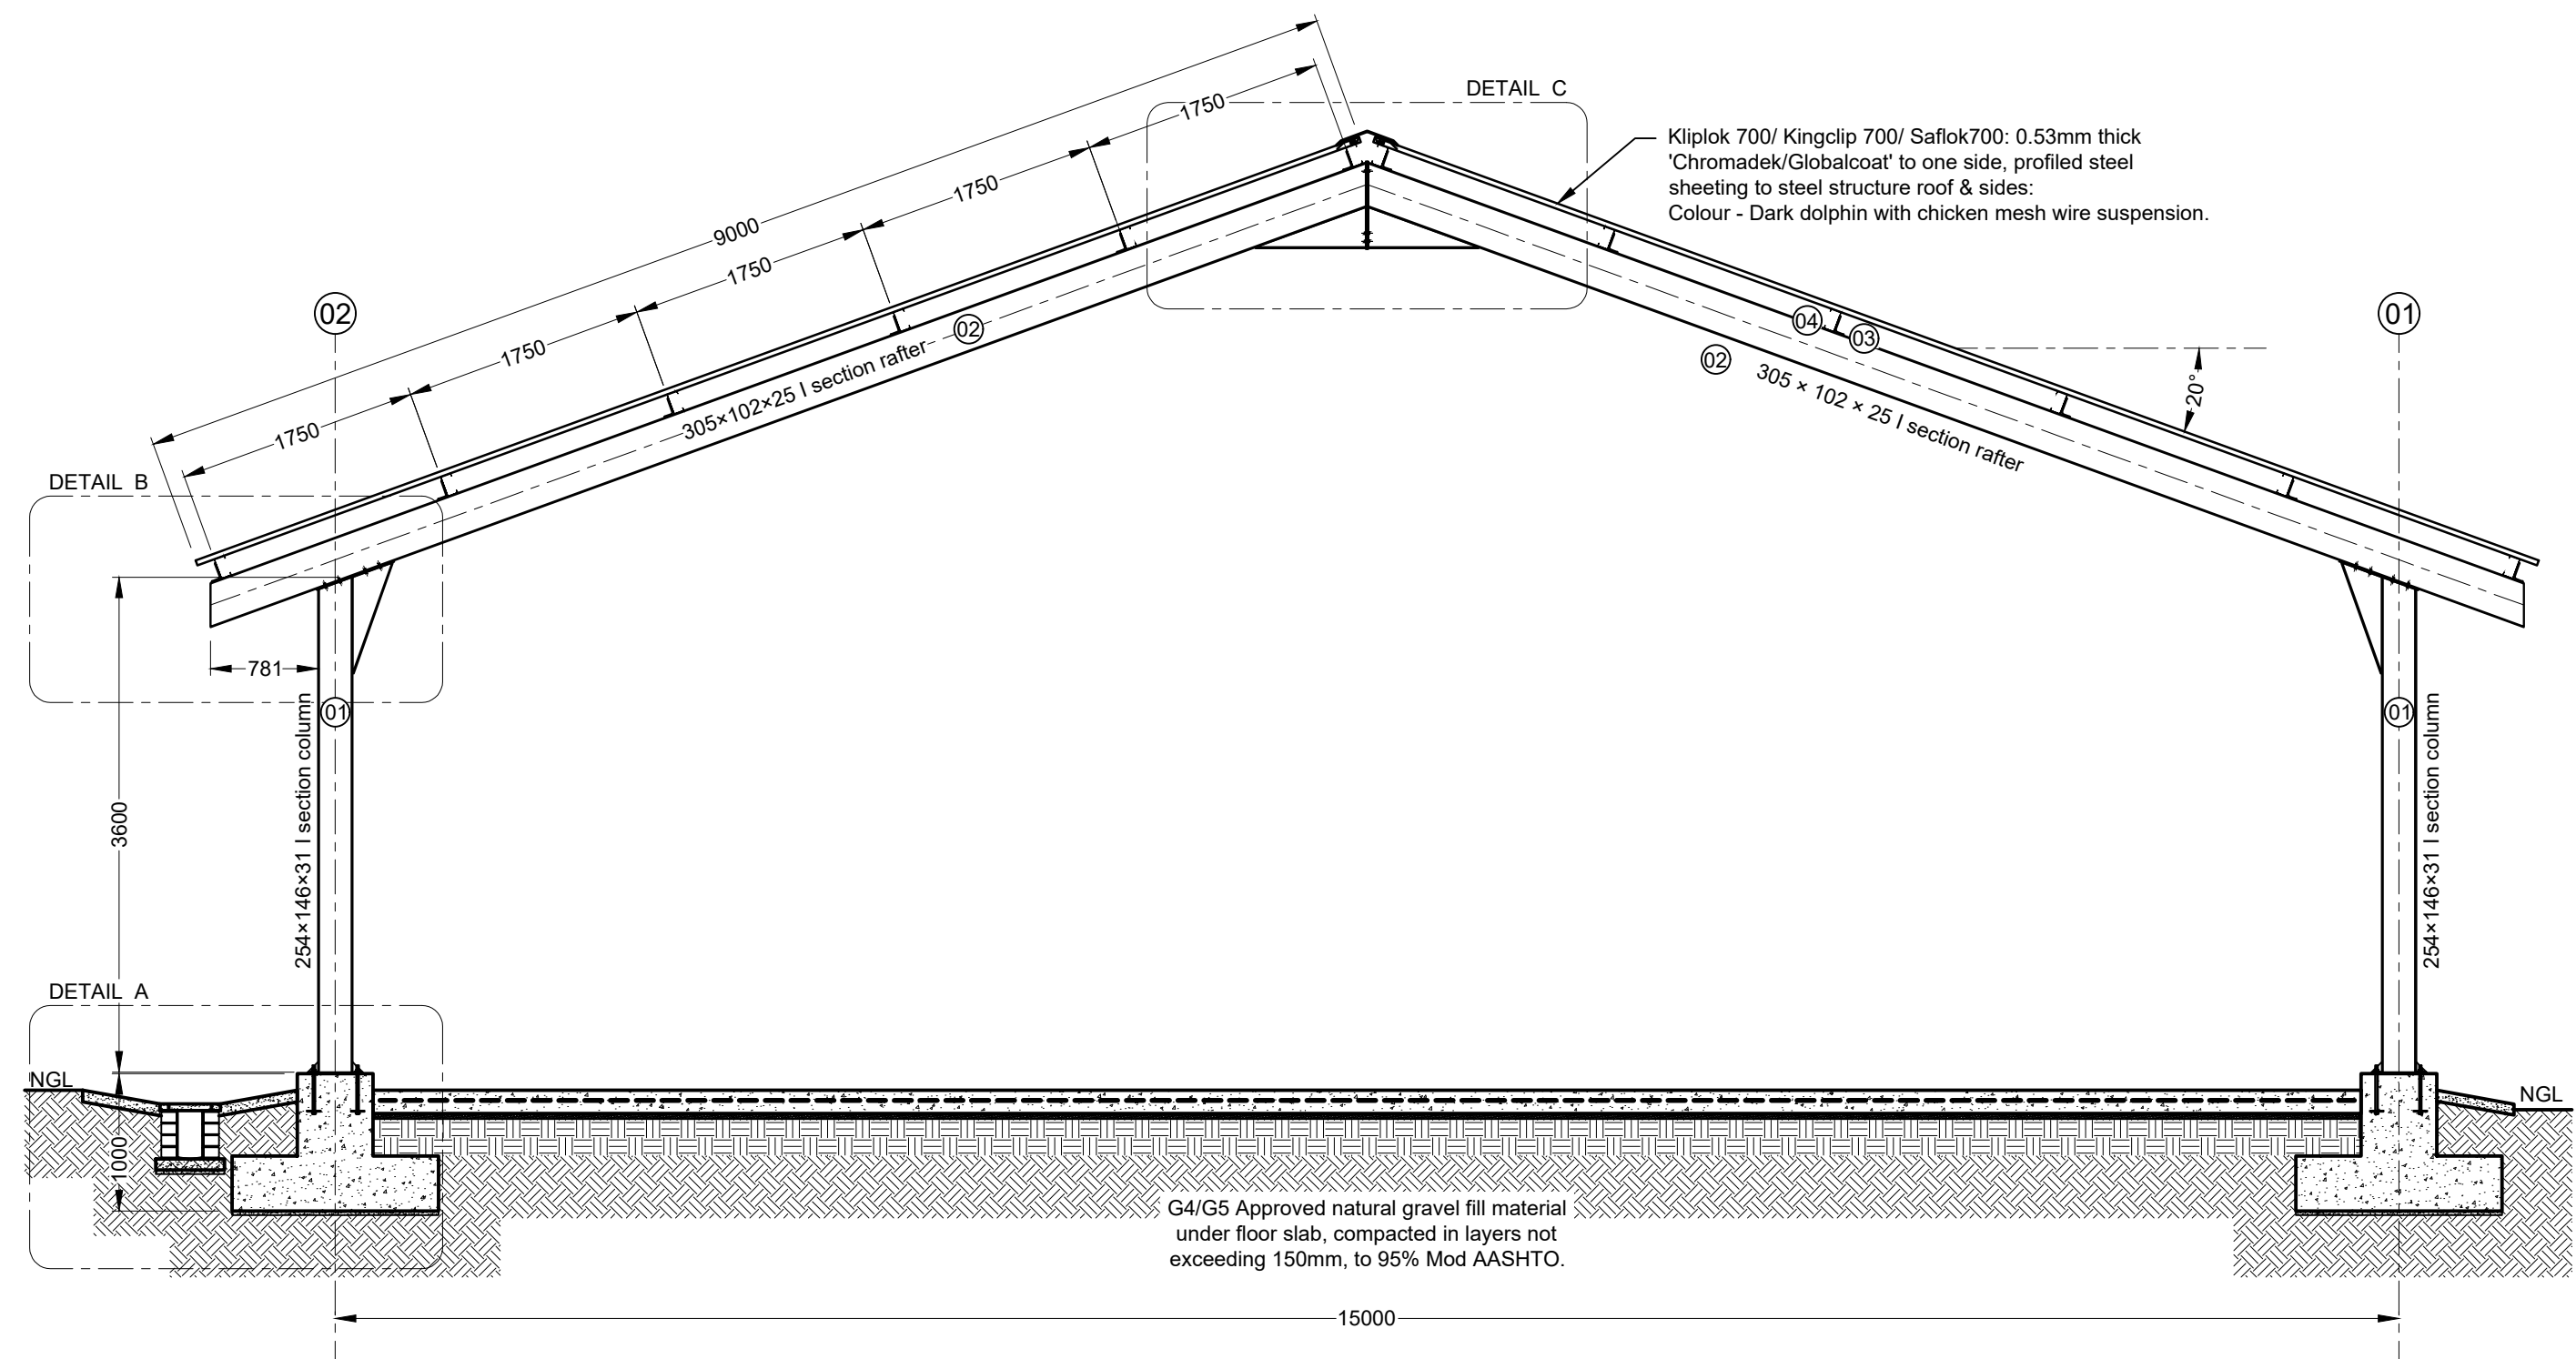


SECTION A-A
Scale 1:50

- LEGEND**
- 1. 254 x 146 x 31 I section column.
 - 2. 305 x 102 x 25 I section rafter.
 - 3. 125 x 75 x 8 mm Cleat
 - 4. 150 x 75 x 20 x 2.5 mm Purlins
 - 5. 50 x 50 x 5 mm Equal angle cross bracing
 - 6. 60 x 60 x 5mm Equal Angle (Cross Bracing)

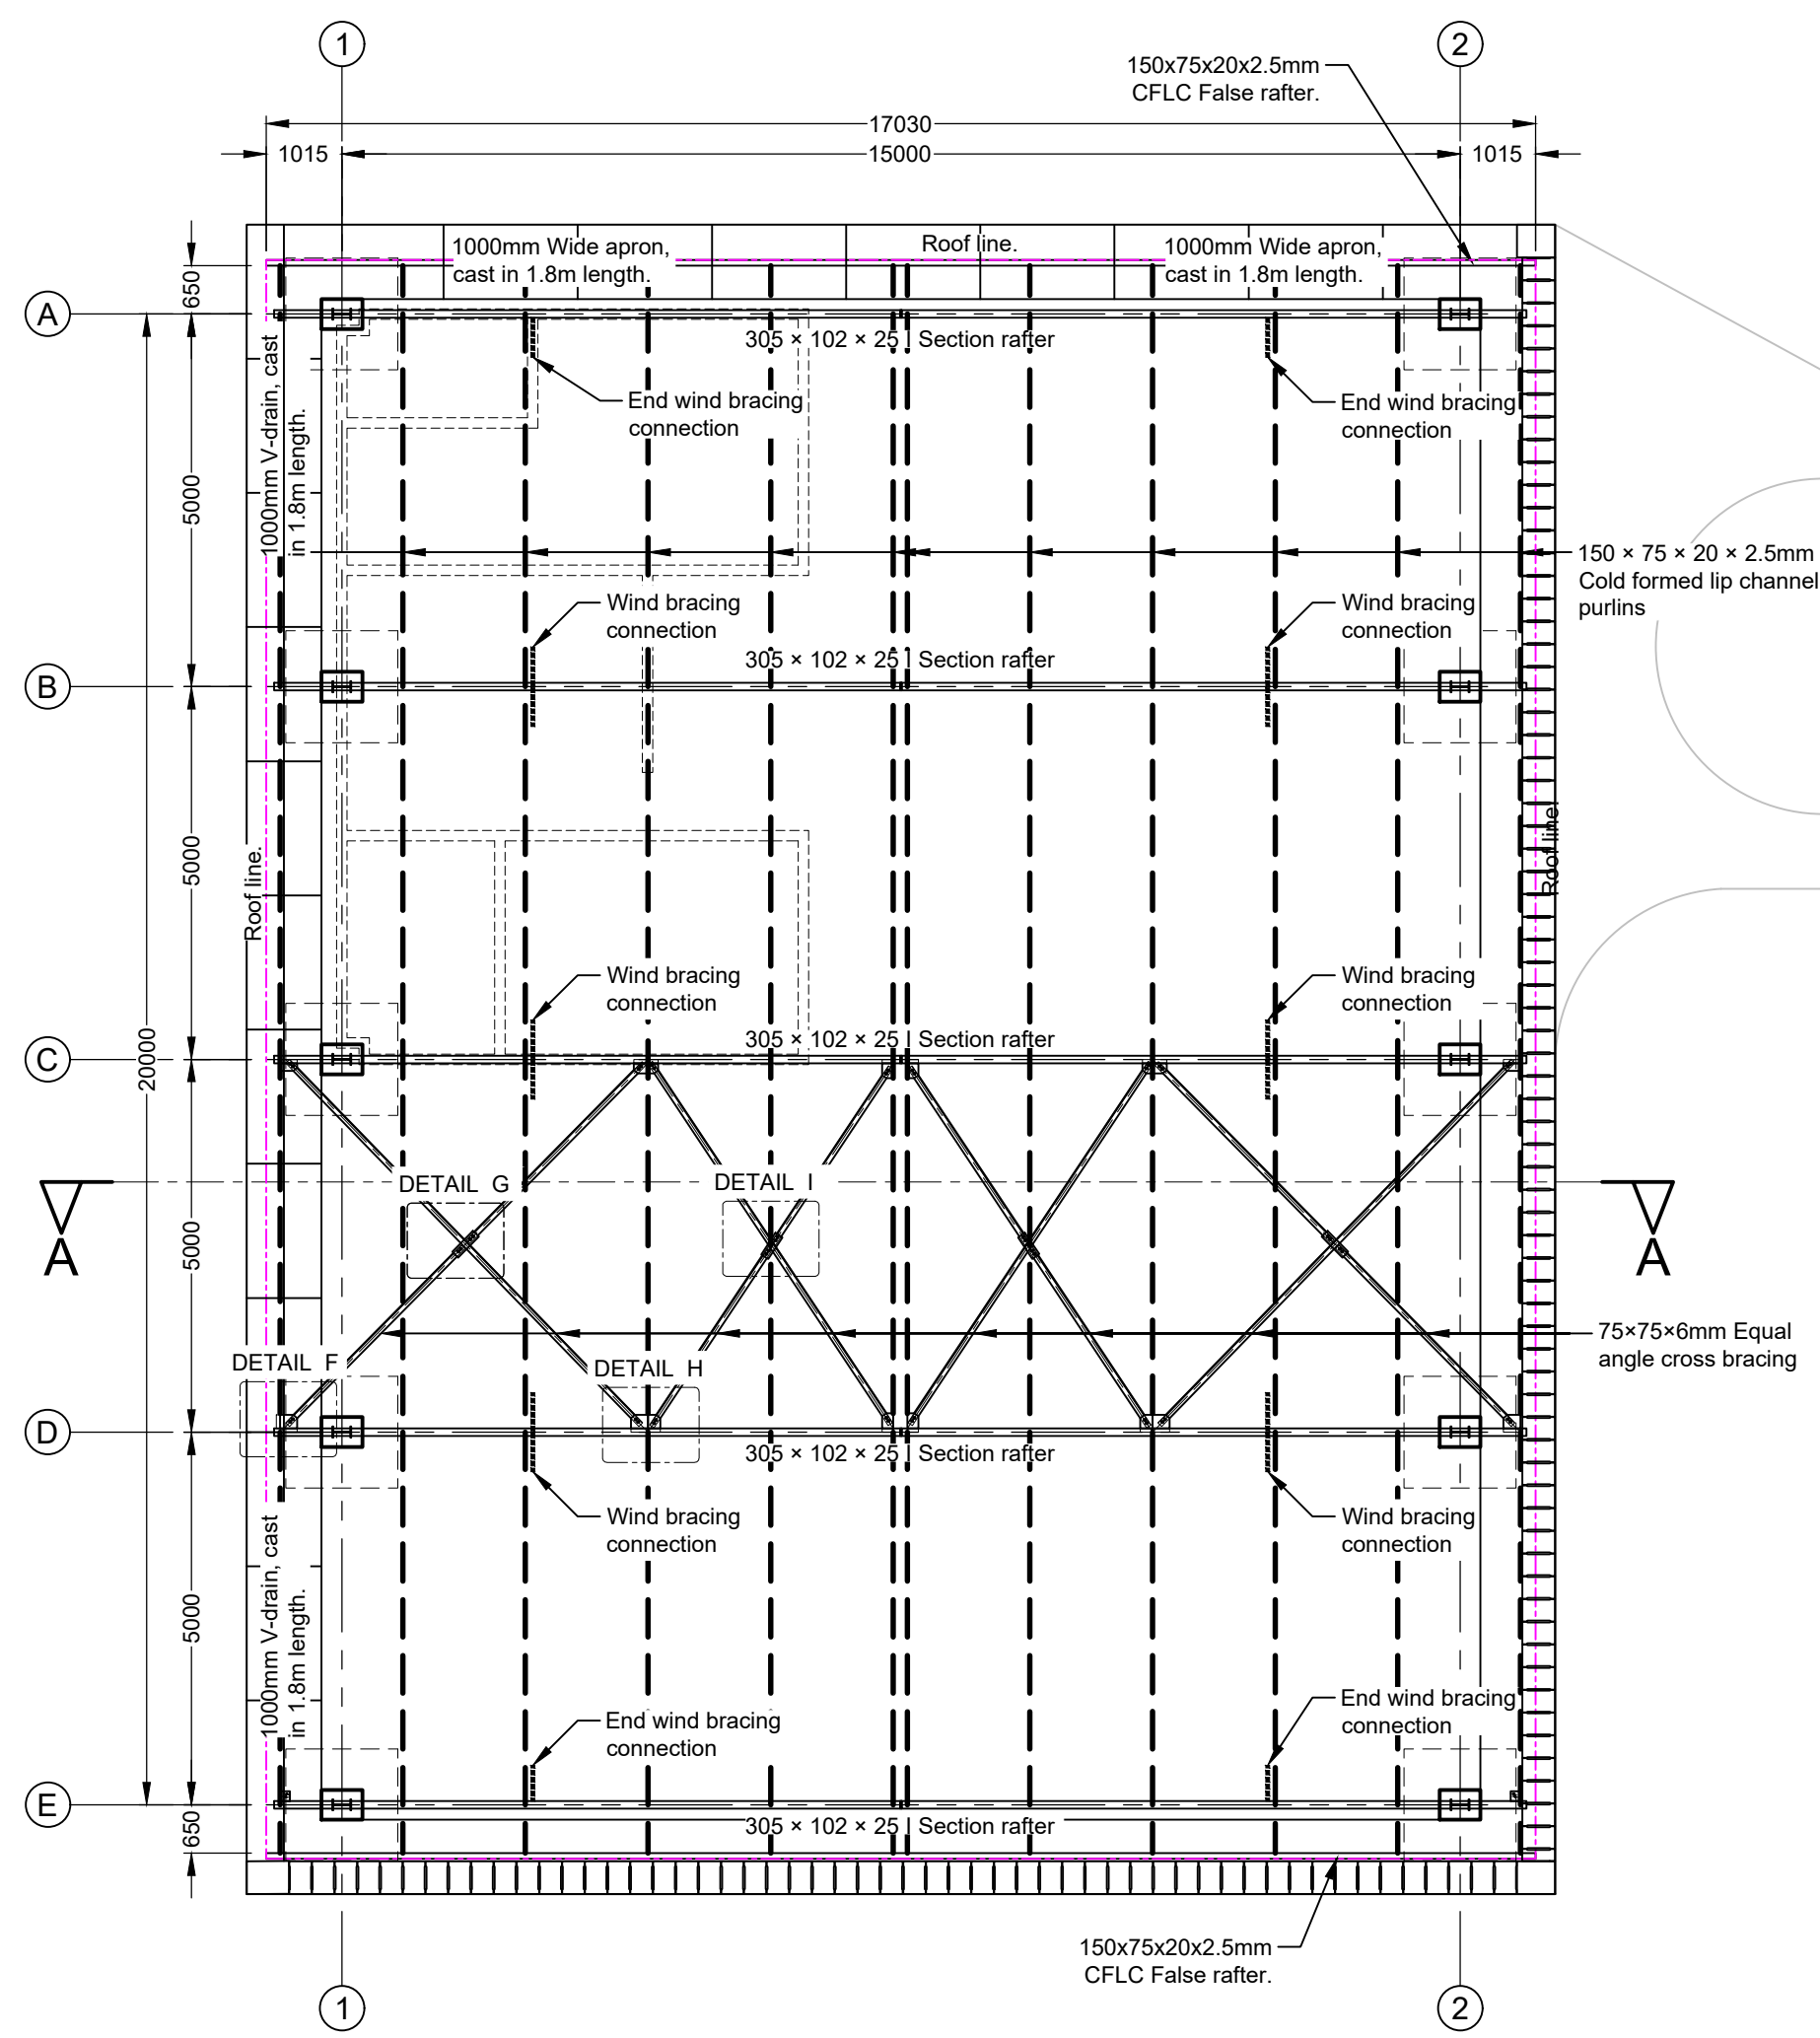

PACKAGE PLANT FLOOR PLAN
Scale 1:100

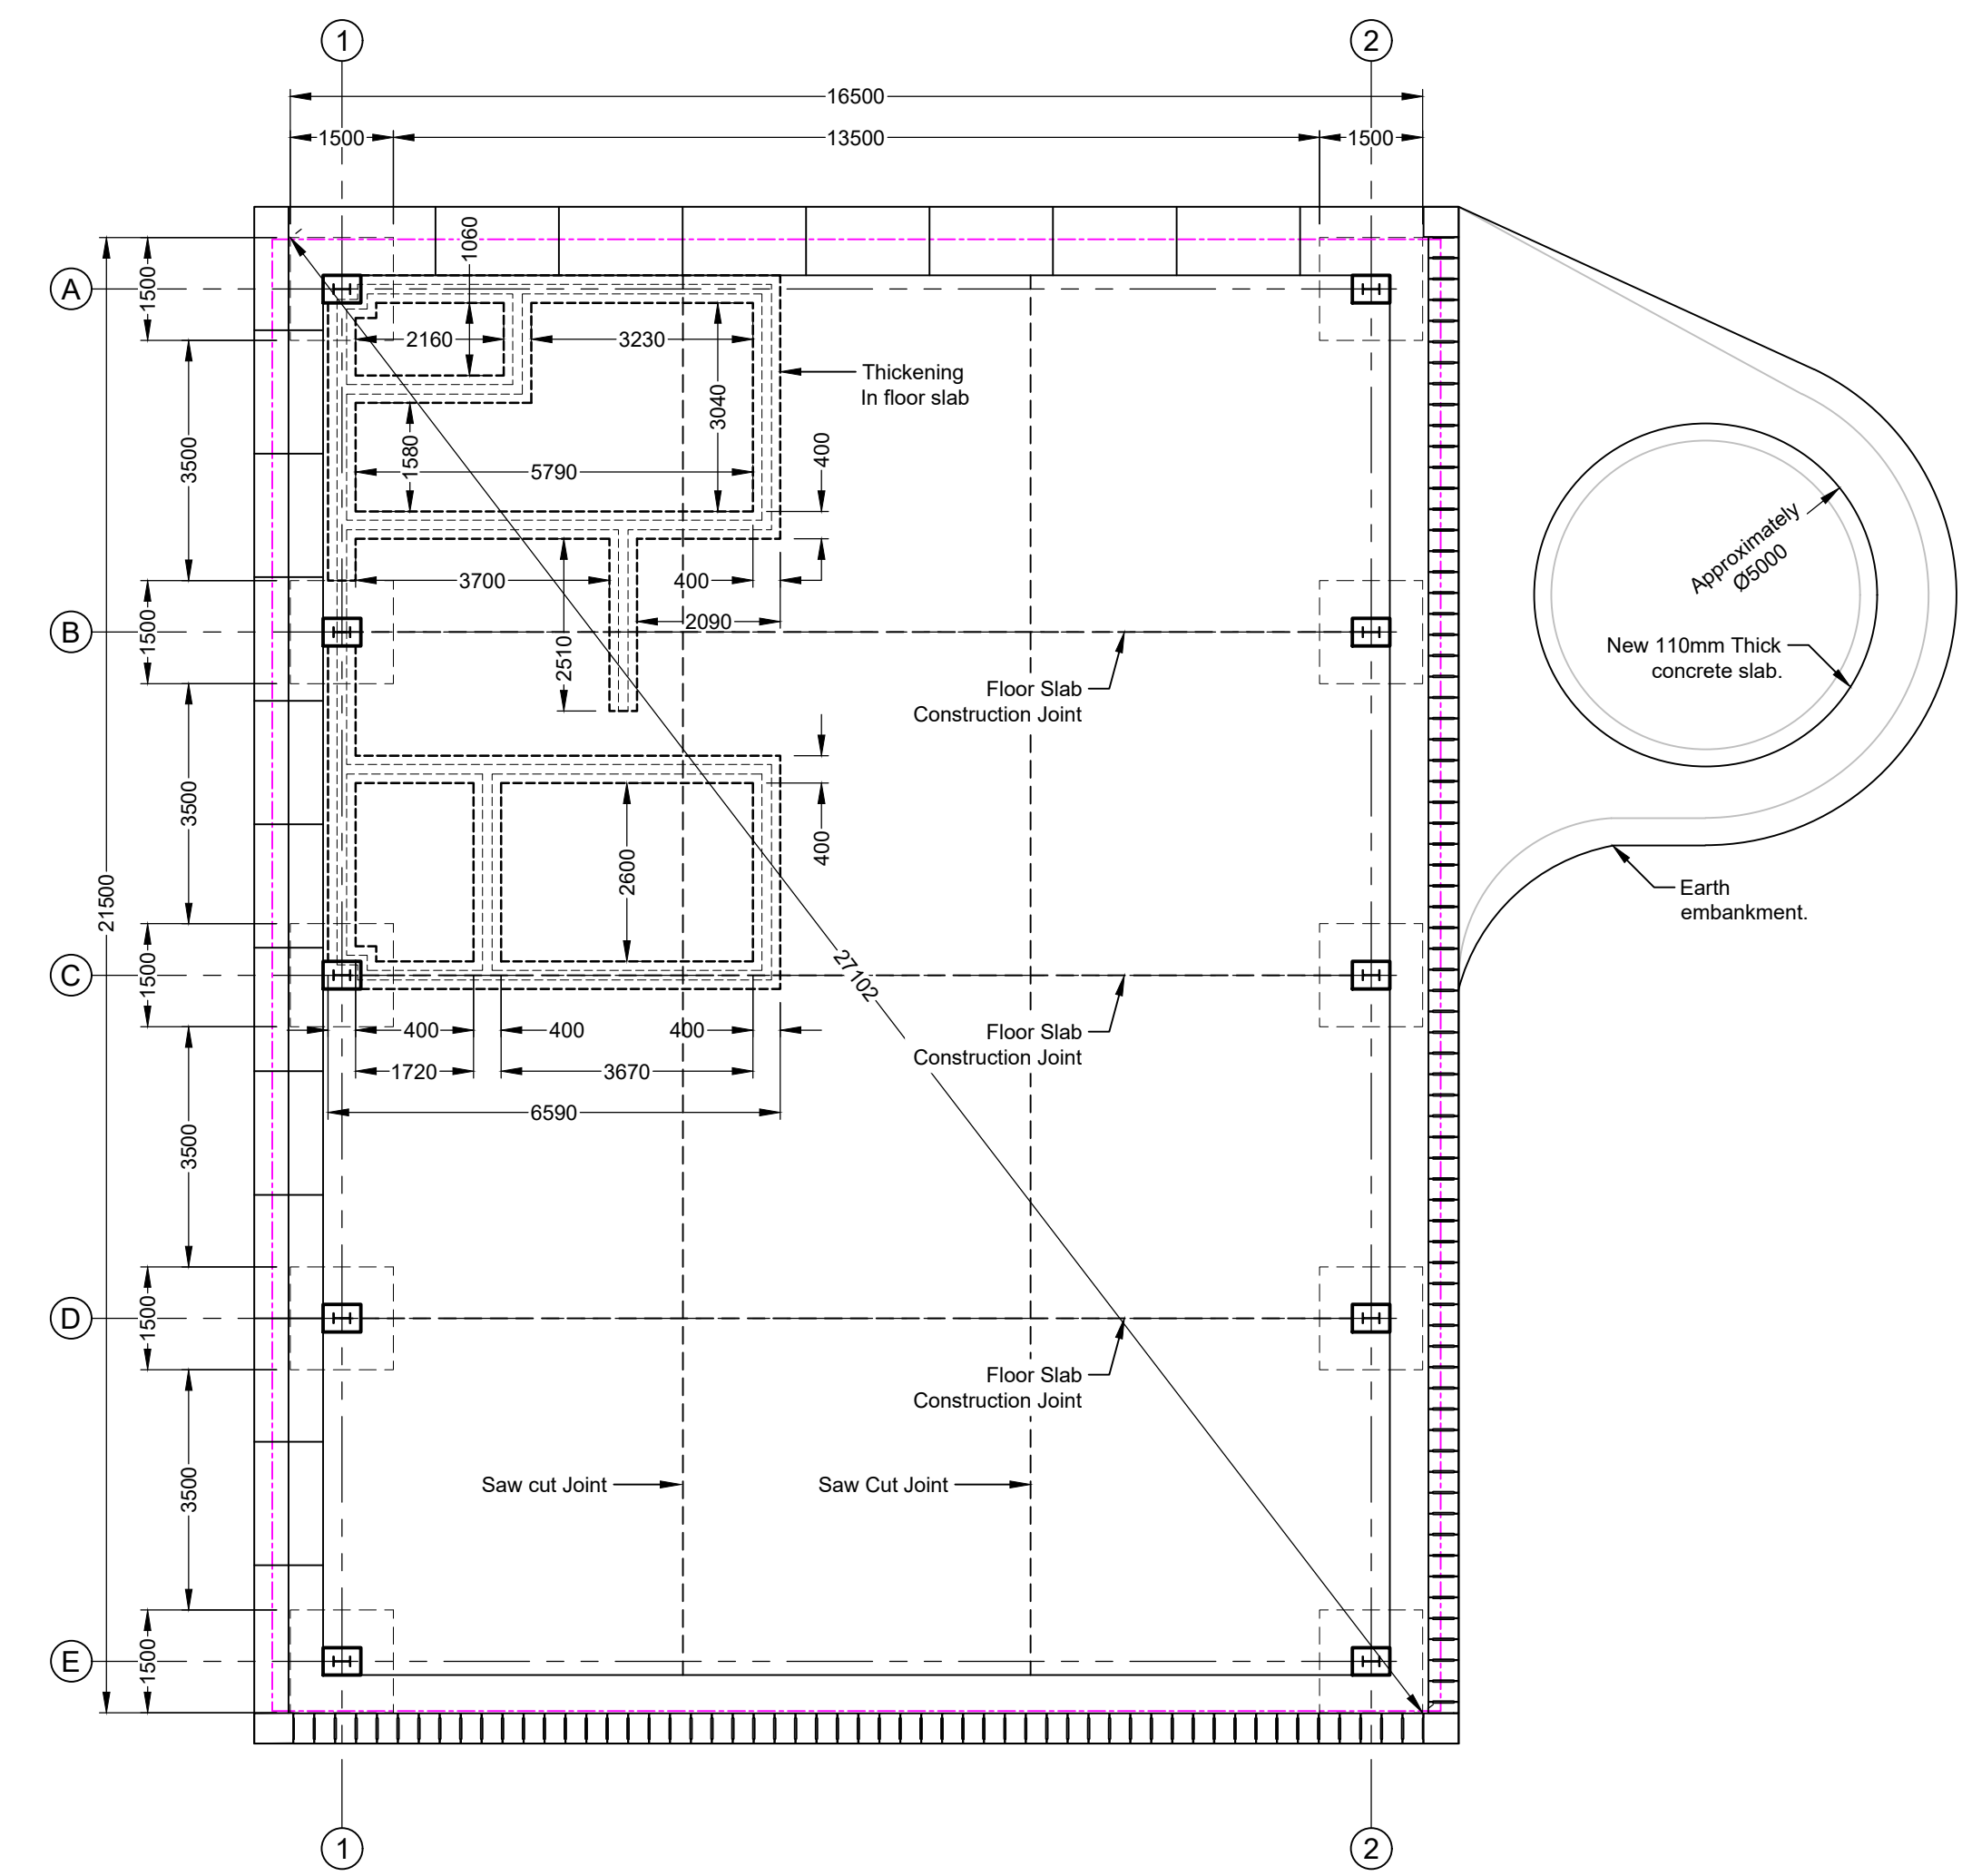

PACKAGE PLANT FLOOR PLAN
Scale 1:100

Do not scale off drawing - ASK THE ENGINEER IF UNCERTAIN!
Any discrepancies between any drawings must be clarified before work is continued on site.

FOR TENDER
PURPOSES ONLY

READ THIS DRAWING IN CONJUNCTION WITH

Drawing Number	Drawing Description

AMENDMENTS

Rev.	Date	Description

ECA CONSULTING
Civil and Structural Engineers

VRVHEID OFFICE:
161 High Street |
Vryheid | Kwa Zulu Natal |
RSA
vryheid@ecaconsult.co.za
Tel: +27 (0)34 983 2825
www.ecaconsult.co.za

OTHER OFFICES:
Company Reg.: 2004/019299/07
ISO Registered 9001:2015
MBOMBELA | GAUTENG |
PIETERMARITZBURG |
LADYSMITH

Approved by Engineer: Signature: _____
Name: J.W. Janse v Rensburg
Designation: PrTechEng
ECSA Reg.: 201070143 Date: 27 Oct 2022

Project Funder/ Client:

mig
Municipal
Infrastructure
Grant

Project Implementing Agent:

**KING
CETSHWAYO
DISTRICT
MUNICIPALITY**

Approved by Client: _____
Name: _____
Signature: _____ Date: _____

Project:
**KWAHLOKOHLOKO SSA5:
PHASE 4 BULK
AUGMENTATION**


Drawing description:

**PACKAGE PLANT
PLANS & SECTION**


Drawn: G.D Bezuidenhout Date: Jul 2022

Scale/s: As Shown


Drawing number: 22-032-V-PH4-03-02 Rev.: 00

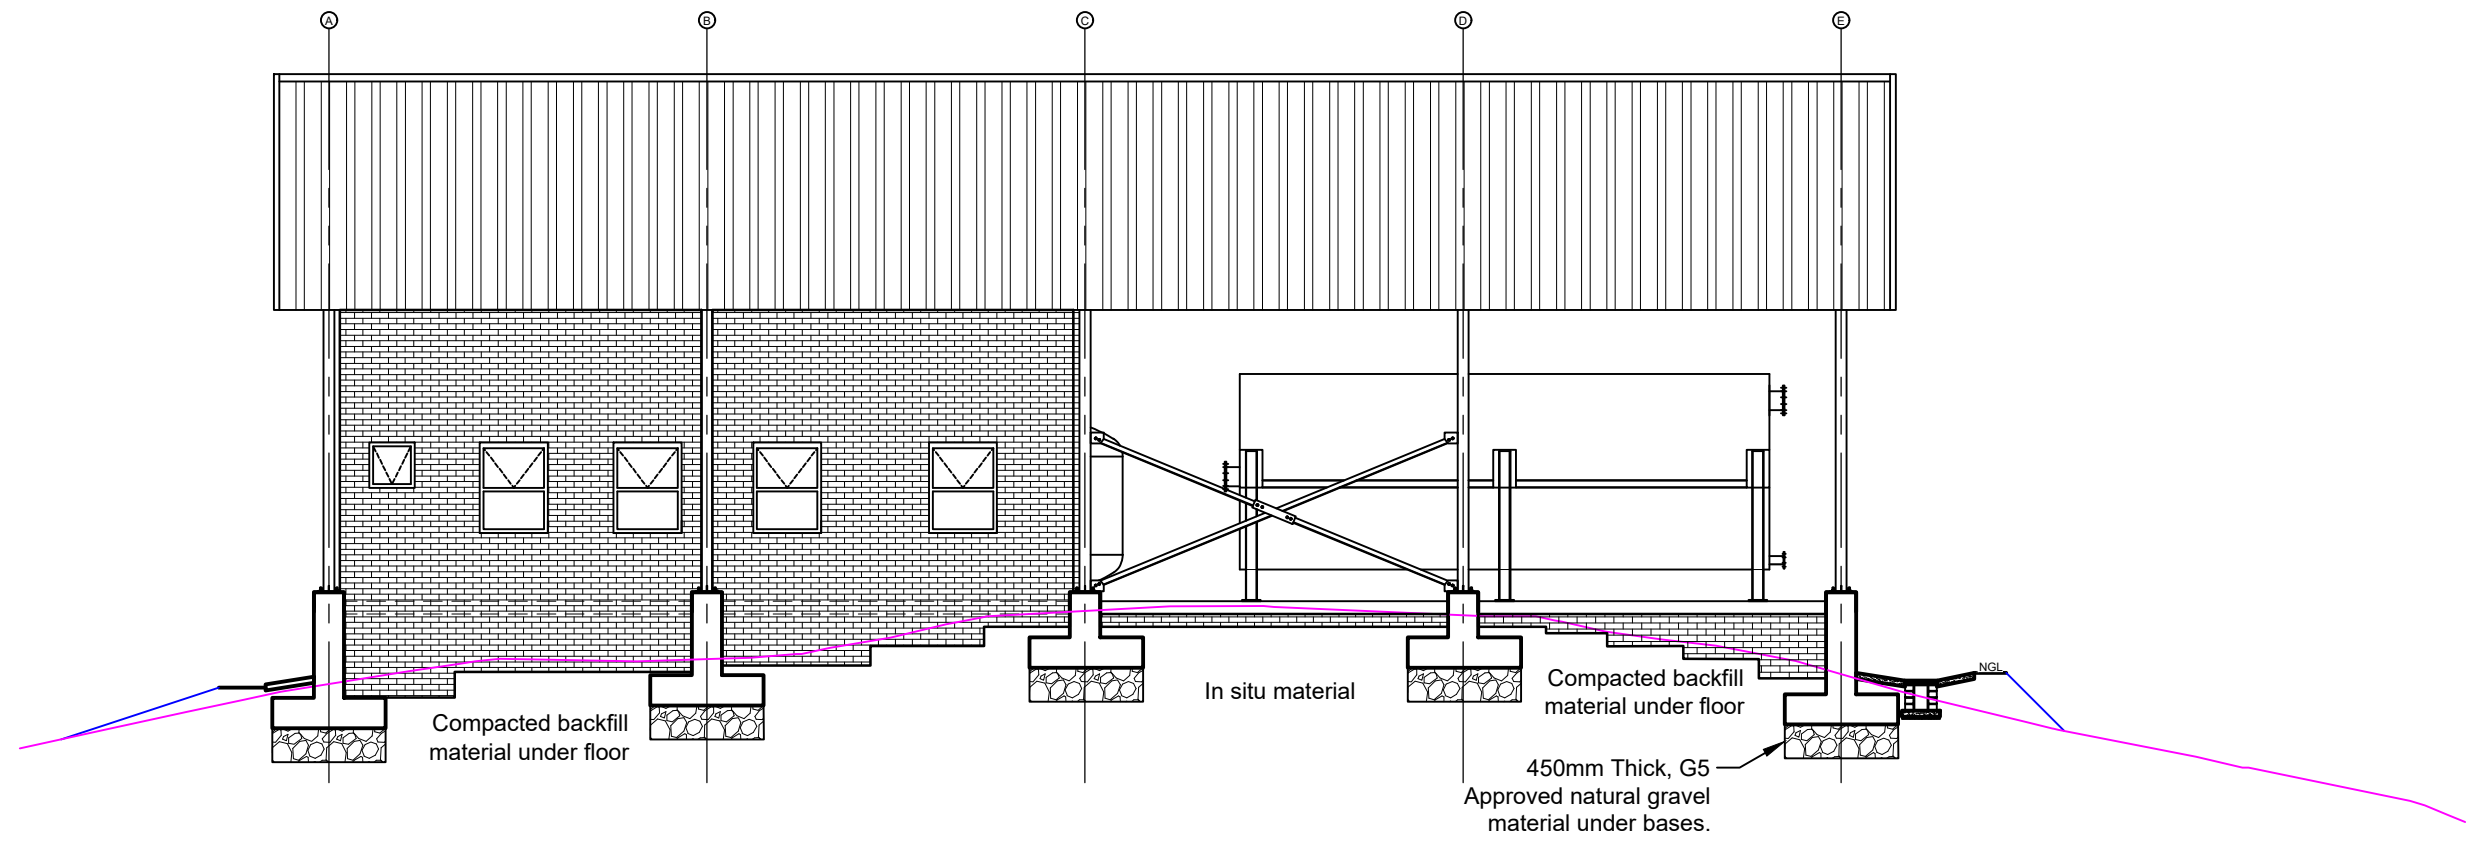


SECTION A1-A1
Scale 1 : 10

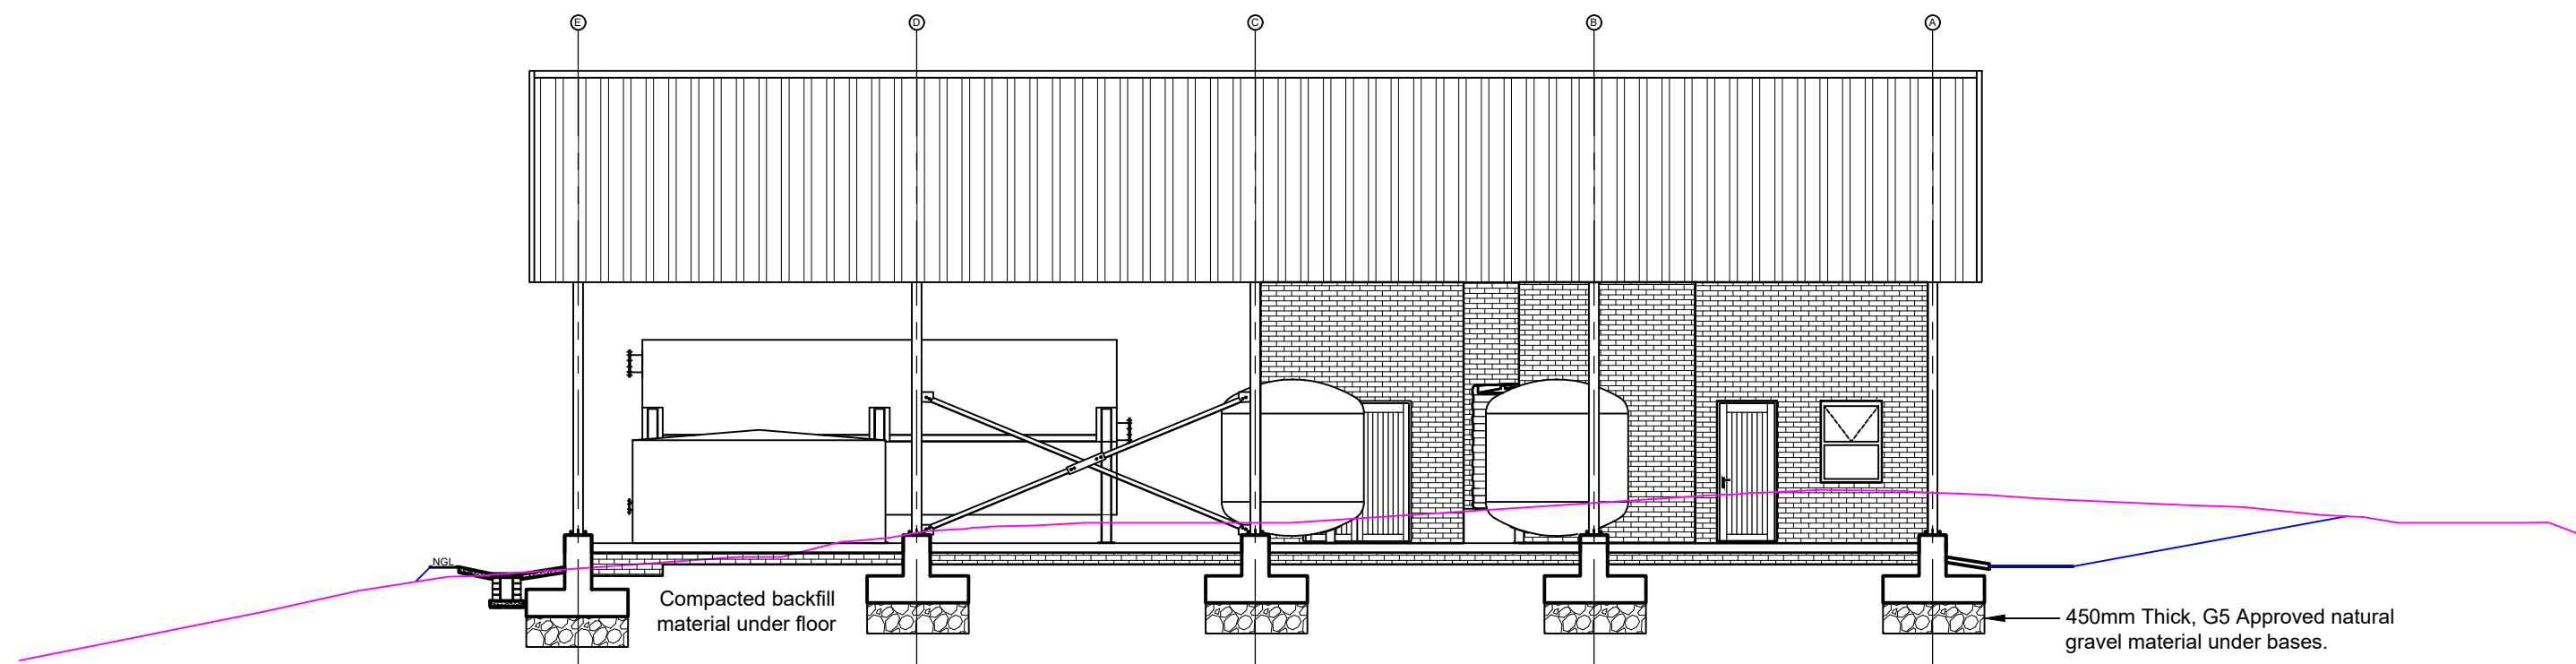


SECTION A2-A2
Scale 1 : 10

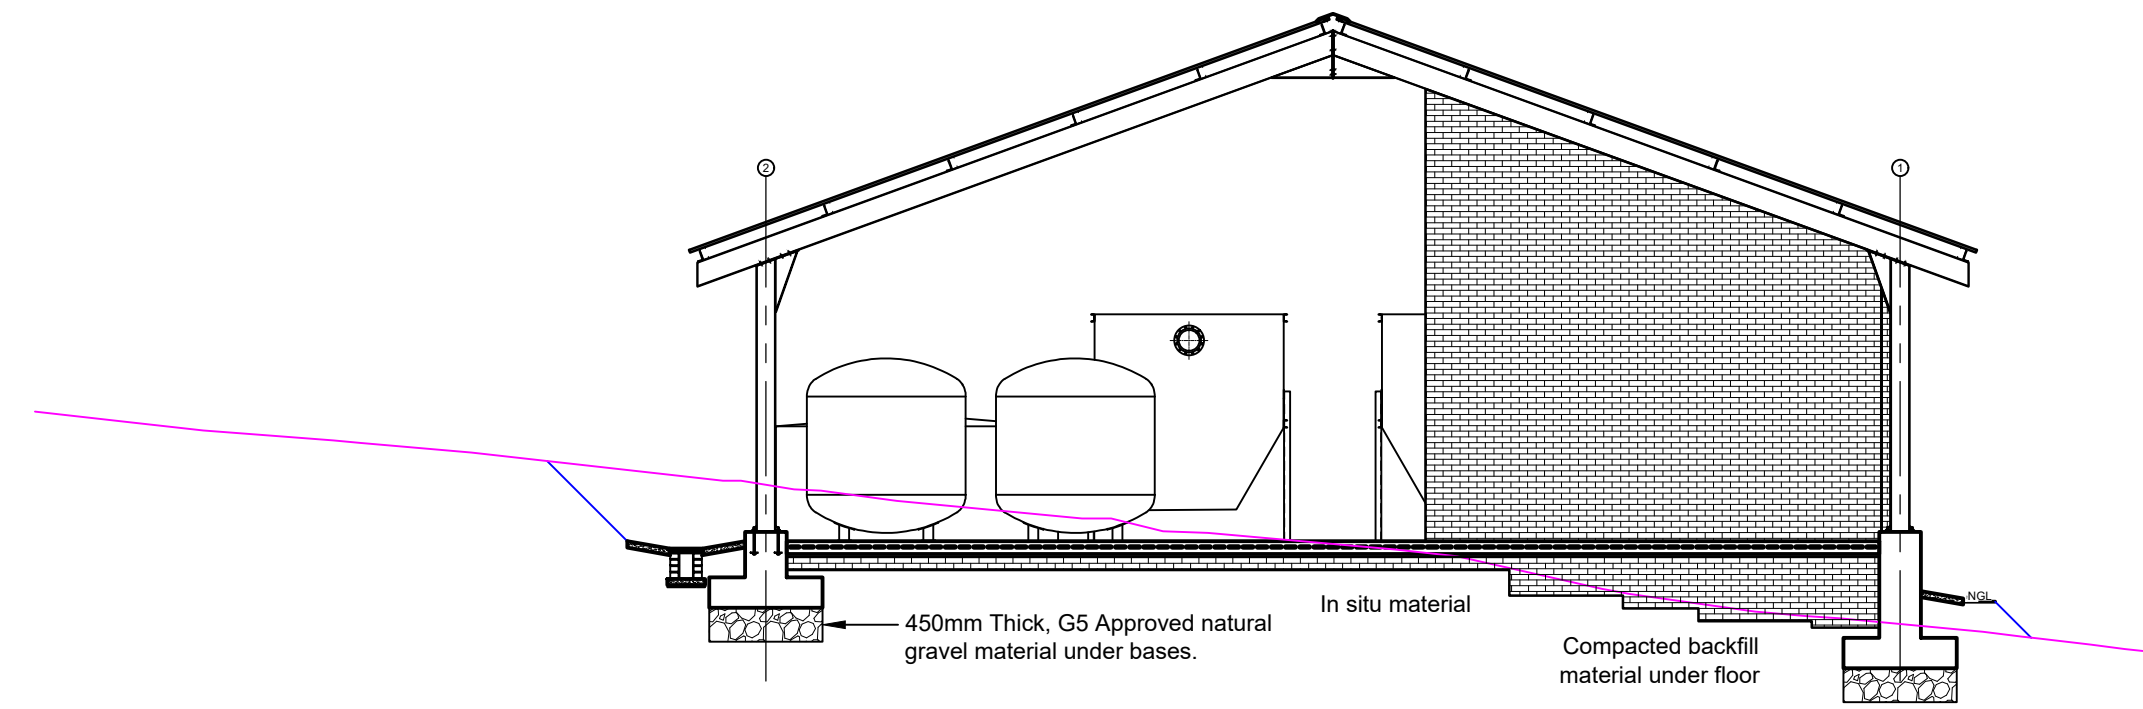

SECTION B1-B1
Scale 1 : 10

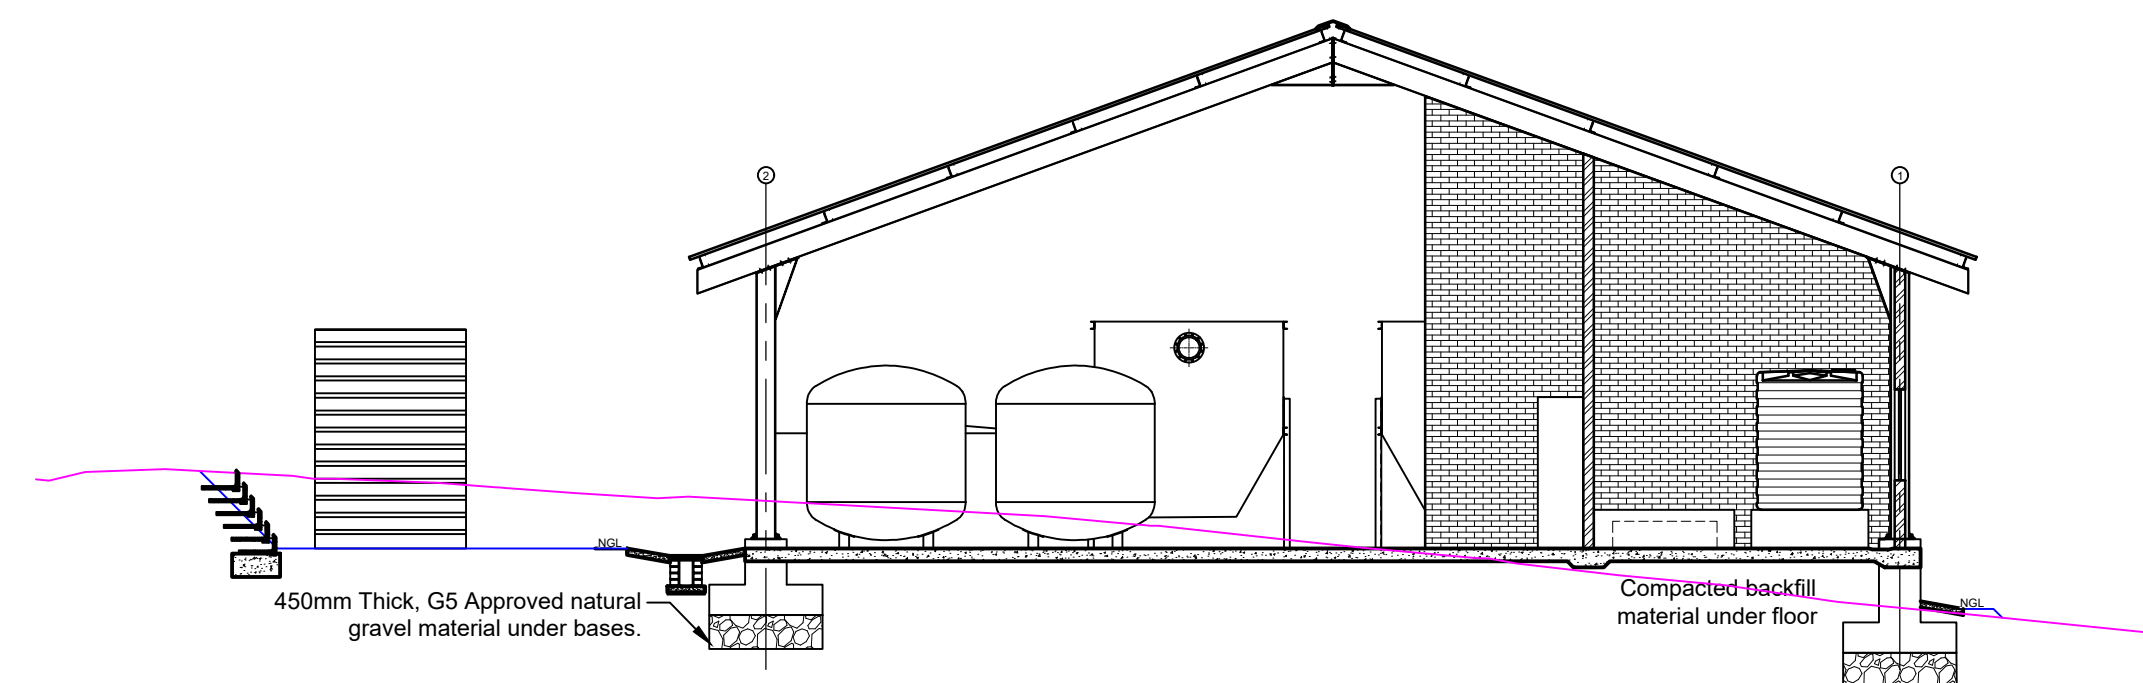

SECTION B2-B2
Scale 1 : 10

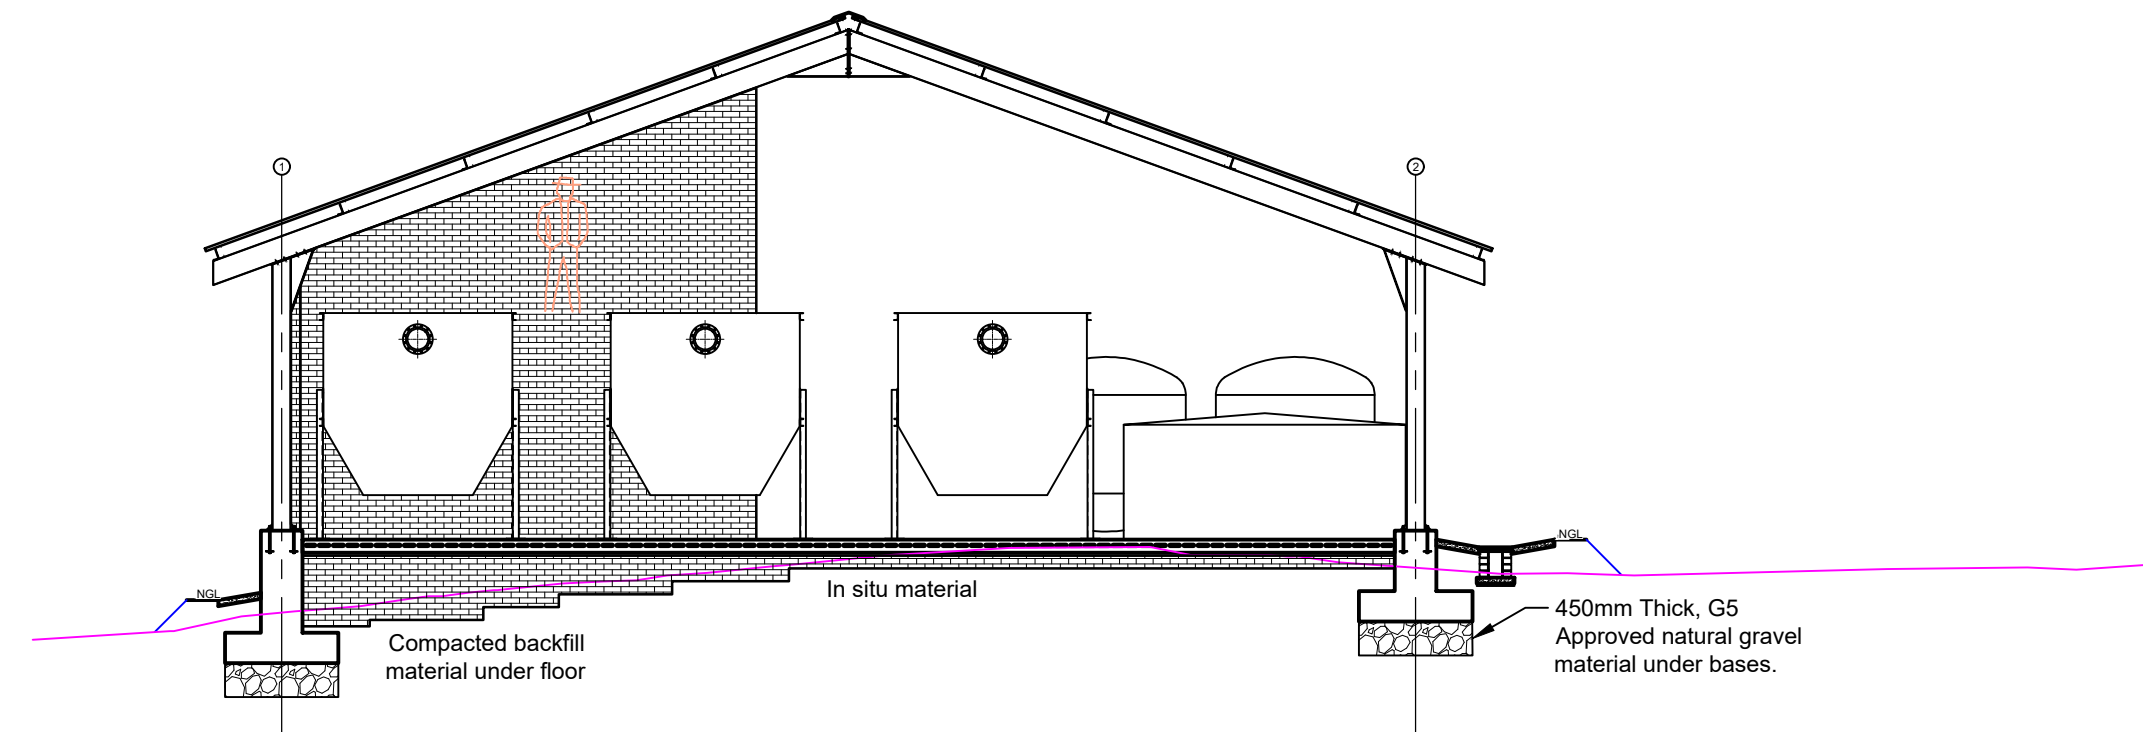

SECTION B3-B3
Scale 1 : 10

Legend:
Existing Ground Level
Proposed Ground Level

Do not scale off drawing - ASK THE ENGINEER IF UNCERTAIN!
Any discrepancies between any drawings must be clarified before work is continued on site.

FOR TENDER
PURPOSES ONLY

READ THIS DRAWING IN CONJUNCTION WITH

Drawing Number	Drawing Description

AMENDMENTS

Rev.	Date	Description

ECA CONSULTING

Civil and Structural Engineers

VRVHEID OFFICE:
161 High Street |
Vryheid | Kwa Zulu Natal |
RSA
vryheid@ecaconsult.co.za
Tel: +27 (0)34 983 2825
www.ecaconsult.co.za
OTHER OFFICES:
MBOMBELA | GAUTENG |
PIETERMARITZBURG |
LADYSMITH

Approved by Engineer: Signature: _____
Name: J.W. Janse v Rensburg
Designation: PrTechEng
ECSA Reg.: 201070143 Date: 27 Oct 2022

Project Funder/ Client:
mig
Municipal Infrastructure Grant



Project Implementing Agent:
KING CETHSWAYO DISTRICT MUNICIPALITY



Approved by Client: _____
Name: _____
Signature: _____ Date: _____




 
Project:
**KWAHLOKOHLOKO SSA5:
PHASE 4 BULK
AUGMENTATION**

Drawing description:
**PACKAGE PLANT
ELEVATIONS**

Drawn: G.D Bezuidenhout Date: Jul 2022

Scale/s: As Shown

Drawing number: 22-032-V-PH4-03-03 Rev.: 00

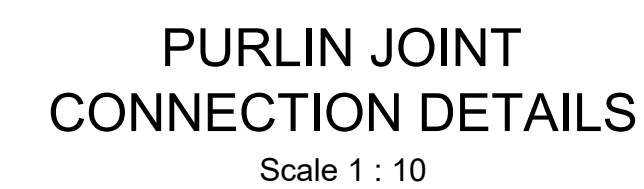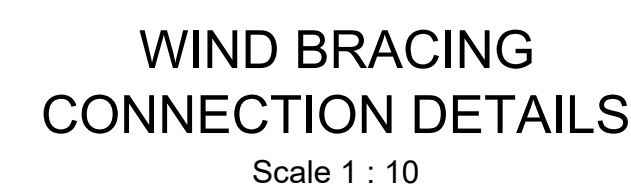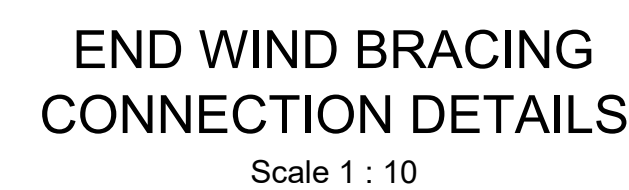

**FOR TENDER
PURPOSES ONLY**

Drawing Number	Drawing Description

[illegible]



ECA CONSULTING

Civil and Structural Engineers

VRVHEID OFFICE:

161 High Street |
 Vryheid | Kwa Zulu Natal |
 RSA
vryheid@ecaconsult.co.za
 Tel : +27 (0)34 983 2825
www.ecaconsult.co.za

OTHER OFFICES:

MBOMBELA | GAUTENG |
 PIETERMARITZBURG |
 LADYSMITH

Company Reg.: 2004/019299/07
 ISO Registered 9001:2015

Approved by Engineer:	Signature:
Name: J.W. Janse v Rensburg	
Designation: PrTechEng	
ECSA Reg.: 201070143	Date: 27 Oct 2022

Project Funder/ Client:

mig

Municipal
Infrastructure
Grant

The seal of the City of Los Angeles, featuring an eagle with spread wings perched atop a shield. The shield contains a sunburst and a ship. The entire emblem is encircled by a border with the words "CITY OF LOS ANGELES" and "1850".

Project Implementing Agent:

**KING
CETSHWAYO
DISTRICT
MUNICIPALITY**



KING CETSHWAYO
DISTRICT MUNICIPALITY

Approved by Client: _____

Name: _____

Signature: _____ Date: _____

Project:

**KWAHLOKOHLOKO SSA5:
PHASE 4 BULK
AUGMENTATION**


Drawing description:

**PACKAGE PLANT
DETAILS 01**


Drawn: G.D Bezuidenhout Date: Jul 2022

Scale/s: As Shown


Drawing number:	Rev.:
22-032-V-PH4-03-04	00

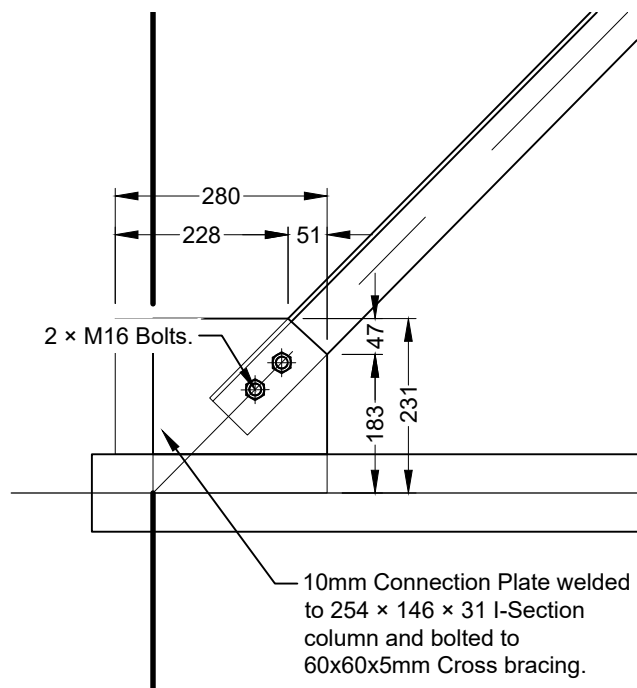


CROSS BRACING
CONNECTION DETAIL F
Scale 1 : 10

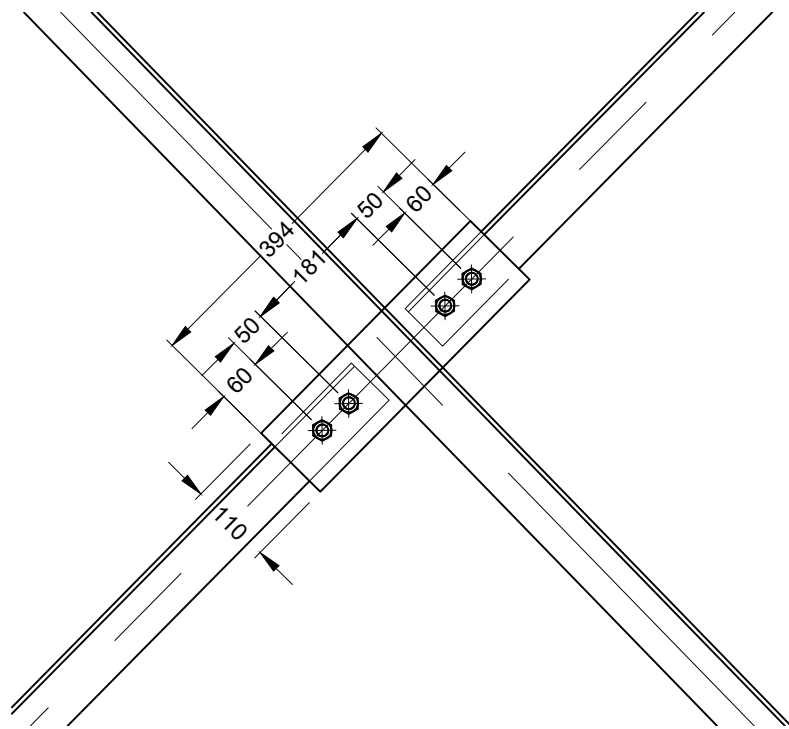


CROSS BRACING
CONNECTION DETAIL G
Scale 1 : 10

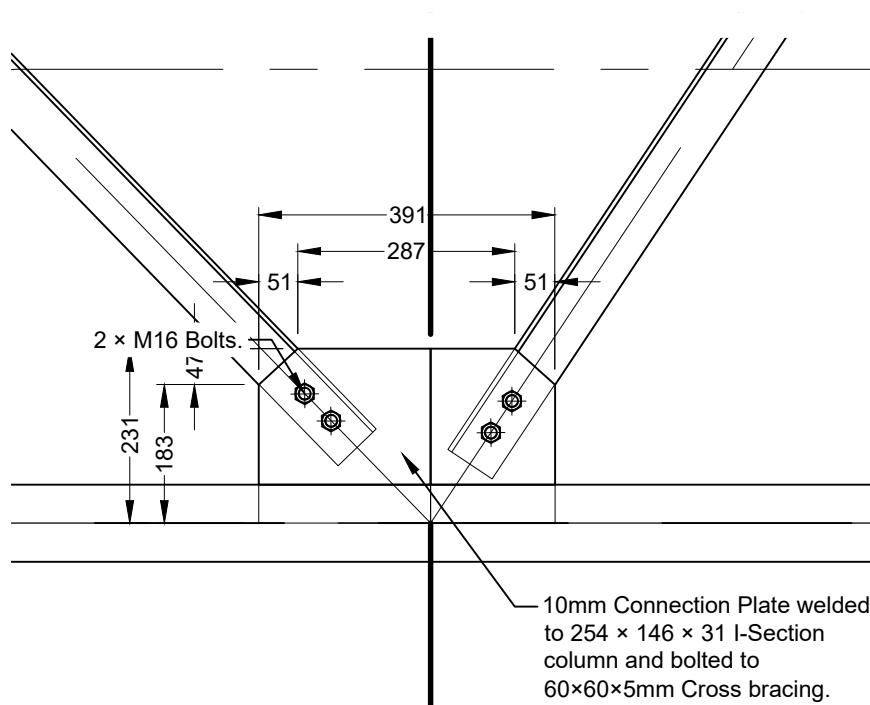


CROSS BRACING
CONNECTION DETAIL H
Scale 1 : 10

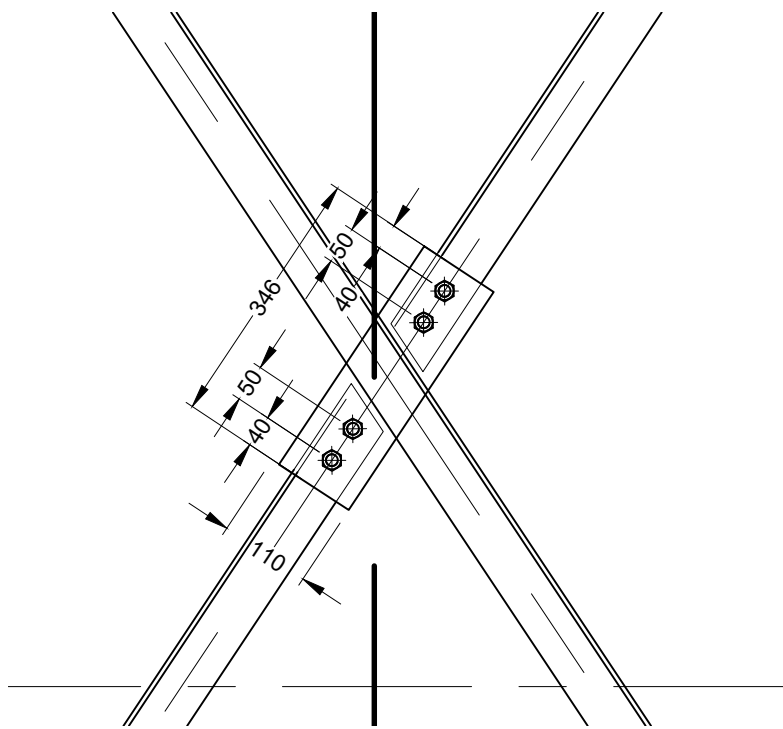


CROSS BRACING
CONNECTION DETAIL I
Scale 1 : 10

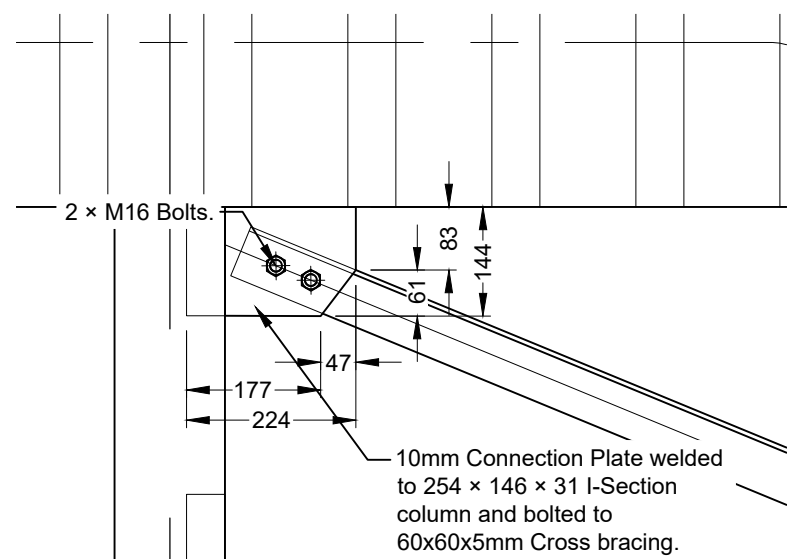


CROSS BRACING
CONNECTION DETAIL J
Scale 1 : 10

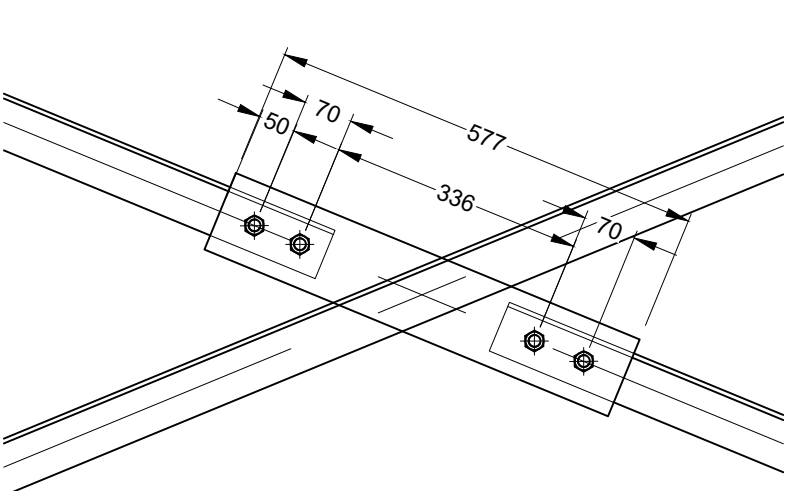


CROSS BRACING
CONNECTION DETAIL K
Scale 1 : 10

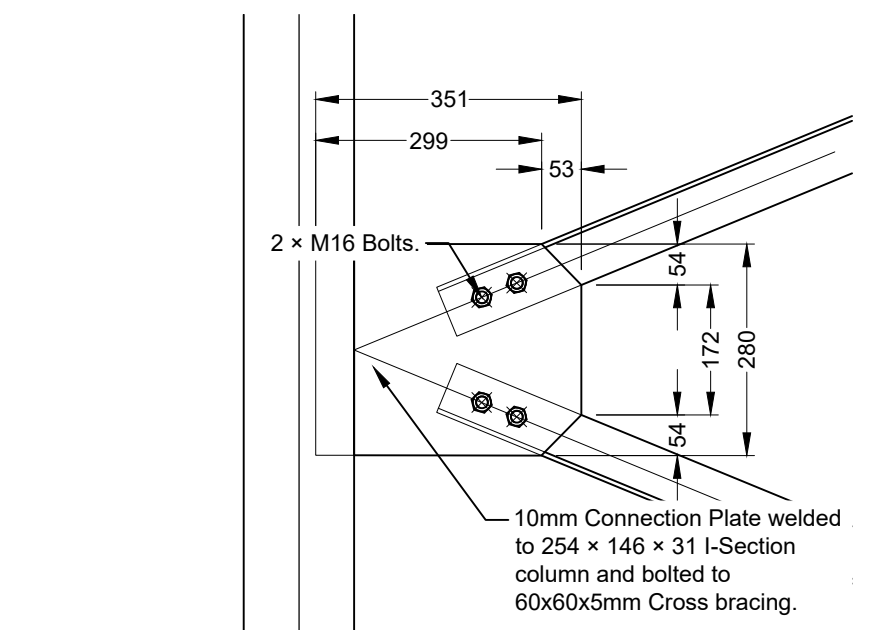


CROSS BRACING
CONNECTION DETAIL L
Scale 1 : 10

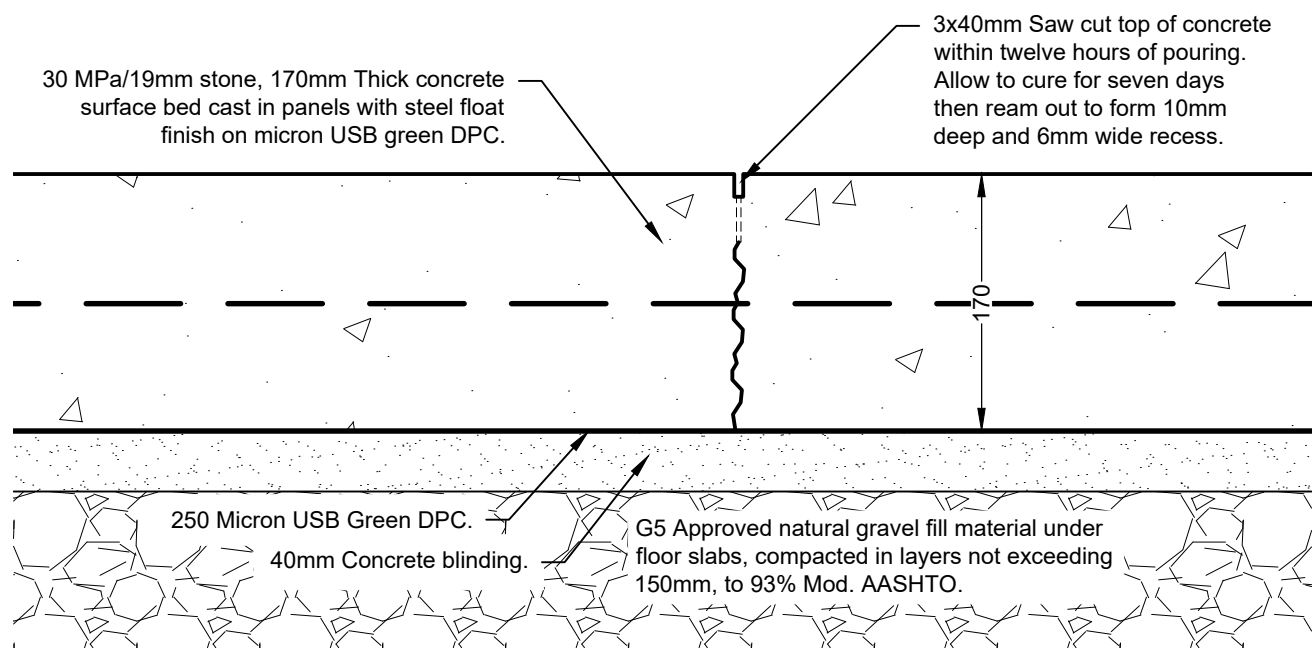

TYPICAL SAW CUT JOINT DETAIL
Scale 1:10

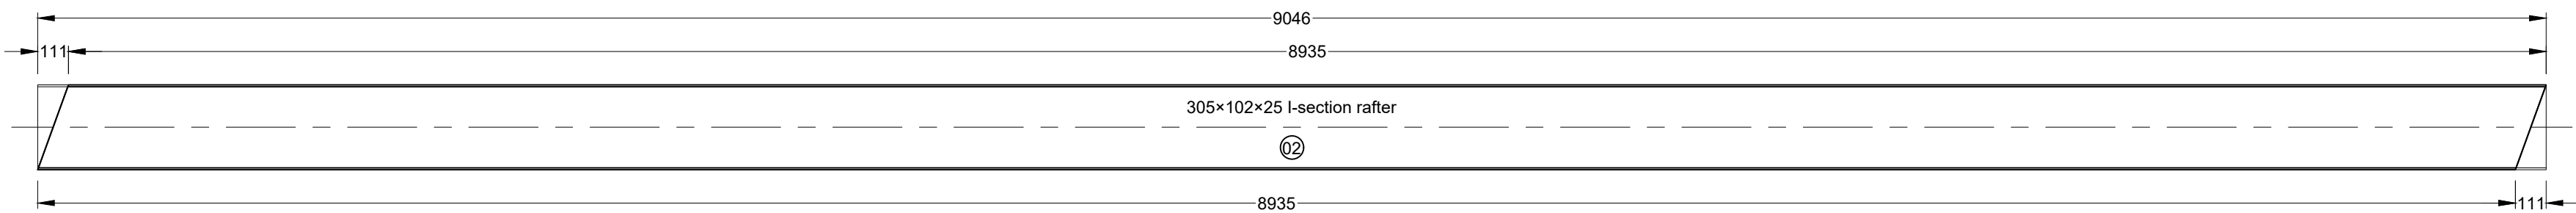

RAFTER DETAIL
Scale 1:20

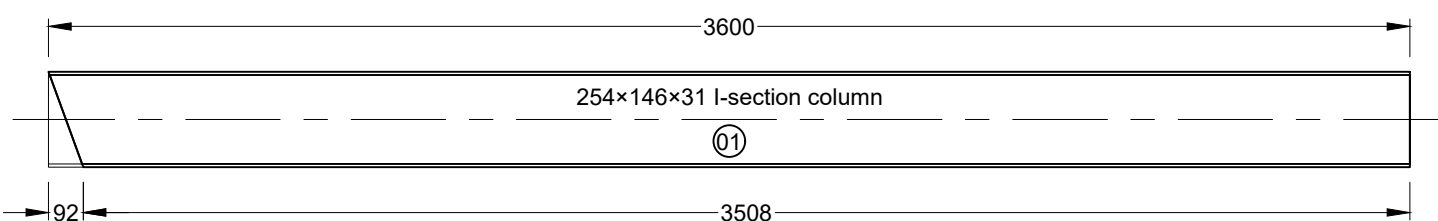

COLUMN DETAIL
Scale 1:20

Do not scale off drawing - ASK THE ENGINEER IF UNCERTAIN!
Any discrepancies between any drawings must be clarified before work is continued on site.

FOR TENDER
PURPOSES ONLY

READ THIS DRAWING IN CONJUNCTION WITH

Drawing Number	Drawing Description

AMENDMENTS

Rev.	Date	Description

ECA CONSULTING

Civil and Structural Engineers

VRVHEID OFFICE:
161 High Street |
Vryheid | Kwa Zulu Natal |
RSA
vryheid@ecaconsult.co.za
www.ecaconsult.co.za
OTHER OFFICES:
MBOMBELA | GAUTENG |
PIETERMARITZBURG |
LADYSMITH

Approved by Engineer: Signature: _____
Name: J.W. Janse v Rensburg
Designation: PrTechEng
ECSA Reg.: 201070143 Date: 27 Oct 2022

Project Funder/ Client:

mig
Municipal
Infrastructure
Grant



Project Implementing Agent:

**KING
CETSHWAYO
DISTRICT
MUNICIPALITY**


KING CETSHWAYO
DISTRICT MUNICIPALITY

Approved by Client:

Name: _____

Signature: _____ Date: _____

Project:

**KWAHLOKOHLOKO SSA5:
PHASE 4 BULK
AUGMENTATION**


Drawing description:

**PACKAGE PLANT
DETAILS 02**


Drawn: G.D Bezuidenhout Date: Jul 2022

Scale/s: As Shown

Drawing number: Rev.:
22-032-V-PH4-03-05 **00**

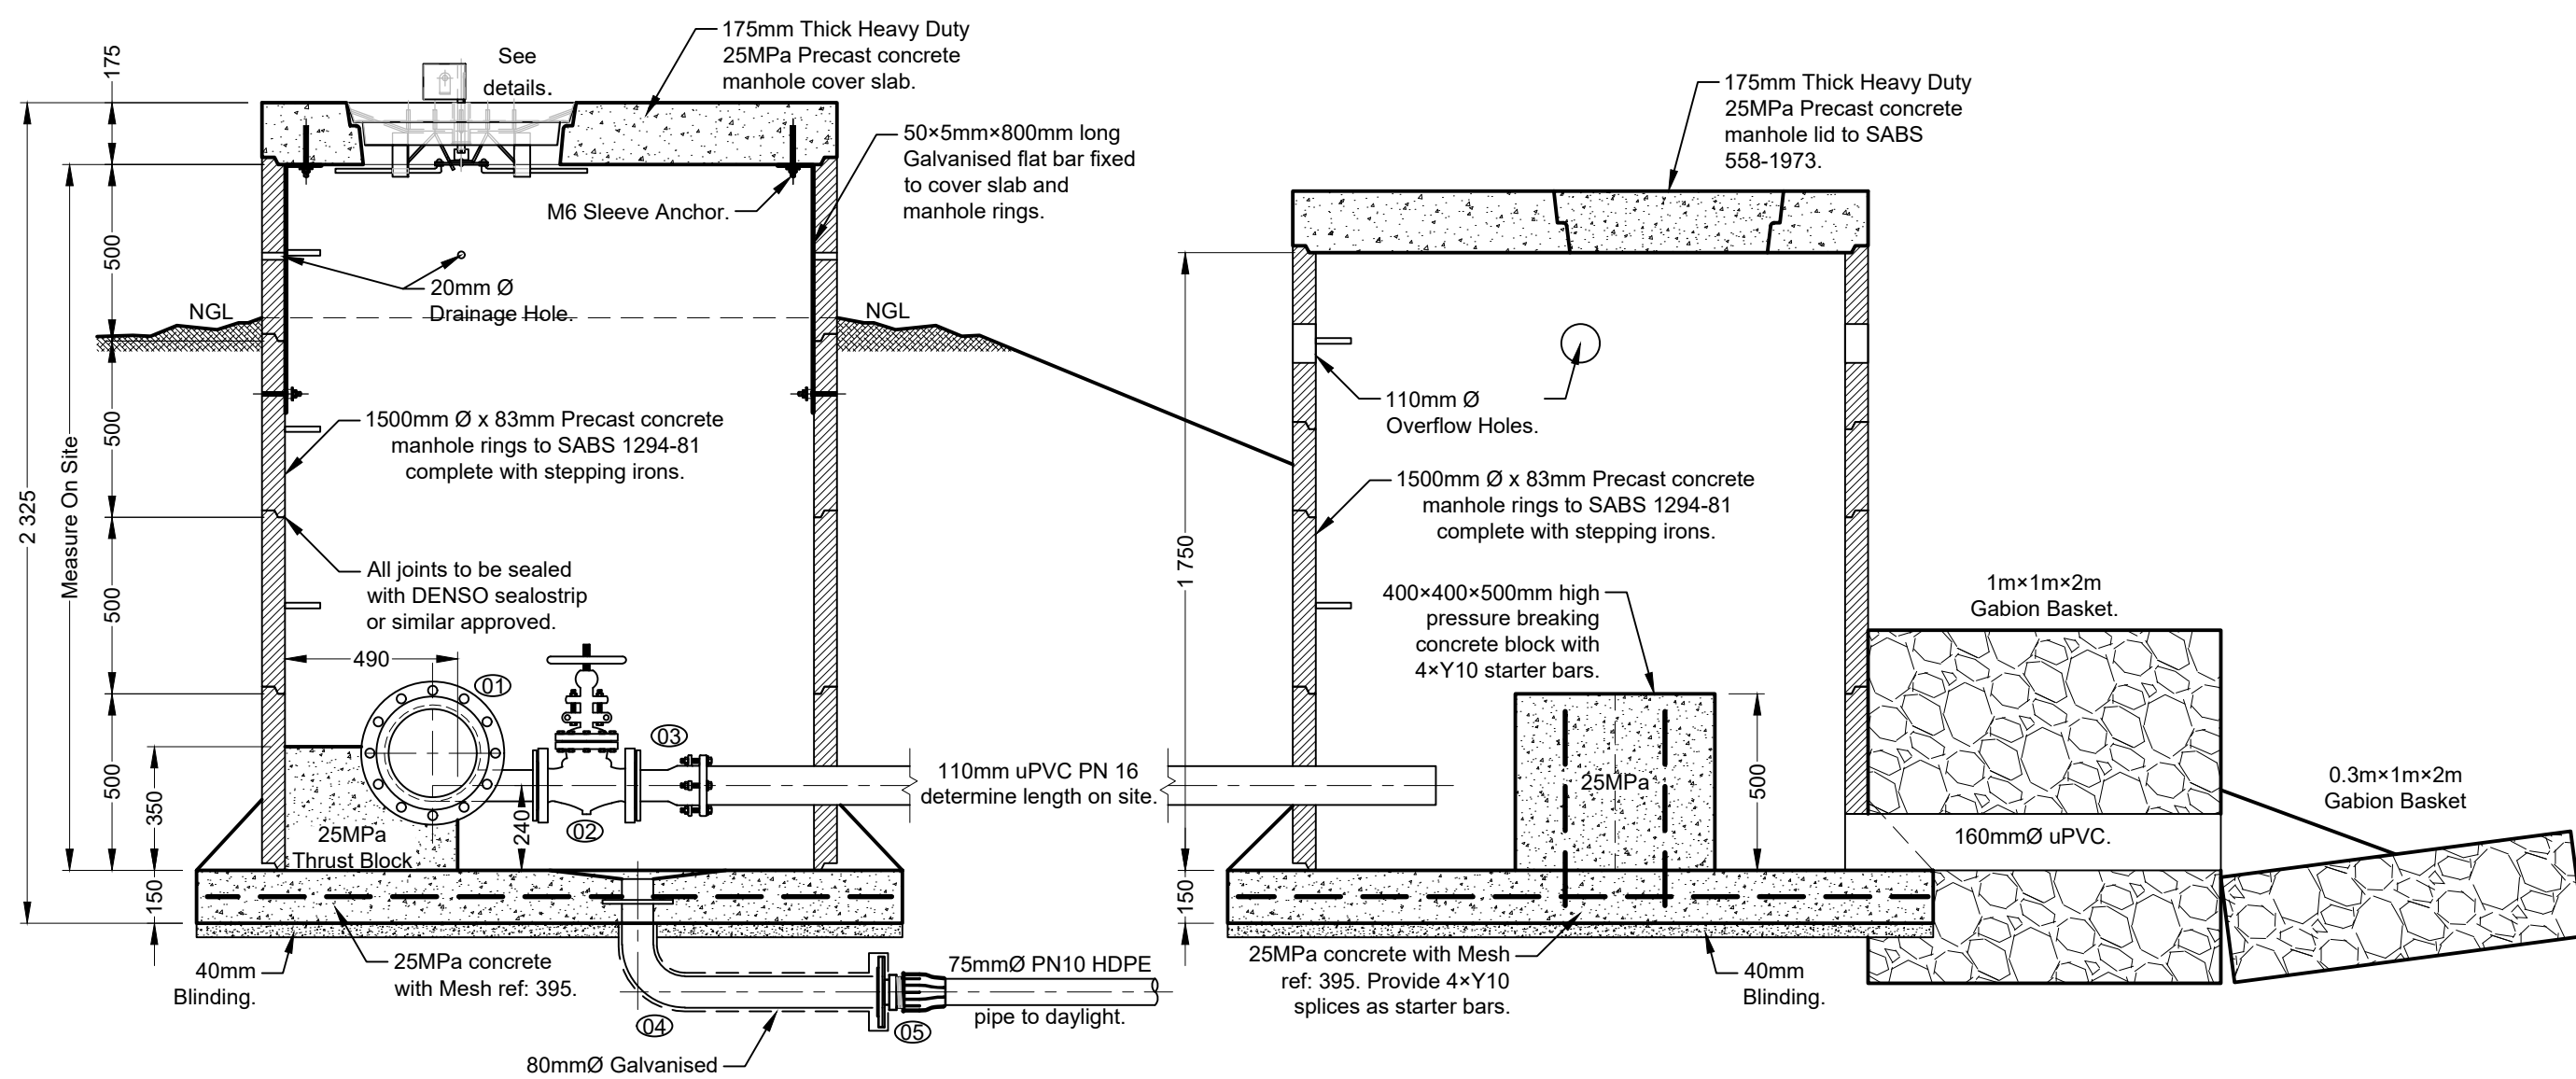

(S225:25) SCOUR CHAMBER SECTION
(25 BAR RATED)
Scale 1:20

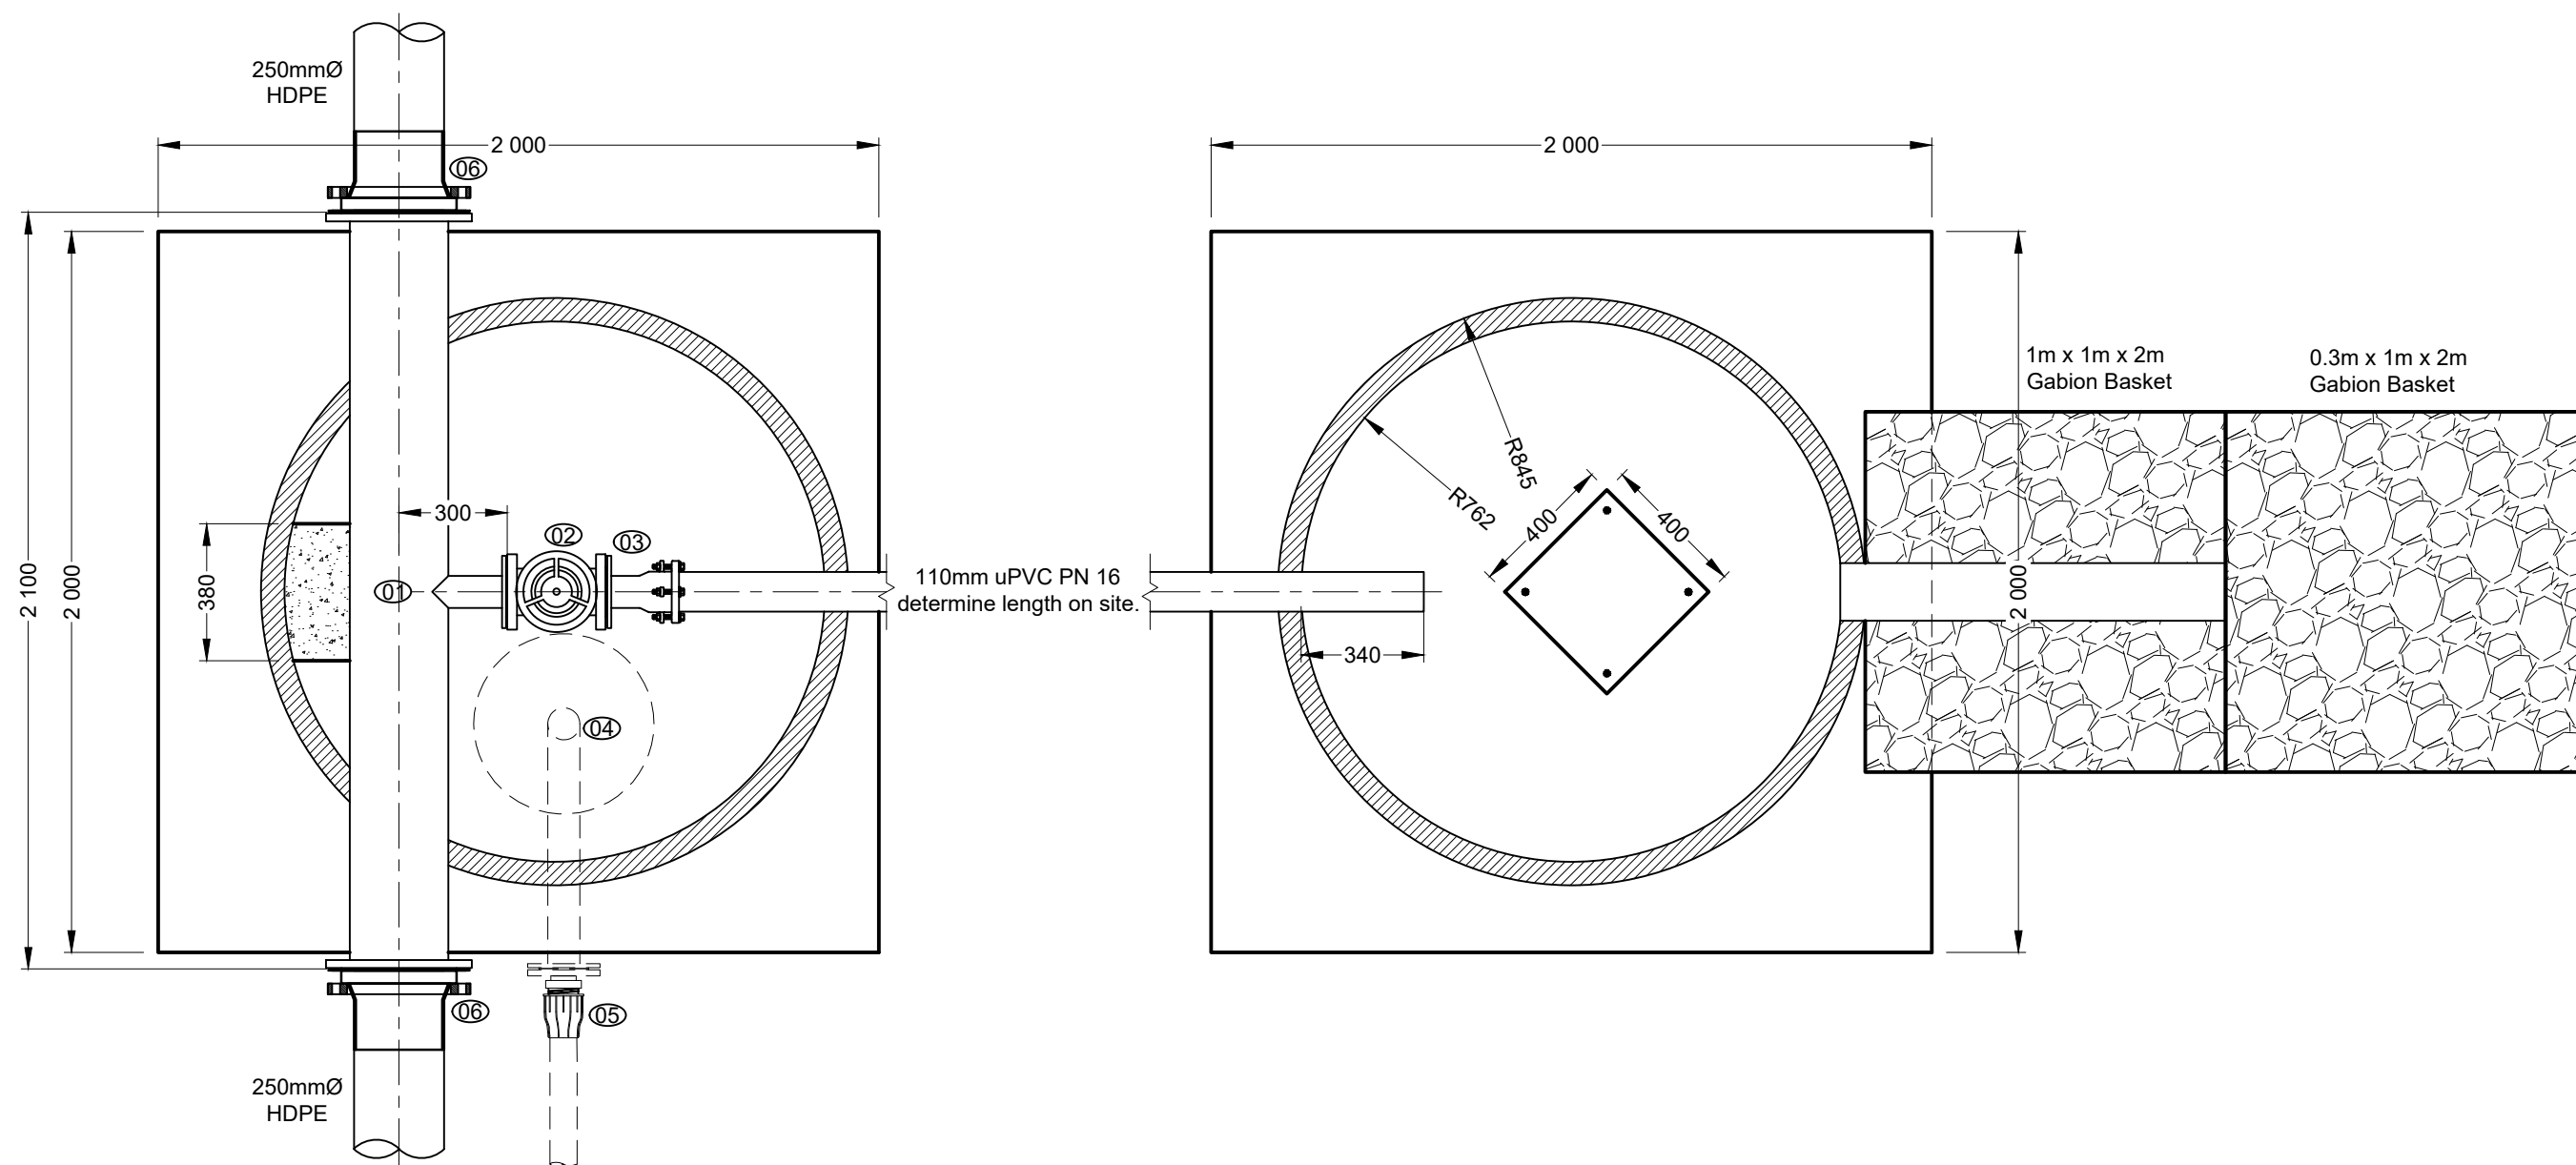


(S250:25) SCOUR VALVE CHAMBER PLAN
(25 BAR RATED)
Scale 1:20

A-250 FITTINGS (T16/25)

- 01 - 250mmØ Galvanized Steel straight pipe (600mm long) with 80mmØ branch (300mm long), T16/25 flanged.
02 - 80mmØ Straight pipe (600mm long), T16/25 flanged.

NOTE: ALL FITTINGS TO BE HOT DIPPED GALVANISED

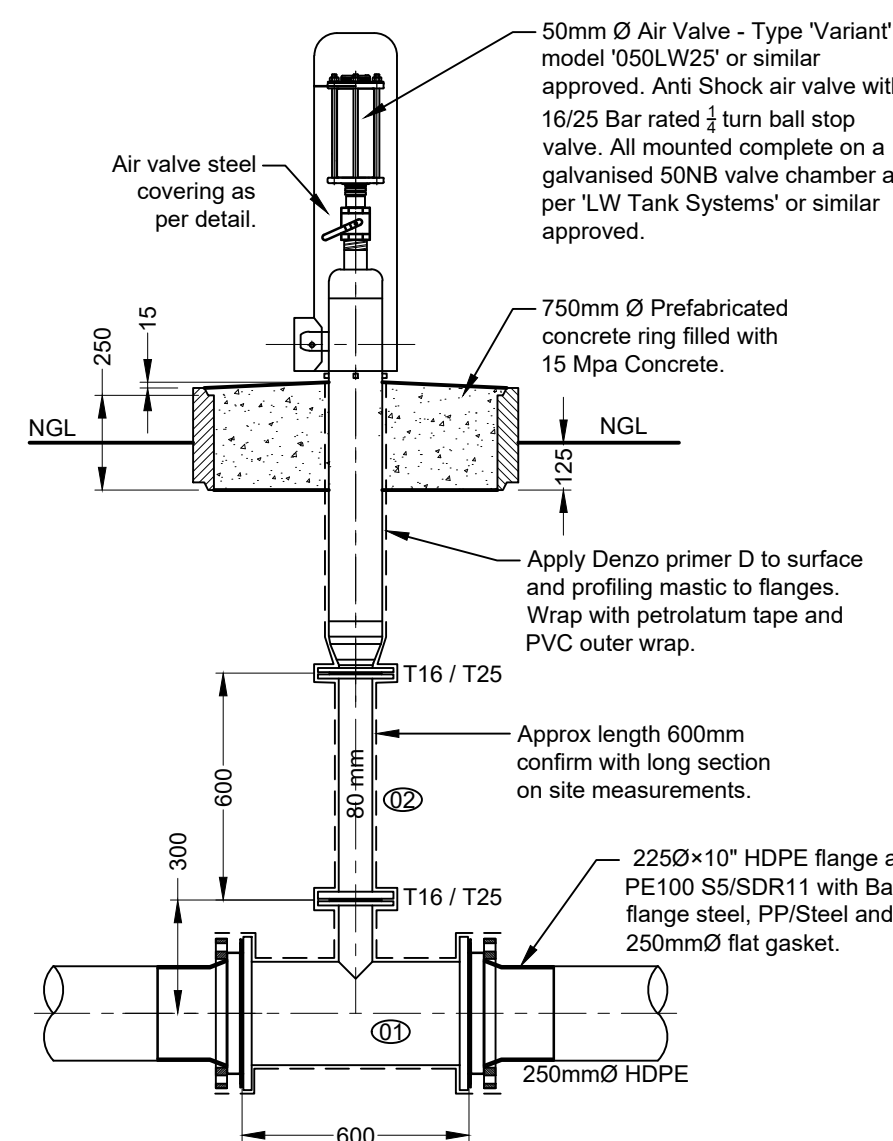


AIR VALVE DETAILS
(A-250)
Scale 1:20


A-225 FITTINGS (T16/25)

- 01 - 200mmØ Galvanized Steel straight pipe (600mm long) with 80mmØ branch (300mm long), T16/25 flanged.
02 - 80mmØ Straight pipe (600mm long), T16/25 flanged.

NOTE: ALL FITTINGS TO BE HOT DIPPED GALVANISED

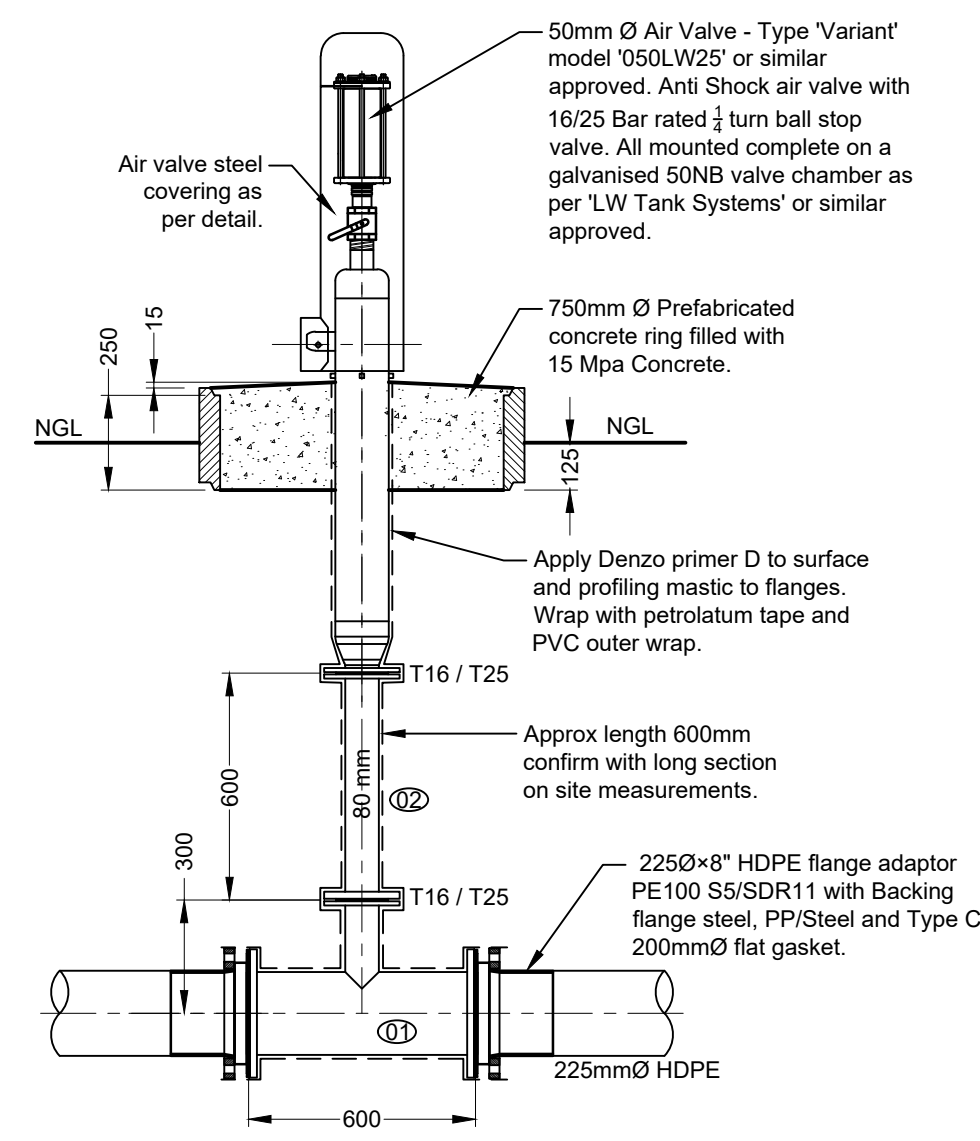

AIR VALVE DETAILS
(A-225)
Scale 1:20

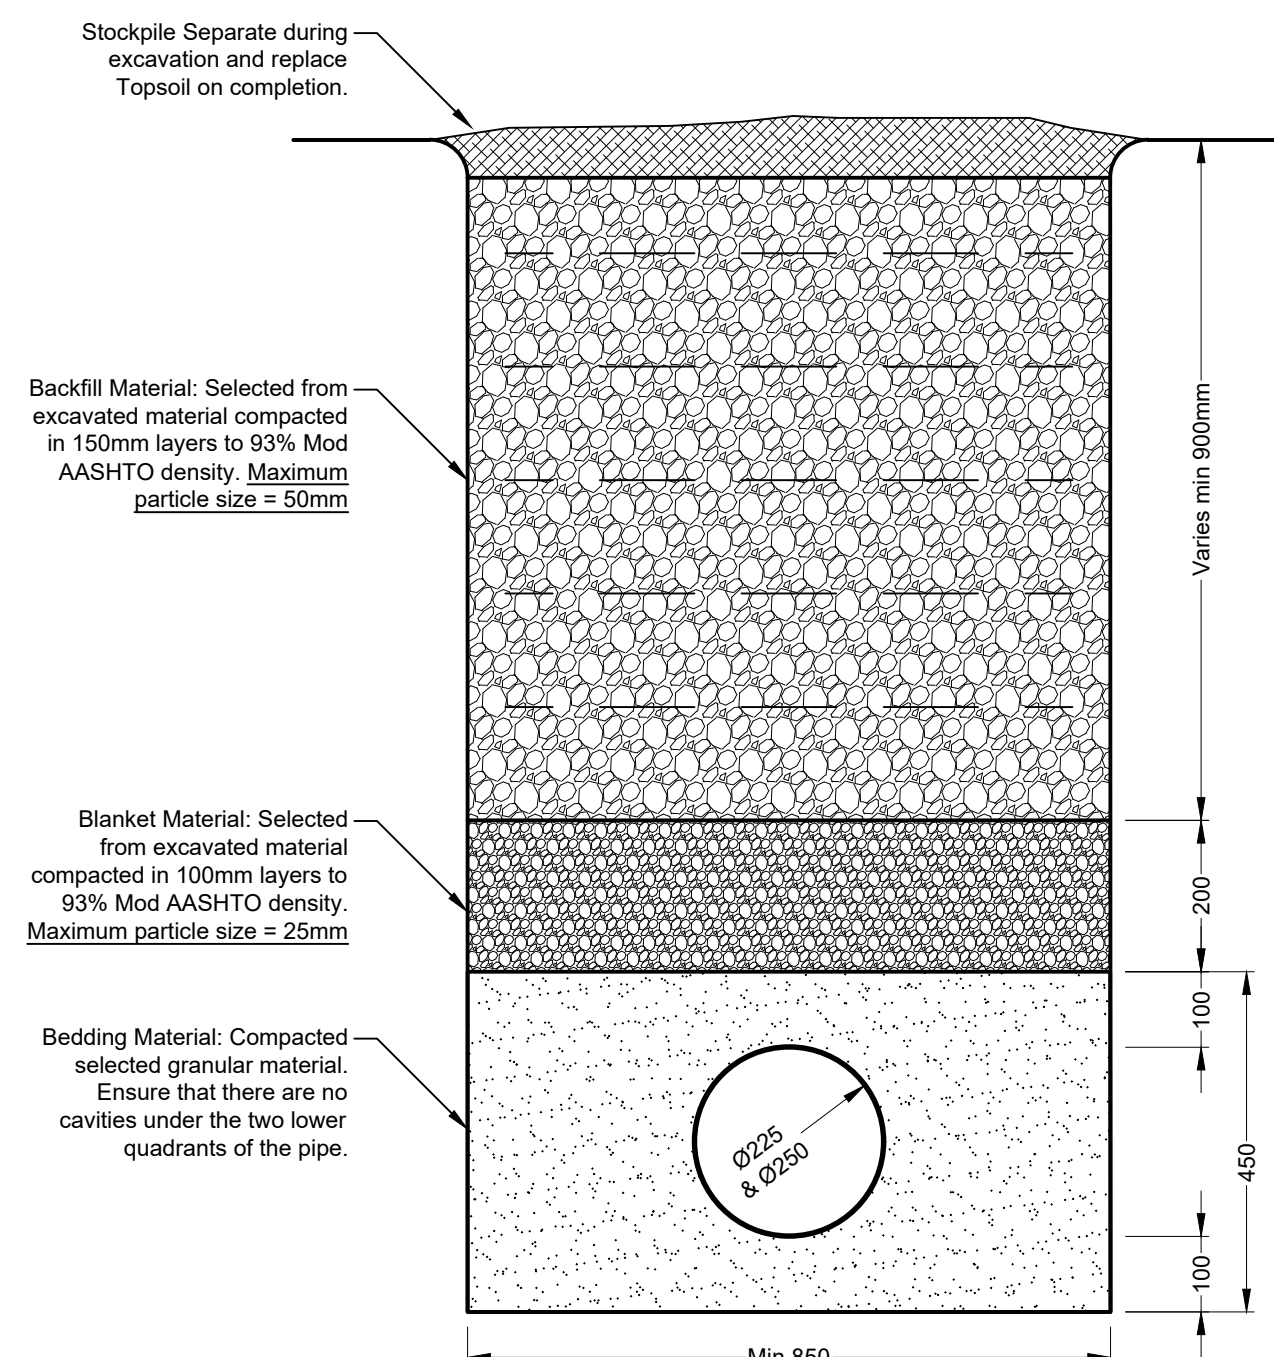

TRENCH DETAILS
Scale 1:10

Do not scale off drawing - ASK THE ENGINEER IF UNCERTAIN!
Any discrepancies between any drawings must be clarified before work is continued on site.

FOR TENDER PURPOSES ONLY

READ THIS DRAWING IN CONJUNCTION WITH

Drawing Number	Drawing Description

AMENDMENTS

Rev.	Date	Description

ECA CONSULTING VRYHEID OFFICE:
161 High Street | Vryheid | Kwa Zulu Natal | RSA
vryheid@ecaconsult.co.za
Tel: +27 (0)34 983 2825
www.ecaconsult.co.za
Civil and Structural Engineers
Company Reg.: 2004/019299/07
ISO Registered 9001:2015
OTHER OFFICES:
MBOMBELA | GAUTENG | PIETERMARITZBURG | LADYSMITH

Approved by Engineer: J.W. Janse v Rensburg
Designation: PrTechEng
ECSA Reg.: 201070143
Signature: _____
Date: 27 Oct 2022

Project Funder/ Client:
mig Municipal Infrastructure Grant


Project Implementing Agent:
KING CETSHWAYO DISTRICT MUNICIPALITY

Approved by Client: _____
Name: _____
Signature: _____ Date: _____


Project:
KWAHLOKOHLOKO SSA5: PHASE 4 BULK AUGMENTATION

Drawing description:
250mm HDPE GENERAL DETAILS


Drawn: G.D Bezuidenhout Date: Jul 2022
Scale/s: As Shown
Drawing number: 22-032-V-PH4-04-01 Rev.: 00

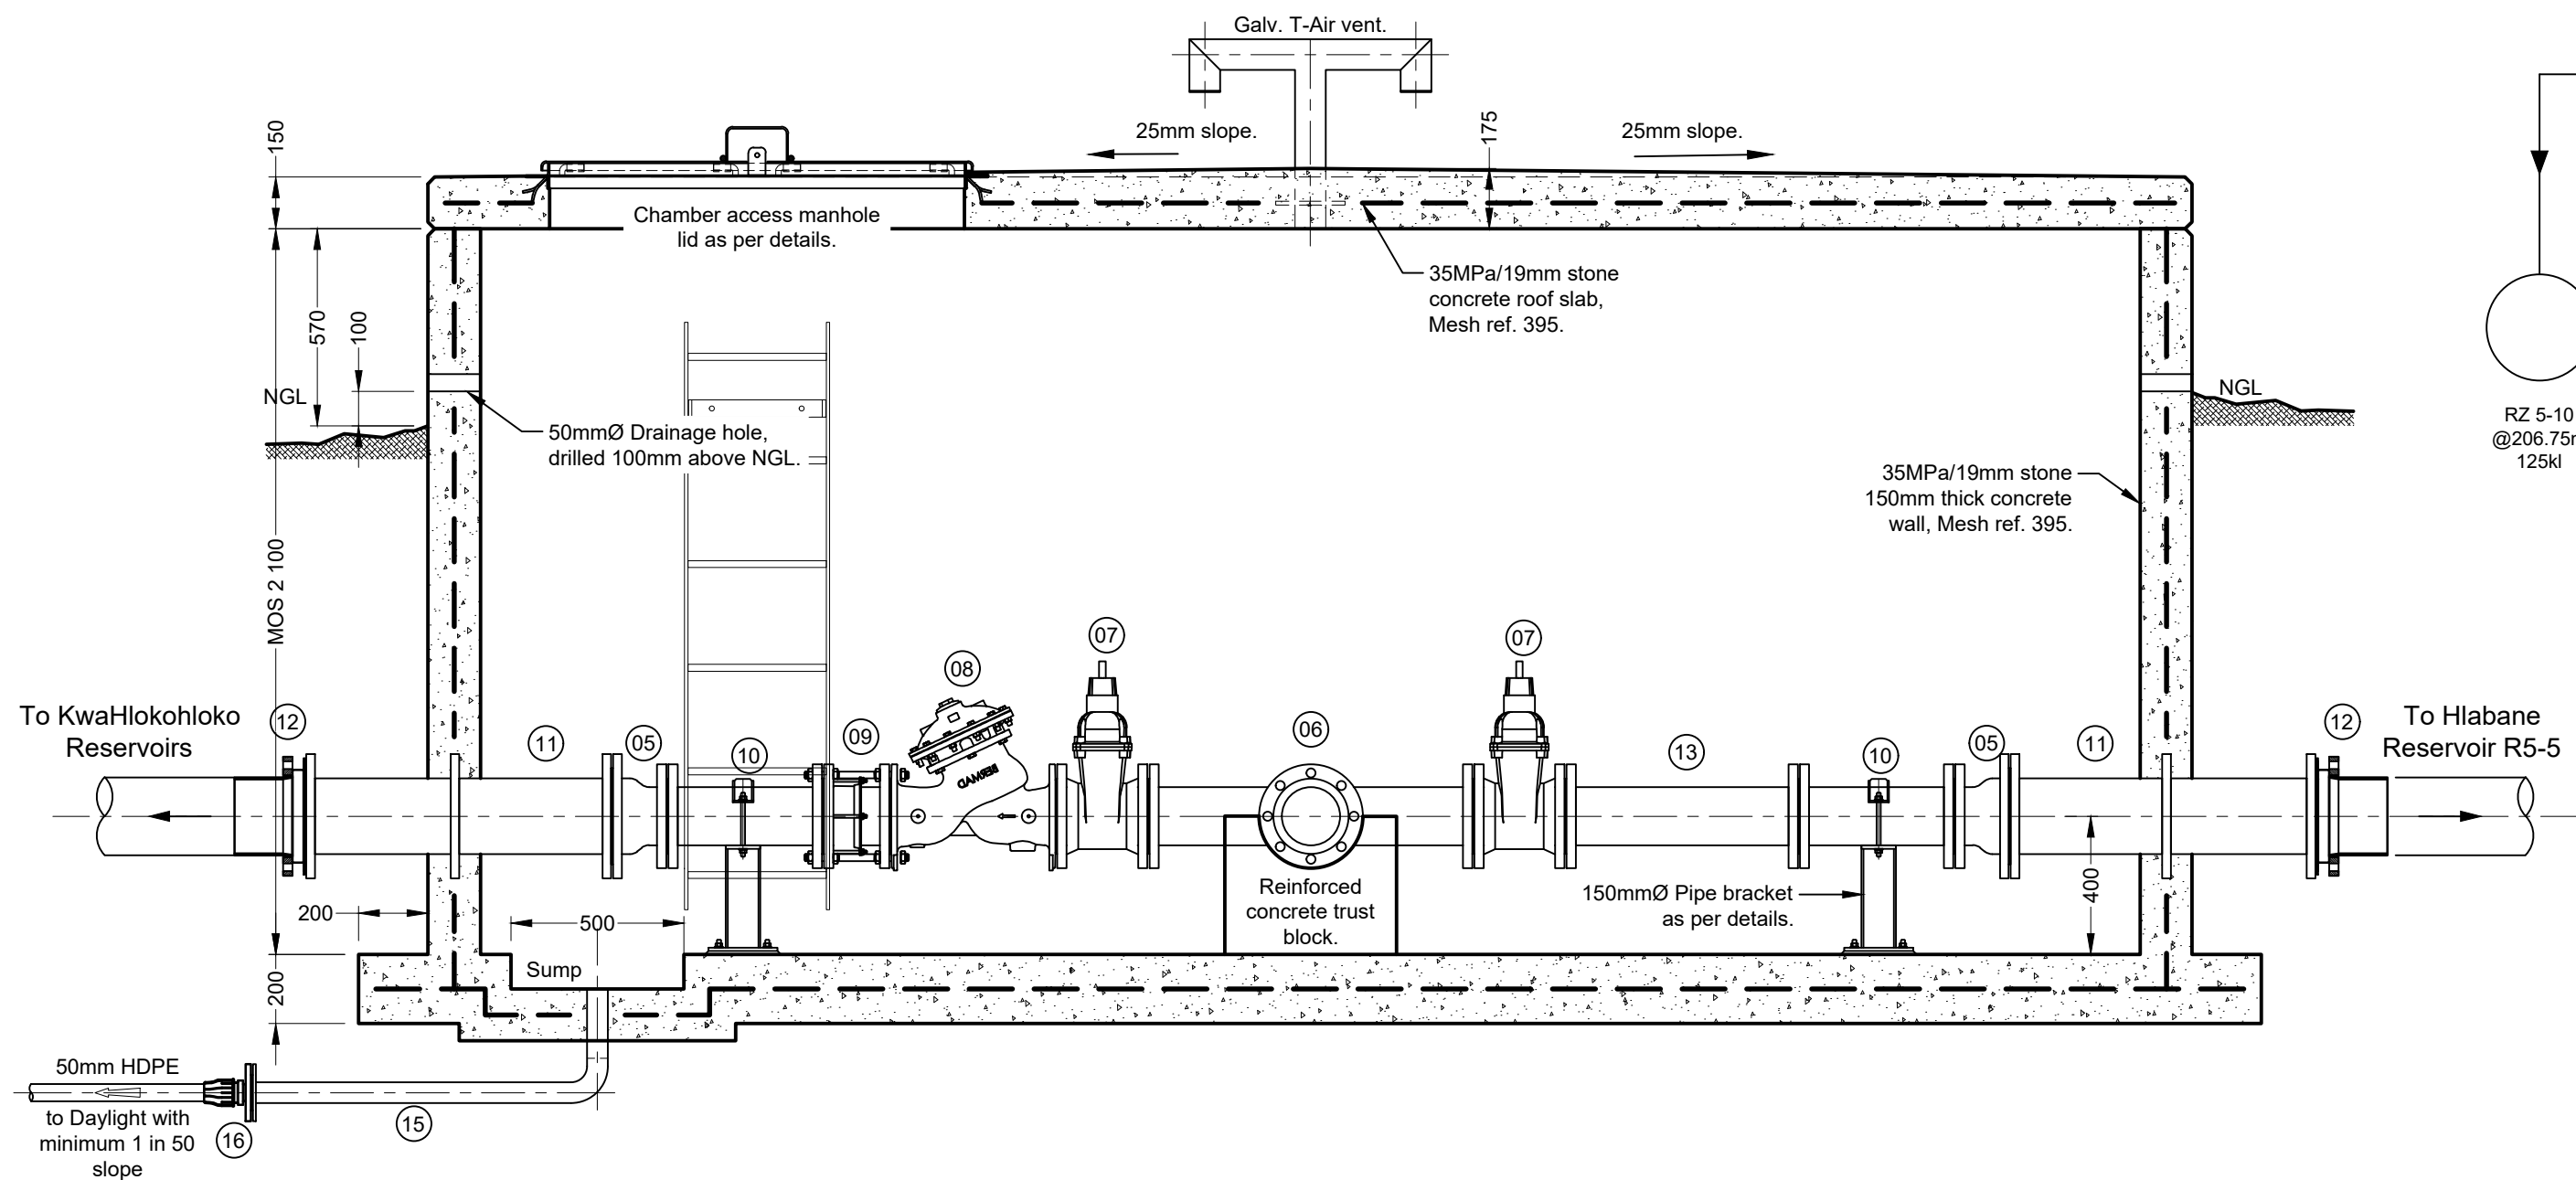

SECTION 4A-4A
Scale 1:20

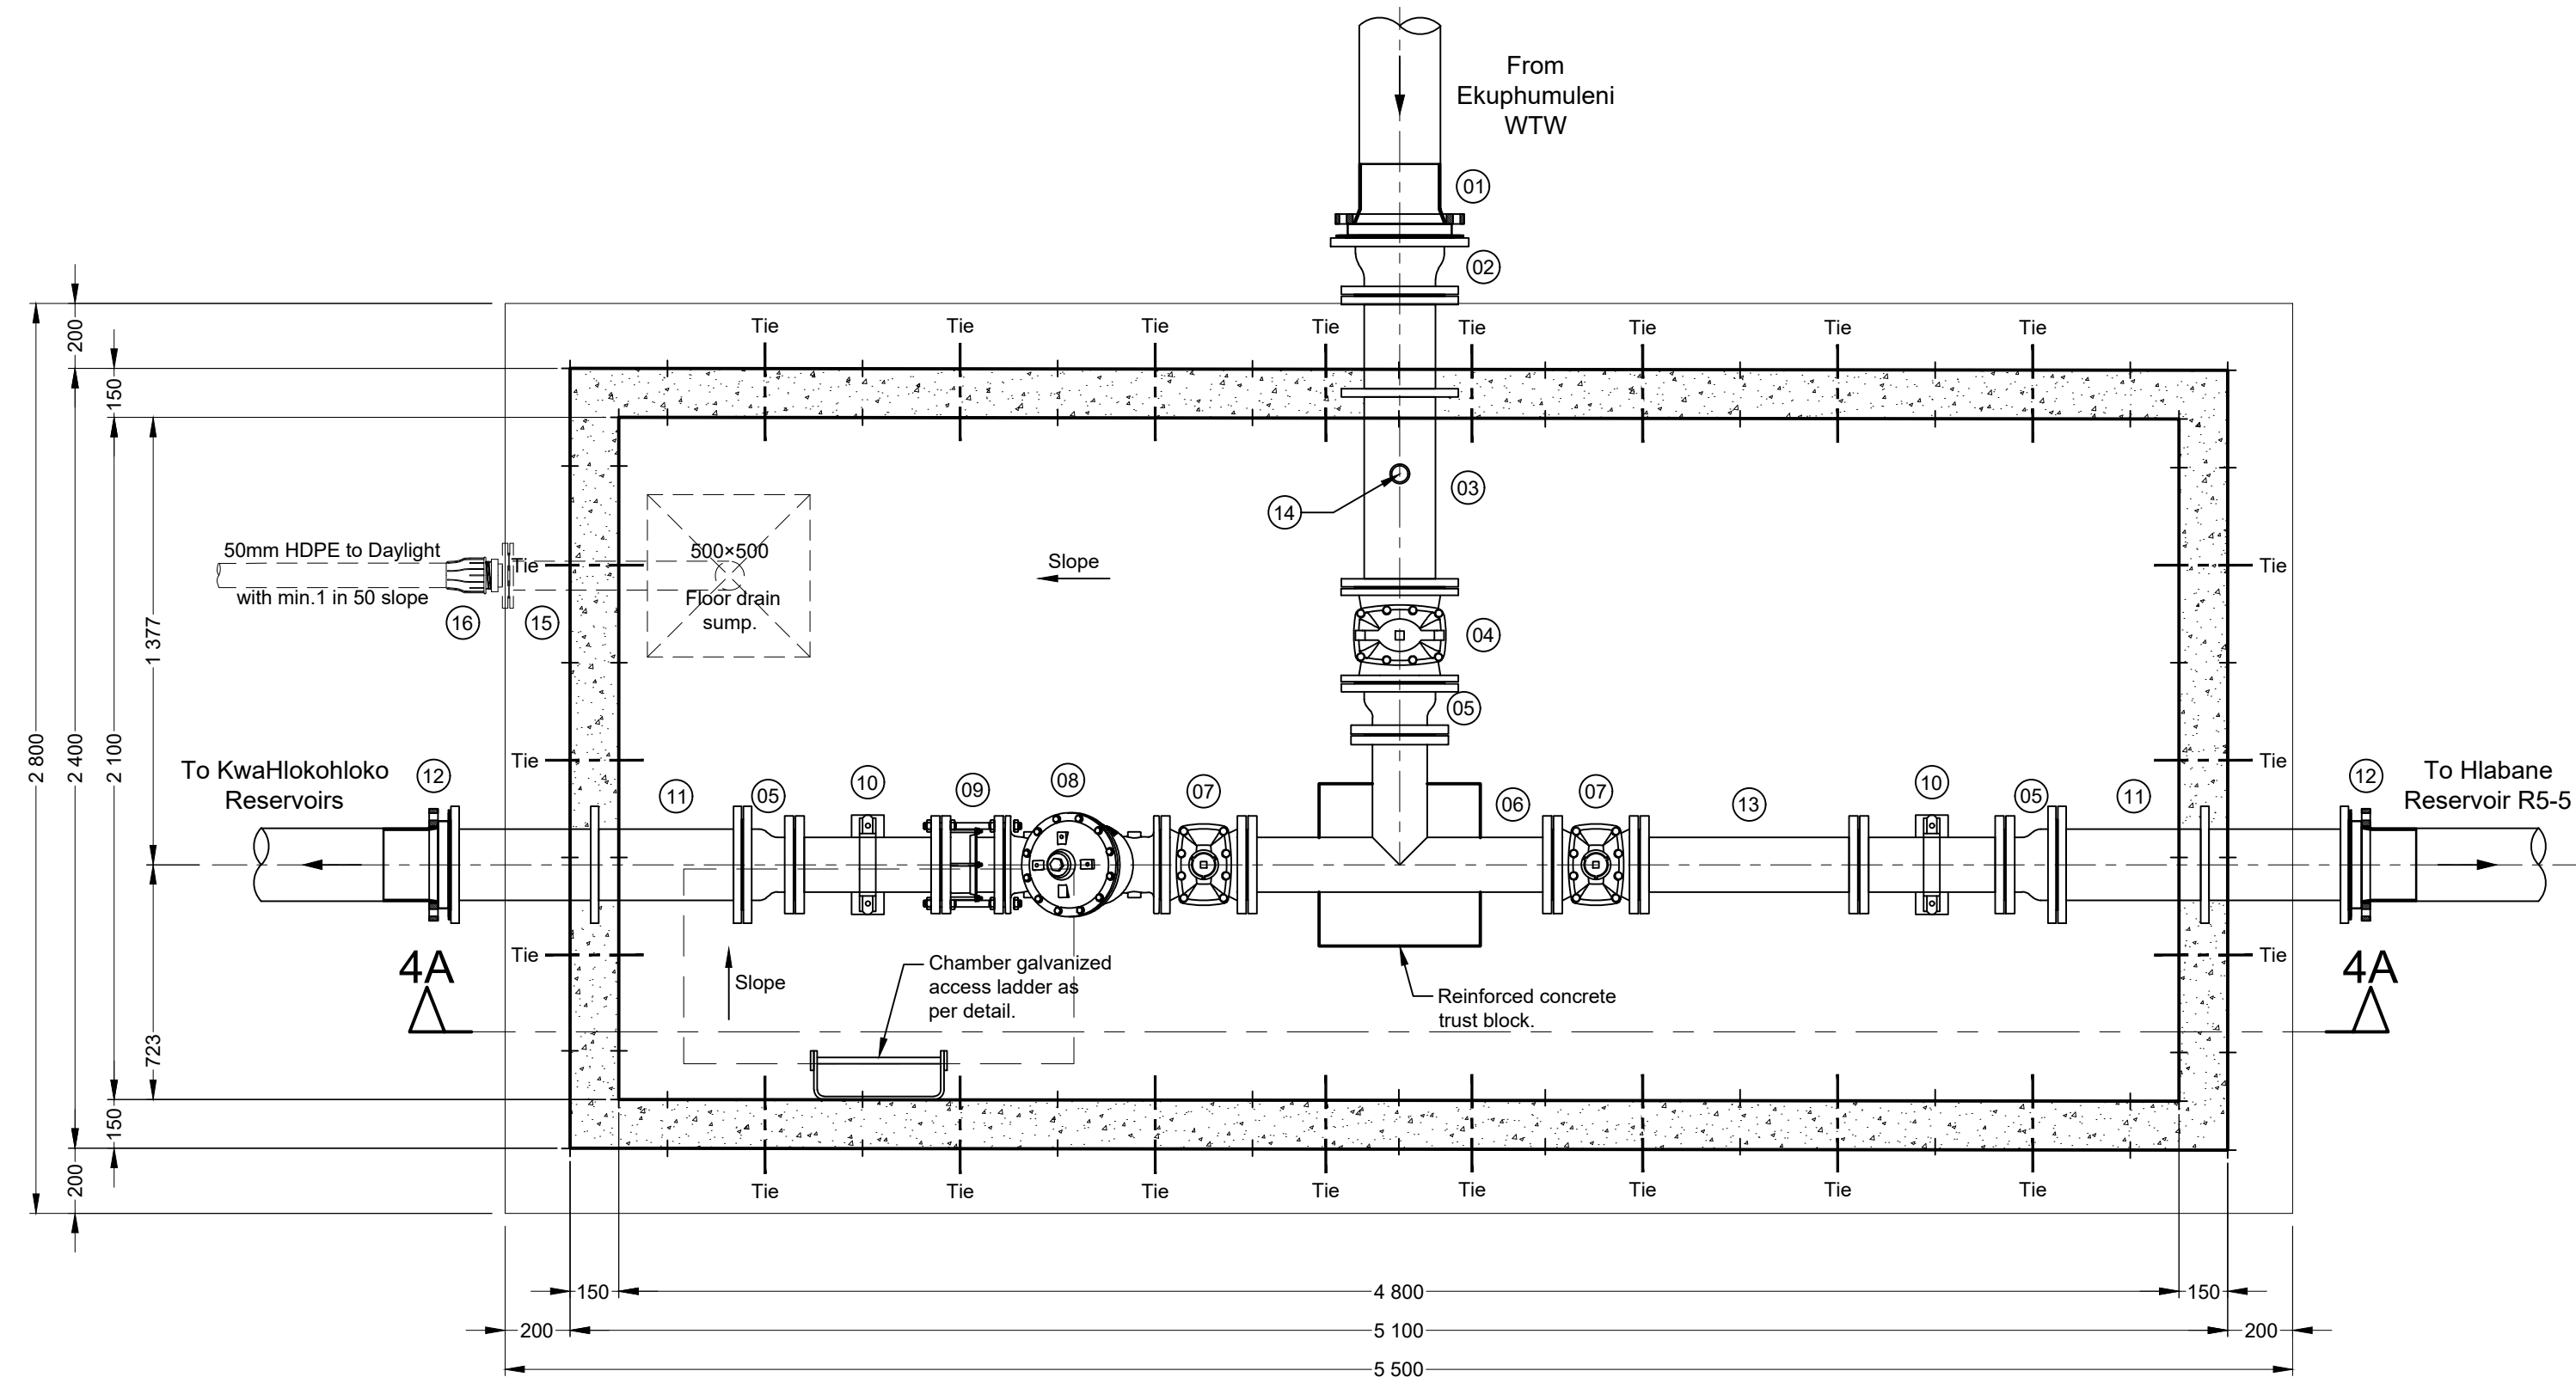

250-225 TIE-IN / TEE OFF CHAMBER PLAN
Scale 1:20

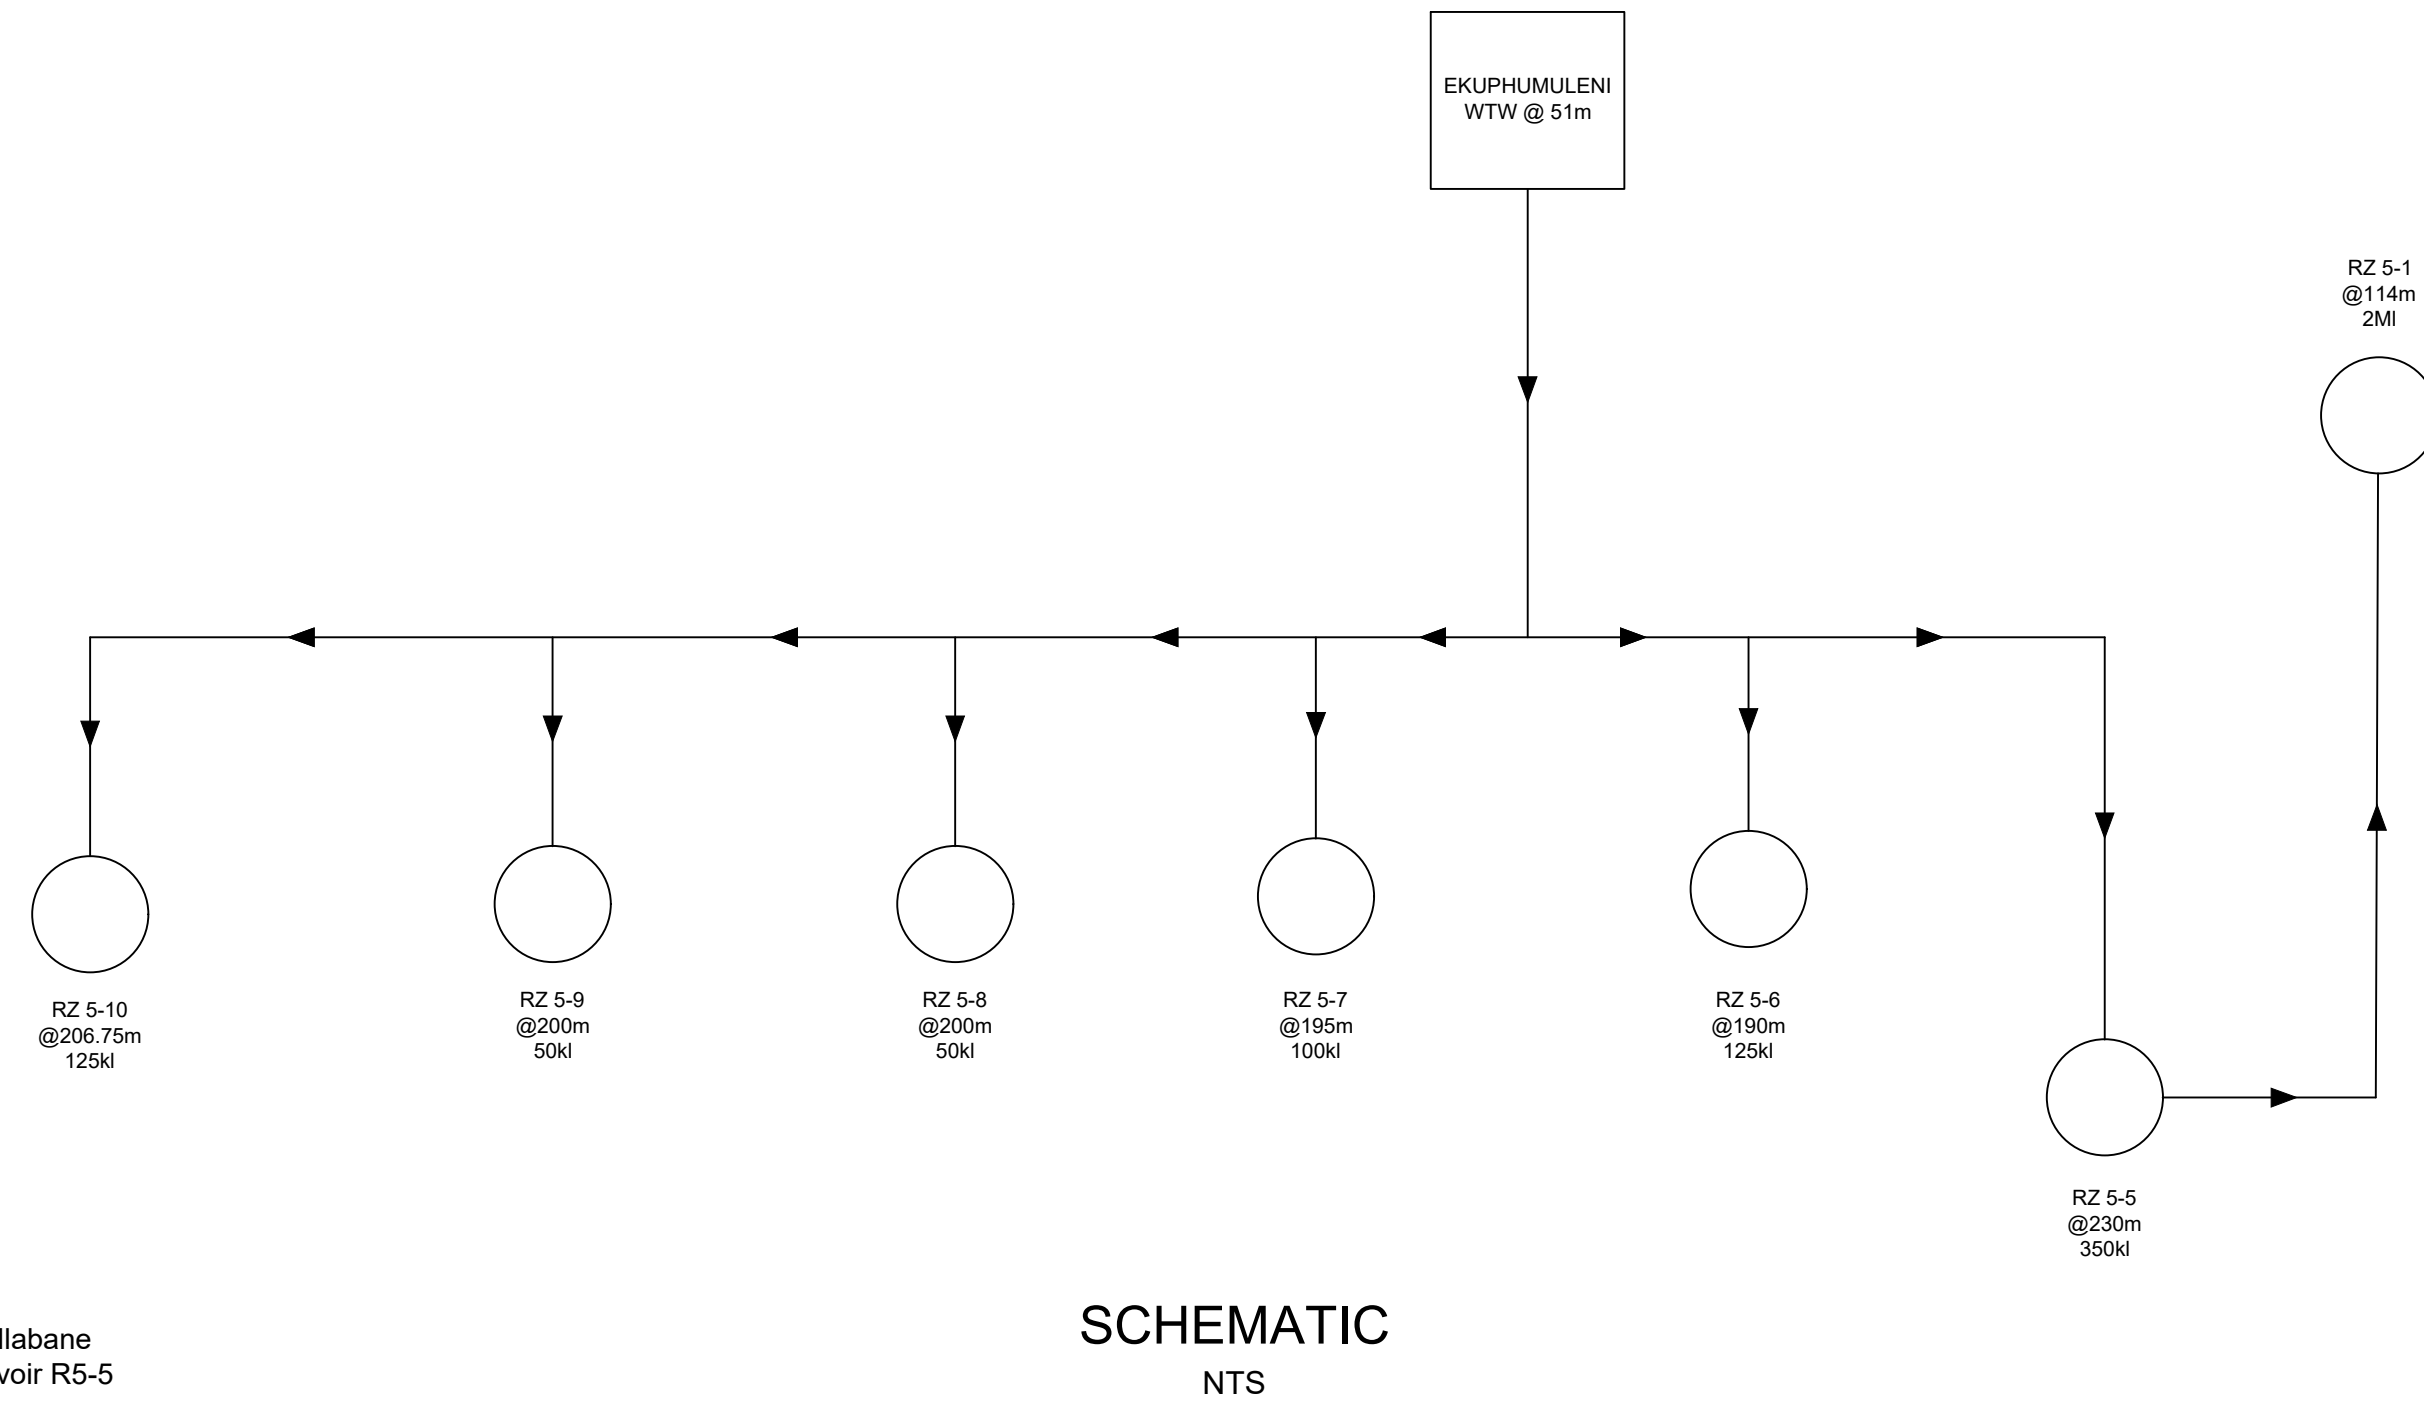

SCHEMATIC
NTS

NEW TIE IN CHAMBER FITTINGS

- 01 - 250Ø×10" HDPE flange adaptor PE100 S5/SDR11 with Backing flange steel, PP/Steel and Type C 250mmØ flat gasket.
- 02 - 250mmØ - 200mmØ reducer, T25 flanged.
- 03 - 200mmØ Straight (900mm long) with puddle flange, 50mmØ steam socket, T25 flanged.
- 04 - 200mmØ RS Gate Valve to SANS 664, T25 flanged or similar approved.
- 05 - 200mmØ - 150mmØ reducer, T25 flanged.
- 06 - 150mmØ Straight (940mm long) with 150mmØ Tee (400mm long), T25 flanged.
- 07 - 150mmØ RS Gate Valve to SANS 664, T25 flanged or similar approved.
- 08 - 150mmØ 'Bermaid, Model No. WW-6"-773-50, Y-C-25-EB-NN-UVNT Level control valve, T25 flanged.
- 09 - 150mmØ dismantling joint, T25 flanged.
- 10 - 150mmØ Straight (450mm long), T25 flanged.
- 11 - 200mmØ Straight (900mm long) with puddle flange, T25 flanged.
- 12 - 225Ø×8" HDPE flange adaptor PE100 S5/SDR11 with Backing flange steel, PP/Steel and Type C 200mmØ flat gasket.
- 13 - 150mmØ Straight (675mm long), T25 flanged.
- 14 - 50mm Variant air valve, model: 050LW25 with 50mmØ turn ball cock valve and 1000mm long male threaded extension pipe or similar approved. Fixed with 50mmØ HILTI Light fixed point pipe ring.
- 15 - 50Ø Straight with 90° bend, 1×T16 flange.
- 16 - 50Ø HDPE T16 flange adaptor.

NOTE: ALL FITTINGS TO BE HOT DIPPED GALVANISED

Do not scale off drawing - ASK THE ENGINEER IF UNCERTAIN!
Any discrepancies between any drawings must be clarified before work is continued on site.

FOR TENDER
PURPOSES ONLY

READ THIS DRAWING IN CONJUNCTION WITH

Drawing Number	Drawing Description

AMENDMENTS

Rev.	Date	Description

ECA CONSULTING VRYHEID
OFFICE:
161 High Street |
Vryheid | Kwa Zulu Natal |
RSA
vryheid@ecaconsult.co.za
Tel: +27 (0)34 983 2825
www.ecaconsult.co.za
Civil and Structural Engineers
Company Reg.: 2004/019299/07
ISO Registered 9001:2015
OTHER OFFICES:
MBOMBELA | GAUTENG |
PIETERMARITZBURG |
LADYSMITH

Approved by Engineer: Signature:
Name: J.W. Janse v Rensburg
Designation: PrTechEng
ECSA Reg.: 201070143 Date: 27 Oct 2022

Project Funder/ Client:
mig Municipal Infrastructure Grant


Project Implementing Agent:
KING CETSHWAYO DISTRICT MUNICIPALITY

Approved by Client:
Name: _____
Signature: _____ Date: _____


Project:
KWAHLOKOHEKO SSA5: PHASE 4 BULK AUGMENTATION

Drawing description:
NEW TIE IN CHAMBER DETAILS


Drawn: G.D Bezuidenhout Date: Jul 2022
Scale/s: As Shown
Drawing number: 22-032-V-PH4-04-02 Rev.: 00

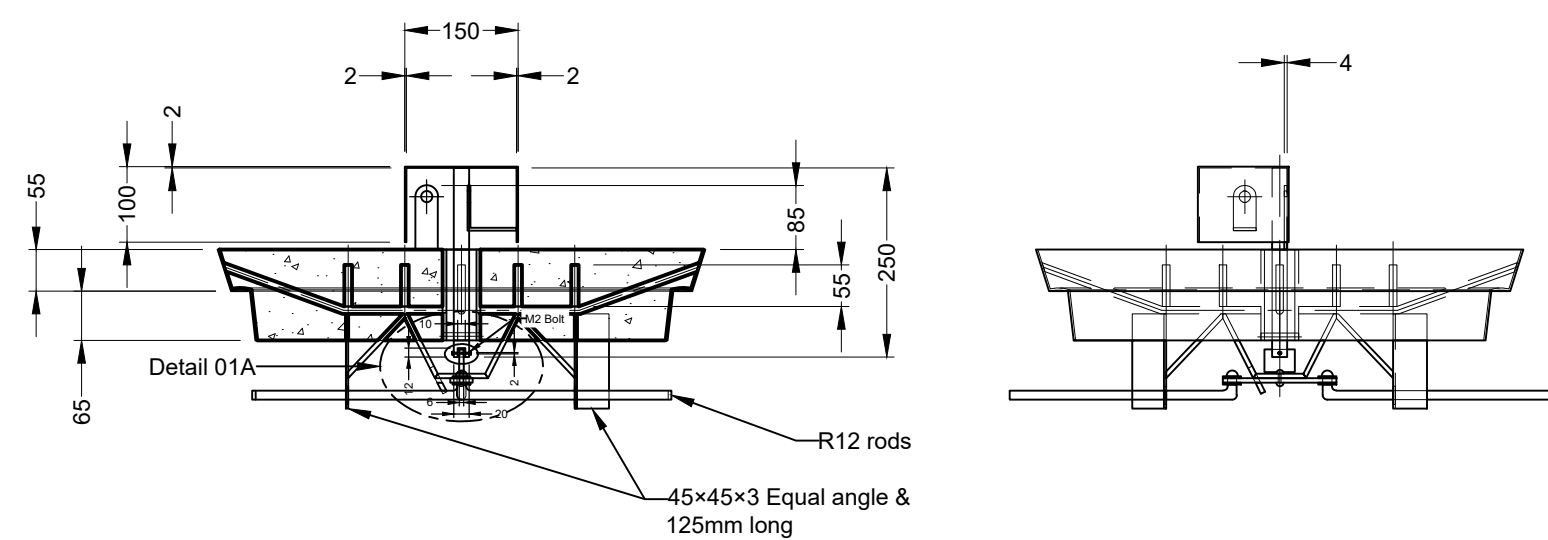


LOCKABLE / GALVANISED & CONCRETE FILLED CHAMBER LID DETAILS
Scale 1:10

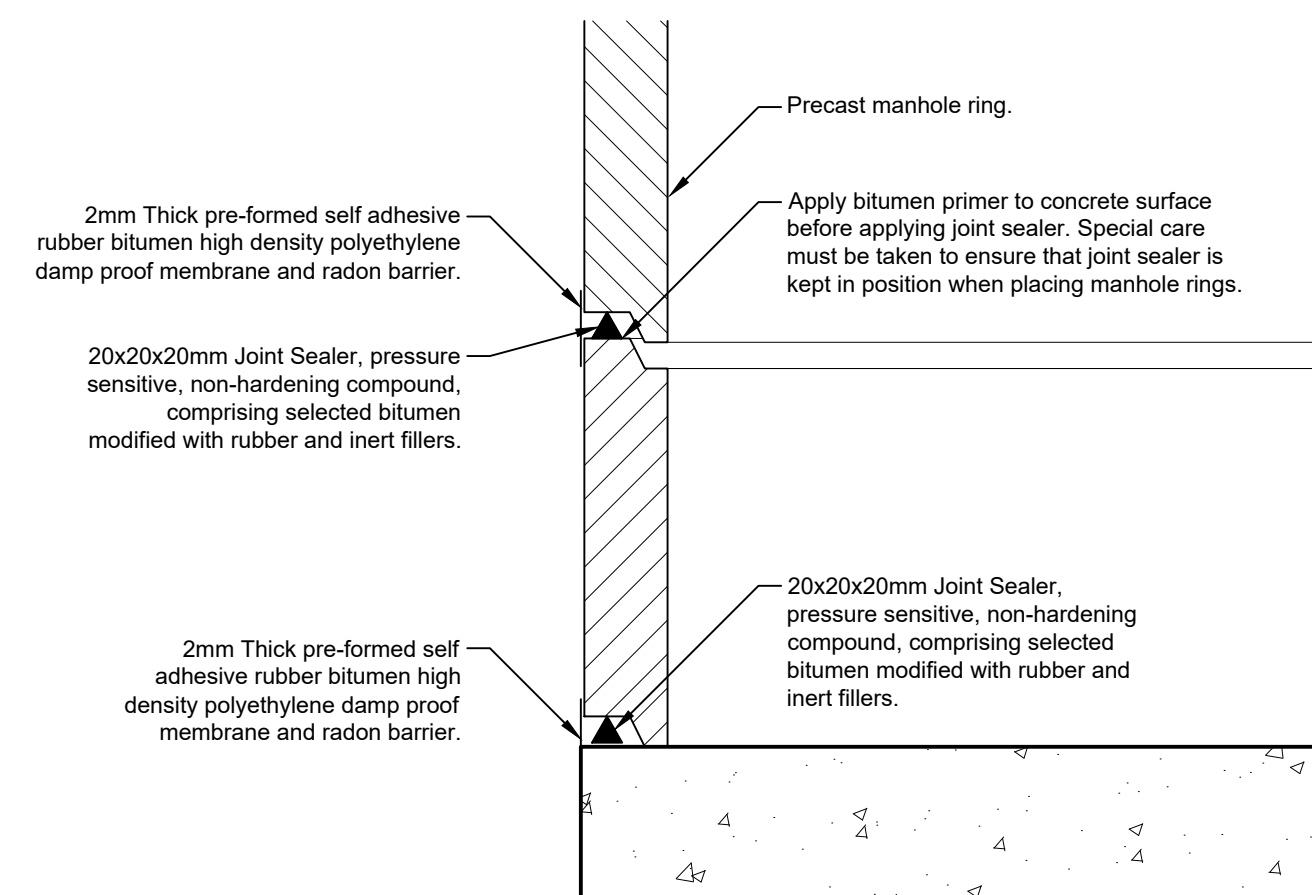


TYPICAL MANHOLE SEALING DETAIL
Scale 1:5

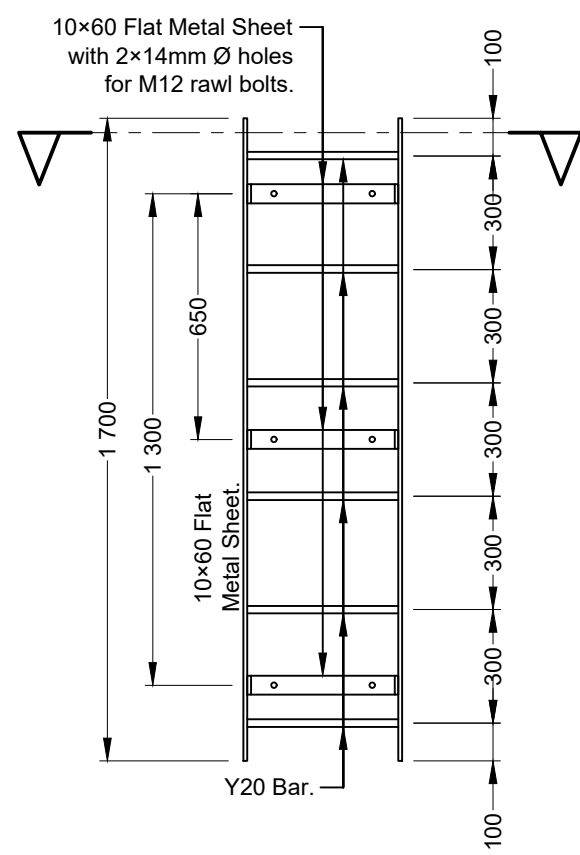


CHAMBER GALVANISED
ACCESS LADDER DETAIL
Scale 1:20

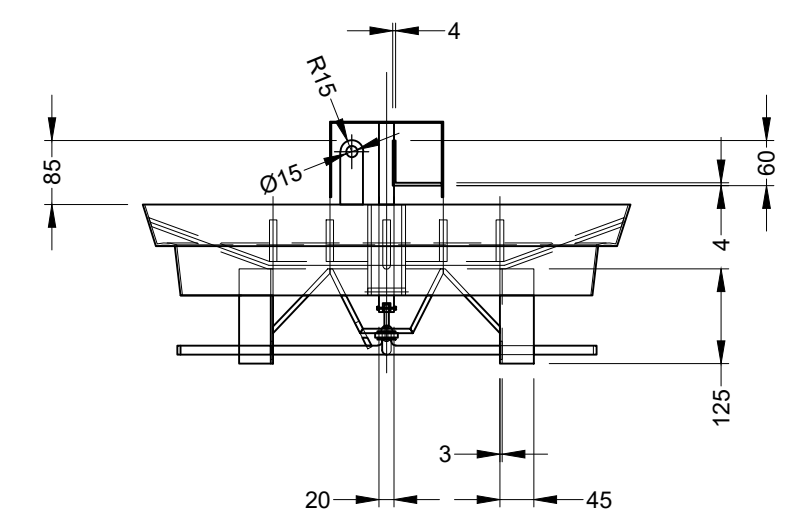


AIR VALVE COVER DETAILS
Scale 1:10

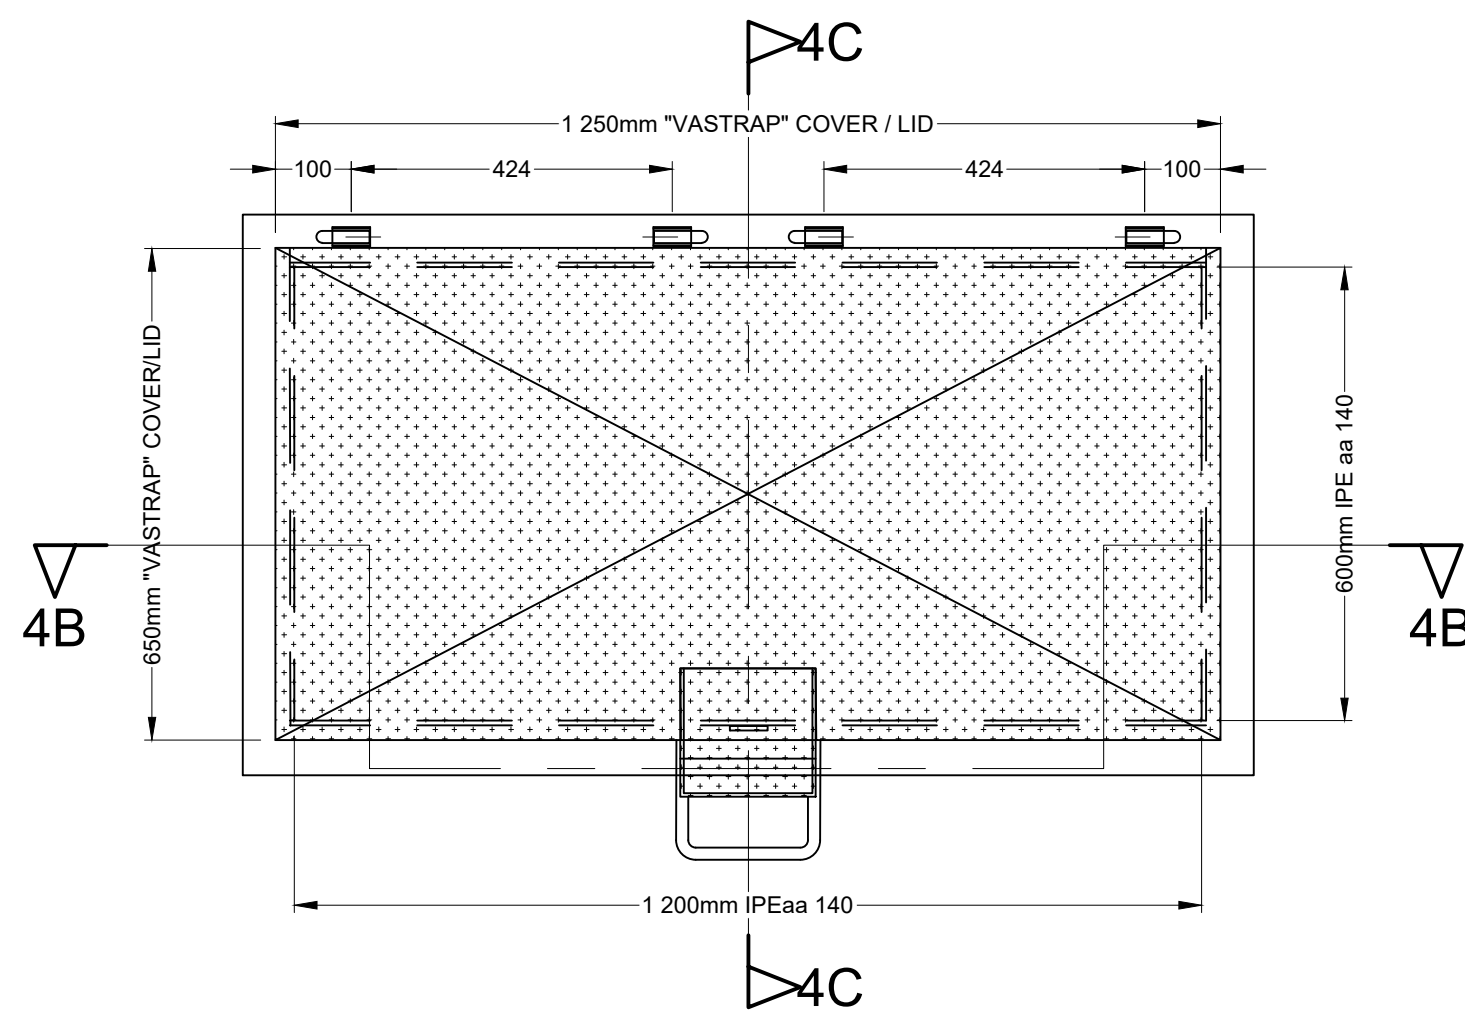


CHAMBER ACCESS MANHOLE
Scale 1:10

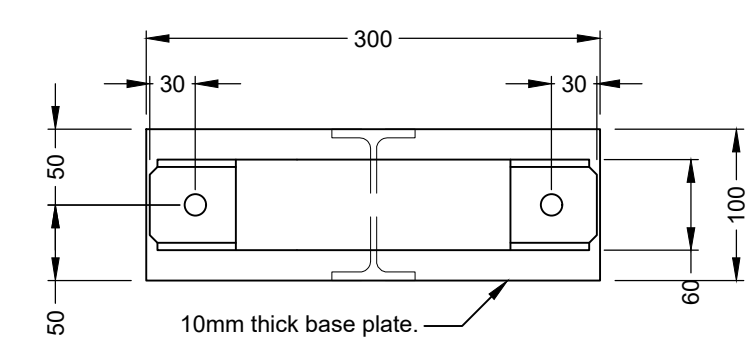


150mmØ PIPE BRACKET PLAN
Scale 1:5

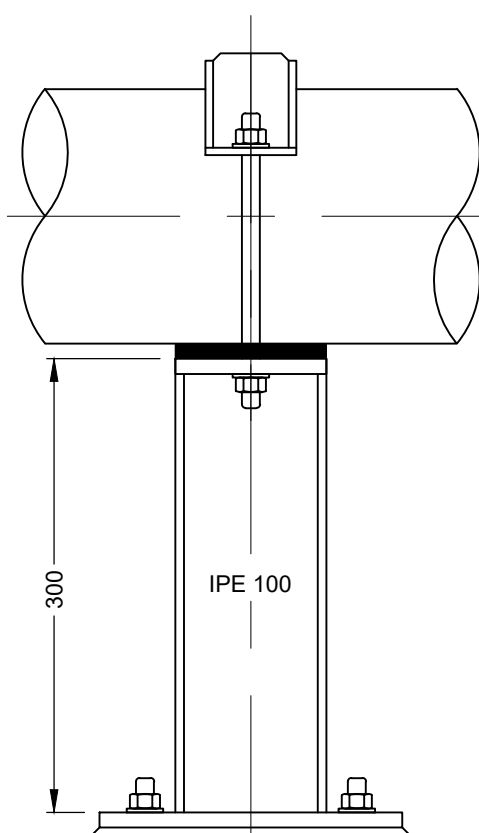


150mmØ PIPE BRACKET
ELEVATION
Scale 1:5

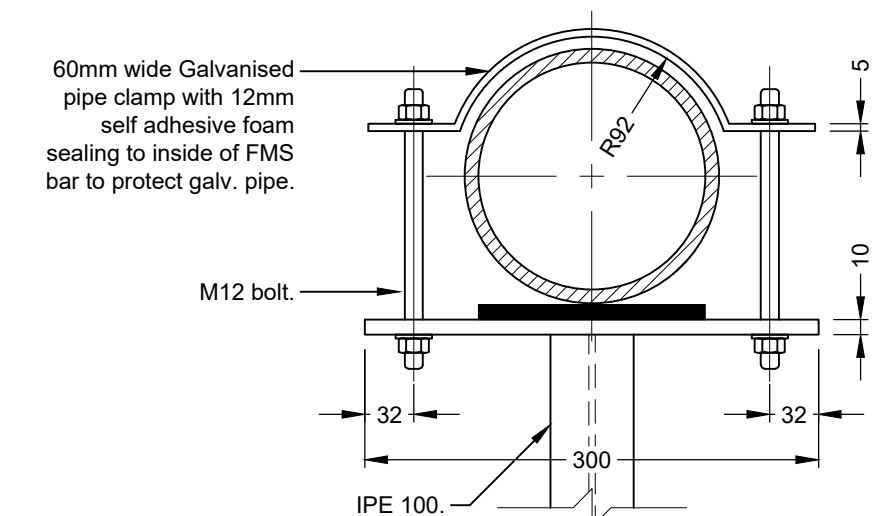


150mmØ PIPE BRACKET DETAILS
Scale 1:5

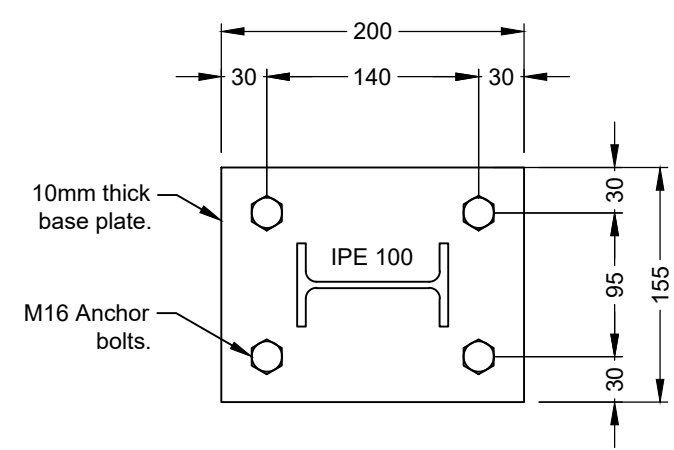


PIPE BRACKETS BASE
PLATE
Scale 1:5

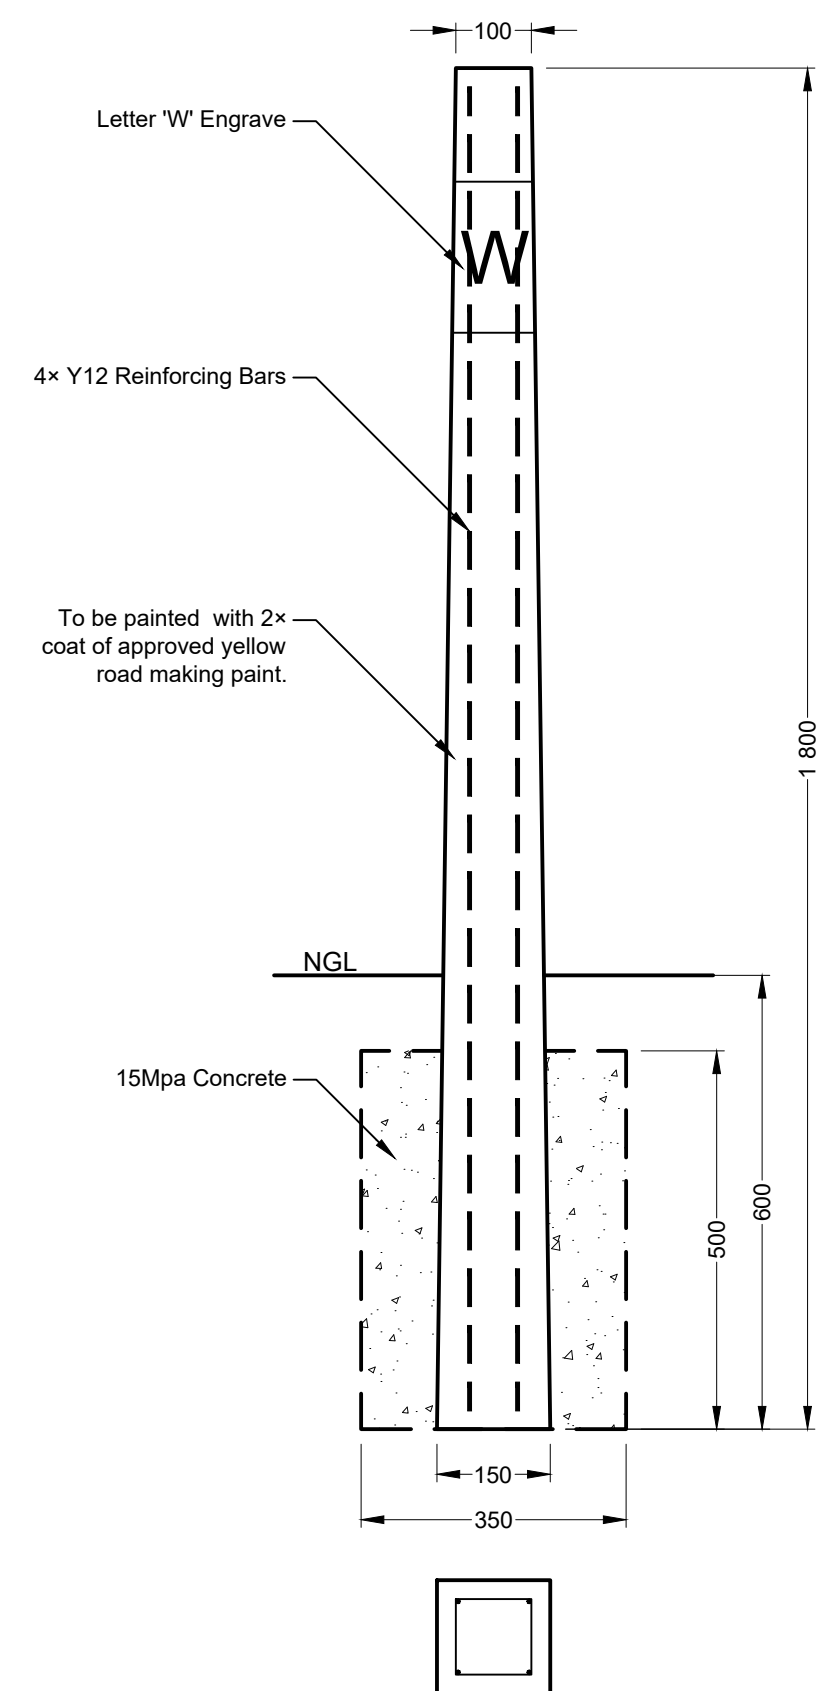

WATER MARKER DETAIL
Scale 1:10

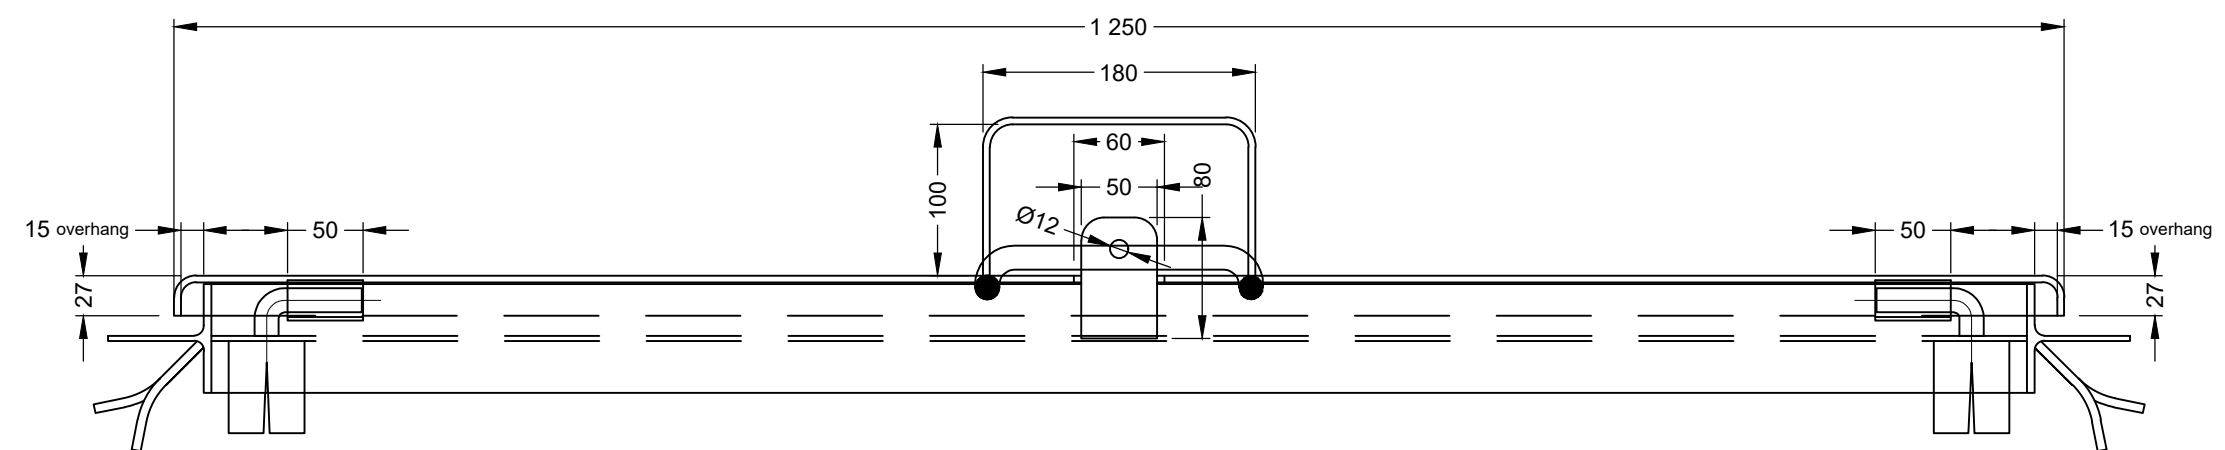

SECTION 4B-4B
Scale 1:5

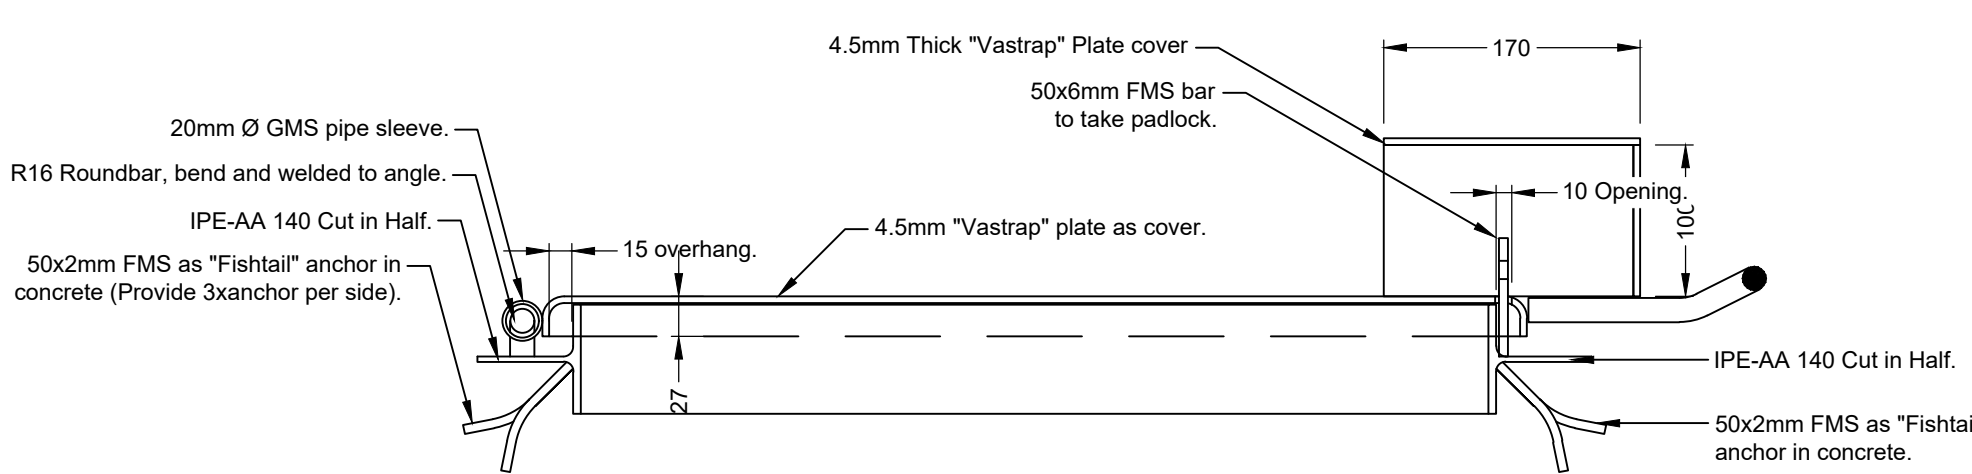

SECTION 4C-4C
Scale 1:5

Do not scale off drawing - ASK THE ENGINEER IF UNCERTAIN!
Any discrepancies between any drawings must be clarified before work is continued on site.

FOR TENDER
PURPOSES ONLY

READ THIS DRAWING IN CONJUNCTION WITH

Drawing Number	Drawing Description

AMENDMENTS

Rev.	Date	Description

ECA CONSULTING VRYHEID OFFICE:
161 High Street | Vryheid | Kwa Zulu Natal | RSA
vryheid@ecaconsult.co.za
Tel: +27 (0)34 983 2825
www.ecaconsult.co.za
Civil and Structural Engineers
Company Reg.: 2004/019299/07
ISO Registered 9001:2015
OTHER OFFICES:
MBOMBELA | GAUTENG | PIETERMARITZBURG | LADYSMITH

Approved by Engineer: Signature:
Name: J.W. Janse v Rensburg
Designation: PrTechEng
ECSA Reg.: 201070143 Date: 27 Oct 2022

Project Funder/ Client:
mig Municipal Infrastructure Grant

Project Implementing Agent:
KING CETSHWAYO DISTRICT MUNICIPALITY KING CETSHWAYO DISTRICT MUNICIPALITY

Approved by Client: Name: Signature: Date:

Project:
KWAHLOKOHLOKO SSA5: PHASE 4 BULK AUGMENTATION

Drawing description:
CHAMBERS GENERAL DETAILS

Drawn: G.D Bezuidenhout Date: Jul 2022
Scale/s: As Shown
Drawing number: 22-032-V-PH4-04-03 Rev.: 00