



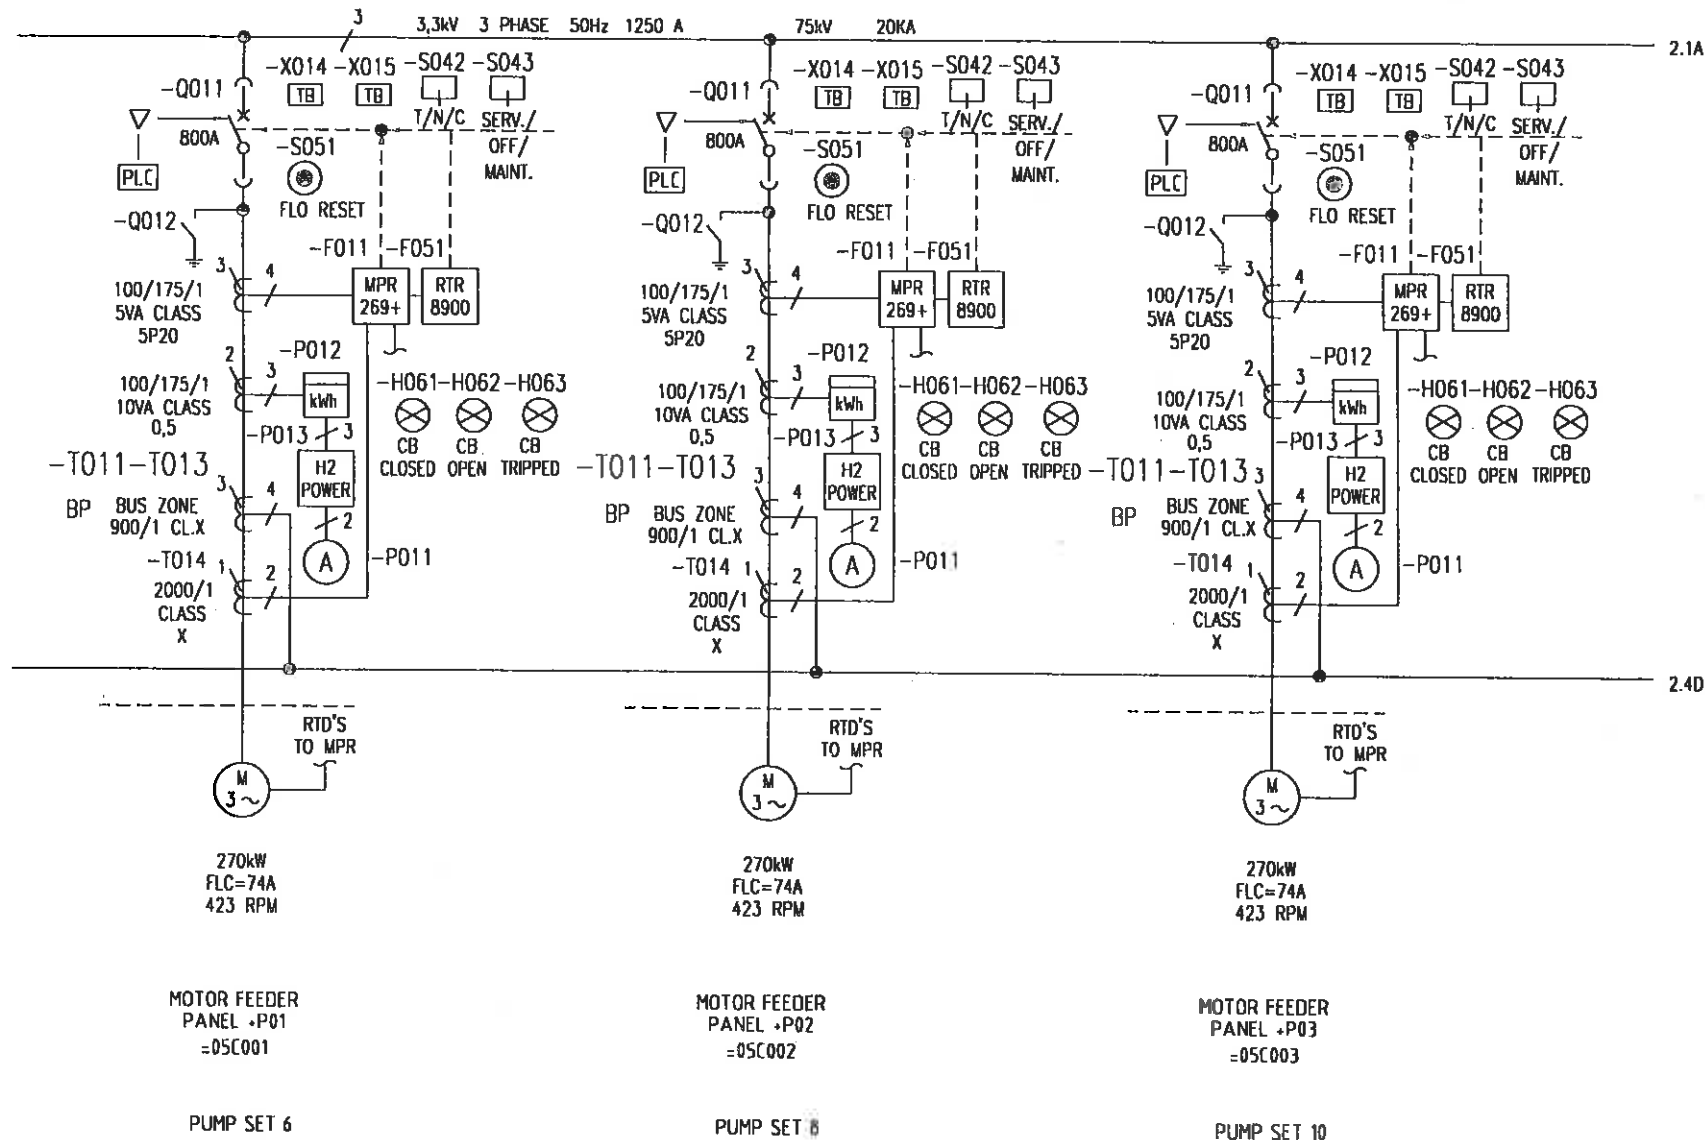

|     |                 |          |      |         |            |                                                                                       |                                                           |                                                                                              |                              |              |
|-----|-----------------|----------|------|---------|------------|---------------------------------------------------------------------------------------|-----------------------------------------------------------|----------------------------------------------------------------------------------------------|------------------------------|--------------|
|     |                 |          |      | APPR    | P.DE VRIES | RAND WATER<br>CONTRACT No. 1856<br>RAW WATER - ENGINE ROOM<br>3,3 kV SWITCHGEAR - 8BF | SIEMENS<br>LIMITED<br>SOUTH AFRICA<br>REG No. 01/07514/06 | TITLE:<br>9 PANELS 3,3kV<br>8BF SWITCHBOARD<br>SINGLE LINE DIAGRAM<br>(3)G53005-F0004-S055-A | RAND WATER DWG. No. :B474001 |              |
|     |                 |          |      | CHECKED | R.CHETTY   |                                                                                       |                                                           |                                                                                              | = 05                         |              |
|     |                 |          |      | DRAWN   | S.TORRES   |                                                                                       |                                                           |                                                                                              | + P0                         |              |
| B   | AS COMMISSIONED | 19.10.96 | RCA  | DATE    | 02-06-95   |                                                                                       |                                                           |                                                                                              | O No. 5215001                | W No. E21068 |
| A   | AS BUILT        | 05.02.96 | RCA  | DATE    | 02-06-95   |                                                                                       |                                                           |                                                                                              | Master Dwg. (MAST)           |              |
| REV | REMARKS         | DATE     | SIGN | DEPT    | PD-MV      |                                                                                       |                                                           |                                                                                              | SHT 1.                       |              |

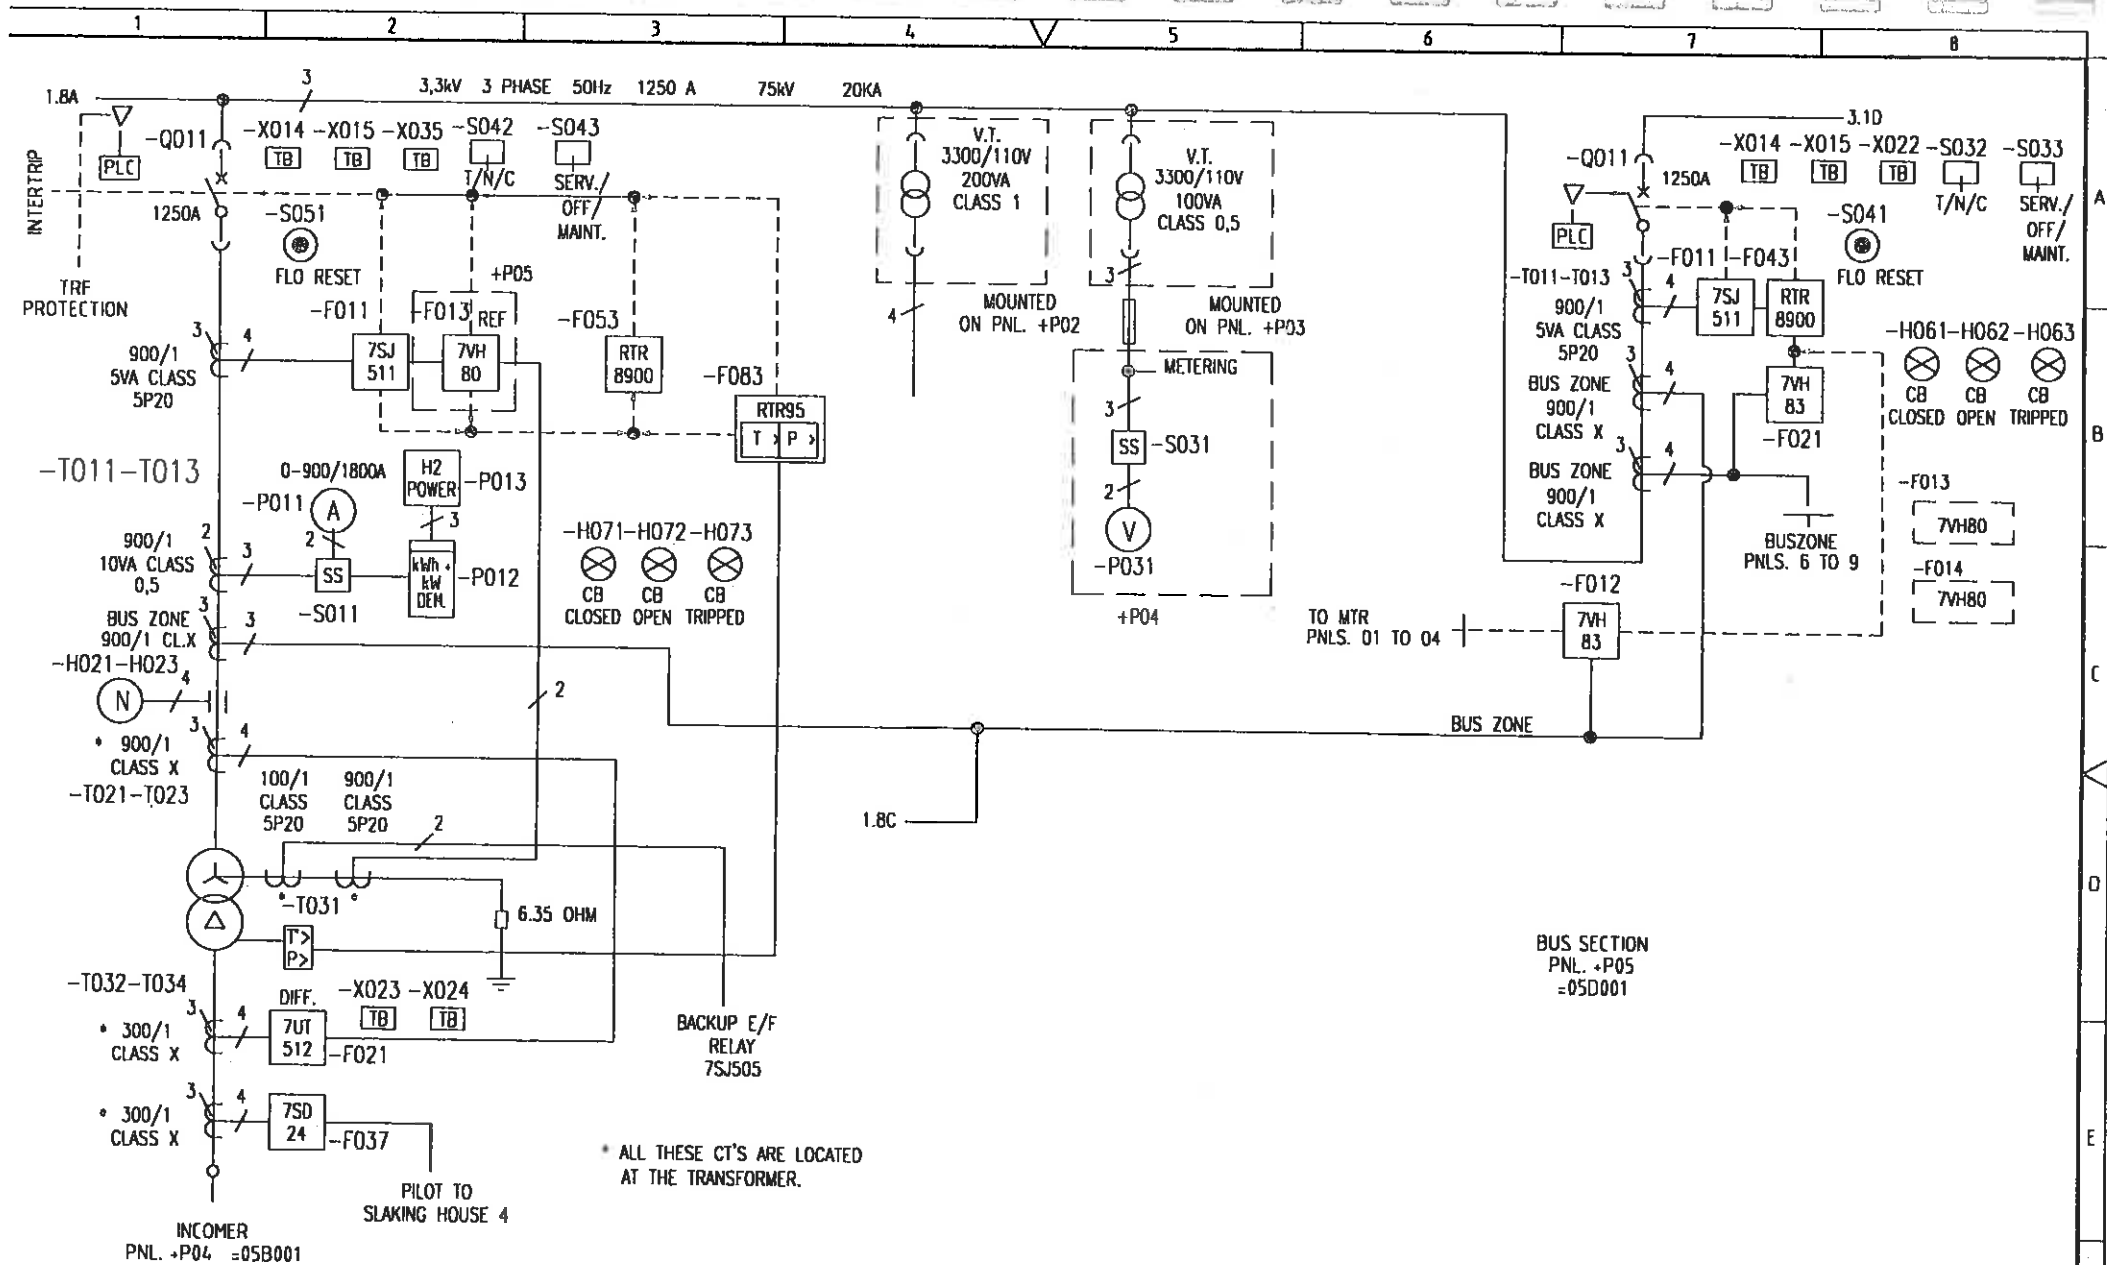

|     |                 |          |      |         |            |                                                            |                                    |                                                                    |                               |  |
|-----|-----------------|----------|------|---------|------------|------------------------------------------------------------|------------------------------------|--------------------------------------------------------------------|-------------------------------|--|
|     |                 |          |      | APPR    | P.DE VRIES | RAND WATER<br>CONTRACT No. 1856<br>RAW WATER - ENGINE ROOM | SIEMENS<br>LIMITED<br>SOUTH AFRICA | TITLE:<br>9 PANELS 3.3kV<br>8BF SWITCHBOARD<br>SINGLE LINE DIAGRAM | RAND WATER DWG. No. :B474.002 |  |
|     |                 |          |      | CHECKED | R.CHETTY   |                                                            |                                    |                                                                    | = 05                          |  |
|     |                 |          |      | DRAWN   | S.STORRES  |                                                            |                                    |                                                                    | • P0                          |  |
| B   | AS COMMISSIONED | 19.10.96 | RCA  | DATE    | 02-06-95   | 3.3 kV SWITCHGEAR - 8BF                                    | REG No. 01/07514/06                | (3) G53005-F0004-S055-B                                            | O No. S215001 W No. E210168   |  |
| A   | AS BUILT        | 05.02.96 | RCA  | DATE    | 02-06-95   |                                                            |                                    |                                                                    | Master Dwg. (MAST)            |  |
| REV | REMARKS         | DATE     | SIGN | DEPT    | PD-MV      |                                                            |                                    |                                                                    | SHT 2.                        |  |



